



UNITED ENGINEERING INC
Mechanical and Electrical Consulting Engineers

3645 Keele St. #105
Toronto, ON, M3J 1M6
Email: info@u-eng.ca
T: (416) 398-1999
F: (416) 398-1933

SITE SUPPLEMENTAL INSTRUCTION

PROJECT: Forestside Estates
Attmar & Palleschi Drive
Brampton, ON

PROJECT NO.: 18-017

CONTRACT: Mechanical

DATE: June 04, 2021

SITE SI NO. M-2

THIS SITE SUPPLEMENTAL INSTRUCTION IS NOT TO BE CONSTRUED AS A CHANGE IN THE CONTRACT PRICE, BUT IS ISSUED FOR CLARIFICATION ONLY. IF A CHANGE IN CONTRACT PRICE IS PERCEIVED, PROVIDE AN ITEMIZED BREAKDOWN OF ANY EXTRAS OR CREDITS WITHIN SEVEN (7) WORKING DAYS.

PURPOSE: To revise mechanical layout to suit architectural SI A-01 and City comments.

1.0 Reference Drawing M-3, M-3A, M-3B (Plumbing P1 - Mechanical) Issued

1.1 Revised: Mechanical layout to suit Arch site instruction.

2.0 Reference Drawing M-4, M-4A, M-4B, M-4C (HVAC GAS - Mechanical) Issued

2.1 Revised: Building D gas pipe layout to suit Arch site instruction.

2.2 Clarify: Building D fresh air shaft location.

2.3 Revised: Air lock diffuser location and volume.

2.4 Relocated: Building B F-16.

2.5 Relocated: Intake louver at sub electrical room 'A'.

3.0 Reference Drawing M-5 – M-14 (Blk "D" - Mechanical) Issued

3.1 Revised: Suite mechanical layout to suit Arch site instruction.

3.2 Deleted: One diffuser at 3rd floor locker room.

3.3 Revised: Make up air riser.

3.4 Revised: Corridor fire damper to combine fire smoke damper.

4.0 Reference Drawing M-15 – M-21 (Blk “C” - Mechanical) Issued

4.1 Deleted: One diffuser at 3rd floor locker room.

4.2 Revised: Make up air riser.

4.3 Revised: Corridor fire damper to combine fire smoke damper.

5.0 Reference Drawing M-25 – M-31 (Blk “B” - Mechanical) Issued

5.1 Deleted: One diffuser at 3rd floor locker room.

5.2 Revised: Make up air riser.

5.3 Revised: Corridor fire damper to combine fire smoke damper.

5.4 Added: Electrical heater in locker room and vestibule.

6.0 Reference Drawing M-35 – M-41 (Blk “A” - Mechanical) Issued

6.1 Deleted: One diffuser at 3rd floor locker room.

6.2 Revised: Make up air riser.

6.3 Revised: Corridor fire damper to combine fire smoke damper.

7.0 Reference Drawing M-45,M-46,M-47 (Typical Units - Mechanical) Issued

7.1 Added: Typical suite layout 2A1-R,2A-R and 2Aa-R.

7.2 Revised: Typical suite 2A,2A1,2Aa ,2Ab, 2A4,2A2,2A3,2A2a kitchen exhaust location according to code requirements.

8.0 Reference Drawing M-49 (Gas Schematic - Mechanical) Issued

8.1 Revised: Building D gas schematic.




PREPARED BY:

Leon Bai
Mechanical Department

Project #18-017
Forestside Estates


ISSUED TO ROYAL PINE HOMES,
Cinzia Caruso, Cinzia@royalpinehomes.com;
Vince Staffieri, vince@royalpinehomes.com;
FOR DISTRIBUTION TO ALL AFFECTED PARTIES.

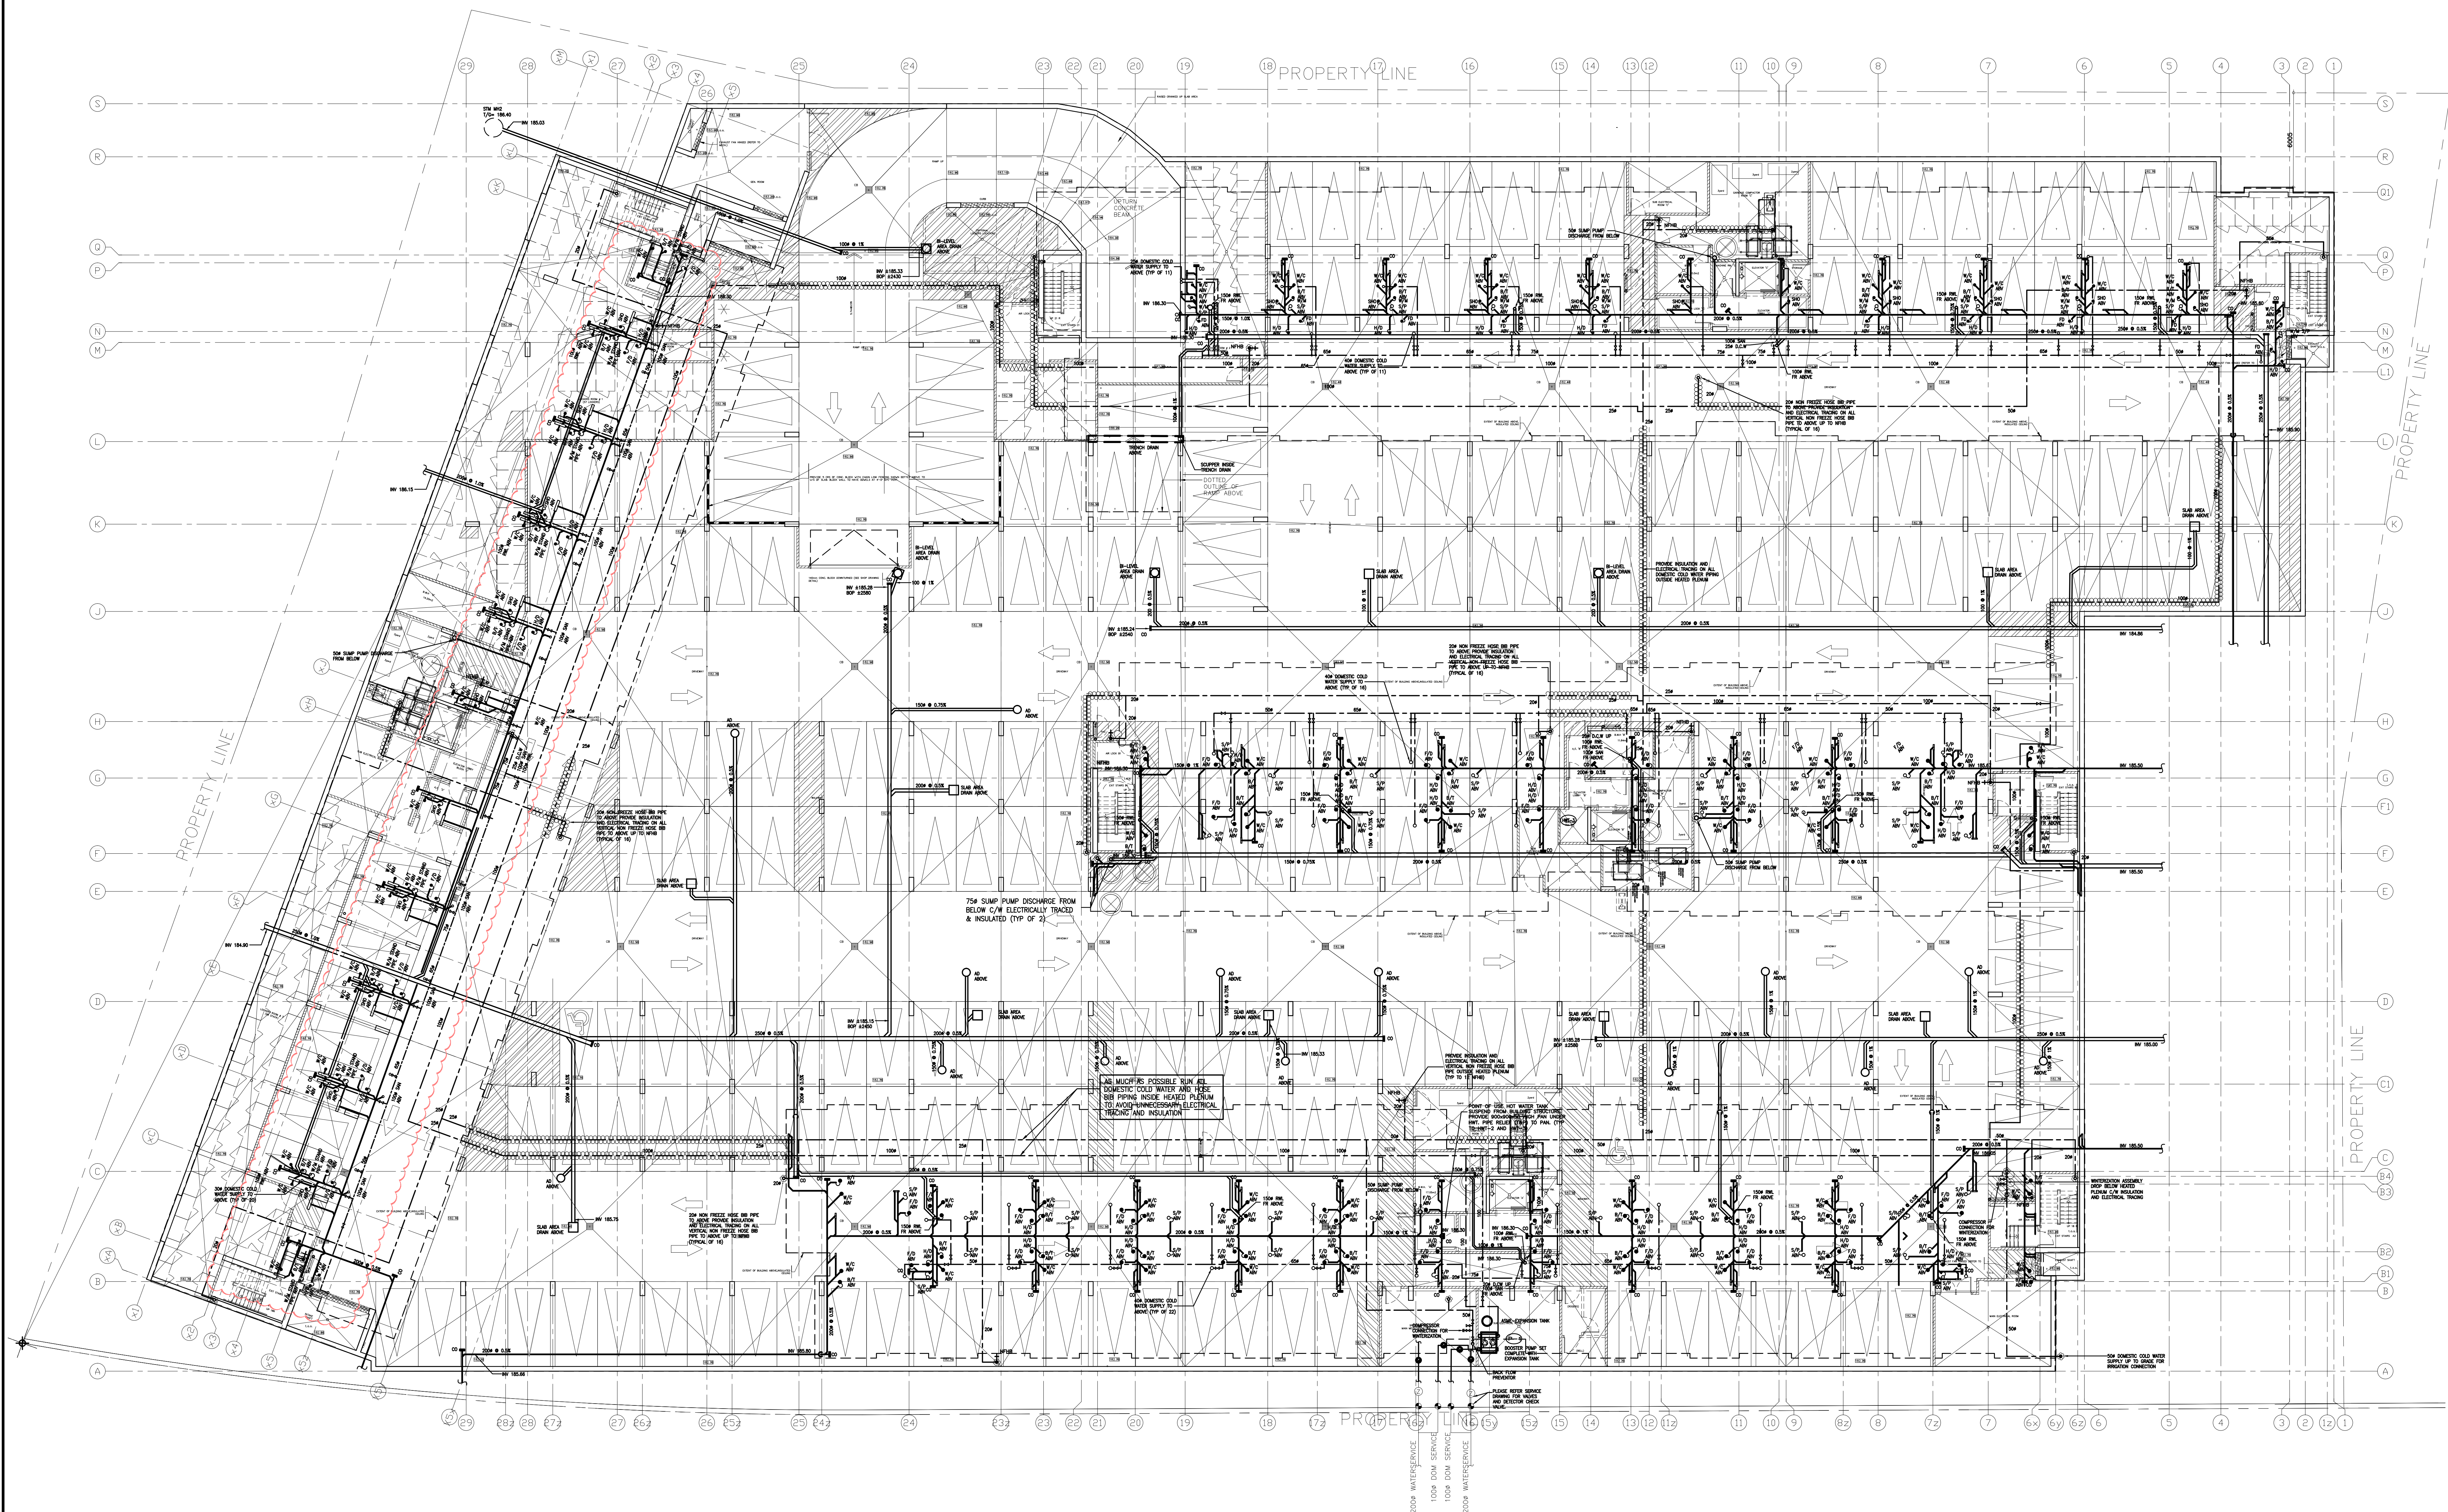

11	LB	ISSUED AS PER SITE INSTRUCTION M-02	JUN. 04, 2021
10	LB	ISSUED AS PER SITE INSTRUCTION M-01	APR. 28, 2021
09	LB	ISSUED FOR PROGRESSIVE CONSTRUCTION	MAR. 26, 2021
08	LB	ISSUED FOR PERMIT BUILDING A.B.C.D.	MAR. 03, 2021
07	LB	ISSUED AS PER ADDENDUM M-05	JAN. 20, 2021
06	LB	ISSUED FOR PERMIT	SEP. 28, 2020
05	RC	ADDENDUM #04	JUN. 12, 2020
04	LB	ADDENDUM #03	MAR. 11, 2020
03	RC	ADDENDUM #02	SEP. 13, 2019
02	RC	ADDENDUM #01	AUG. 13, 2019
01	RC	ISSUED FOR TENDER	AUG. 02, 2019
NO.	BY	DESCRIPTION	DATE

REVISIONS

This drawing is an instrument of service, is provided by and is the property of United Engineering Inc. The contractor must verify and accept responsibility for all dimensions and conditions on site and must notify United Engineering Inc. of any discrepancy before proceeding. United Engineering Inc. is not responsible for the accuracy of Architectural, structural, interior design, etc., on this drawing. Refer to the appropriate trade drawings before proceeding with any work. Installation must conform to all applicable codes and requirements of the authorities having jurisdiction. This drawing is not to be scaled, all symbols are graphic representations only.

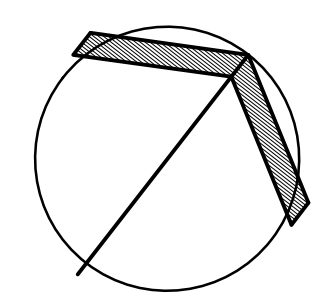

UNITED ENGINEERING INC.
Mechanical Electrical Consulting Engineers
3645 Keele Street, Suite 105,
Toronto, Ontario, M3J 1M6
Tel: (416) 398 1999, Fax: (416) 398 1933


TITLE
**PARKING LEVEL - PLUMBING
MECHANICAL**

PROJECT

**BRAMPTON STACKED
FORESTSIDE ESTATES**

**ATTMAR + PALLESCHI DRIVE
BRAMPTON, ONTARIO**

DRAWN	CHECKED	SCALE
MC	LM	1:150
DATE	PROJECT	DRAWING
MAY, 2019	18-017	M-3
		OF

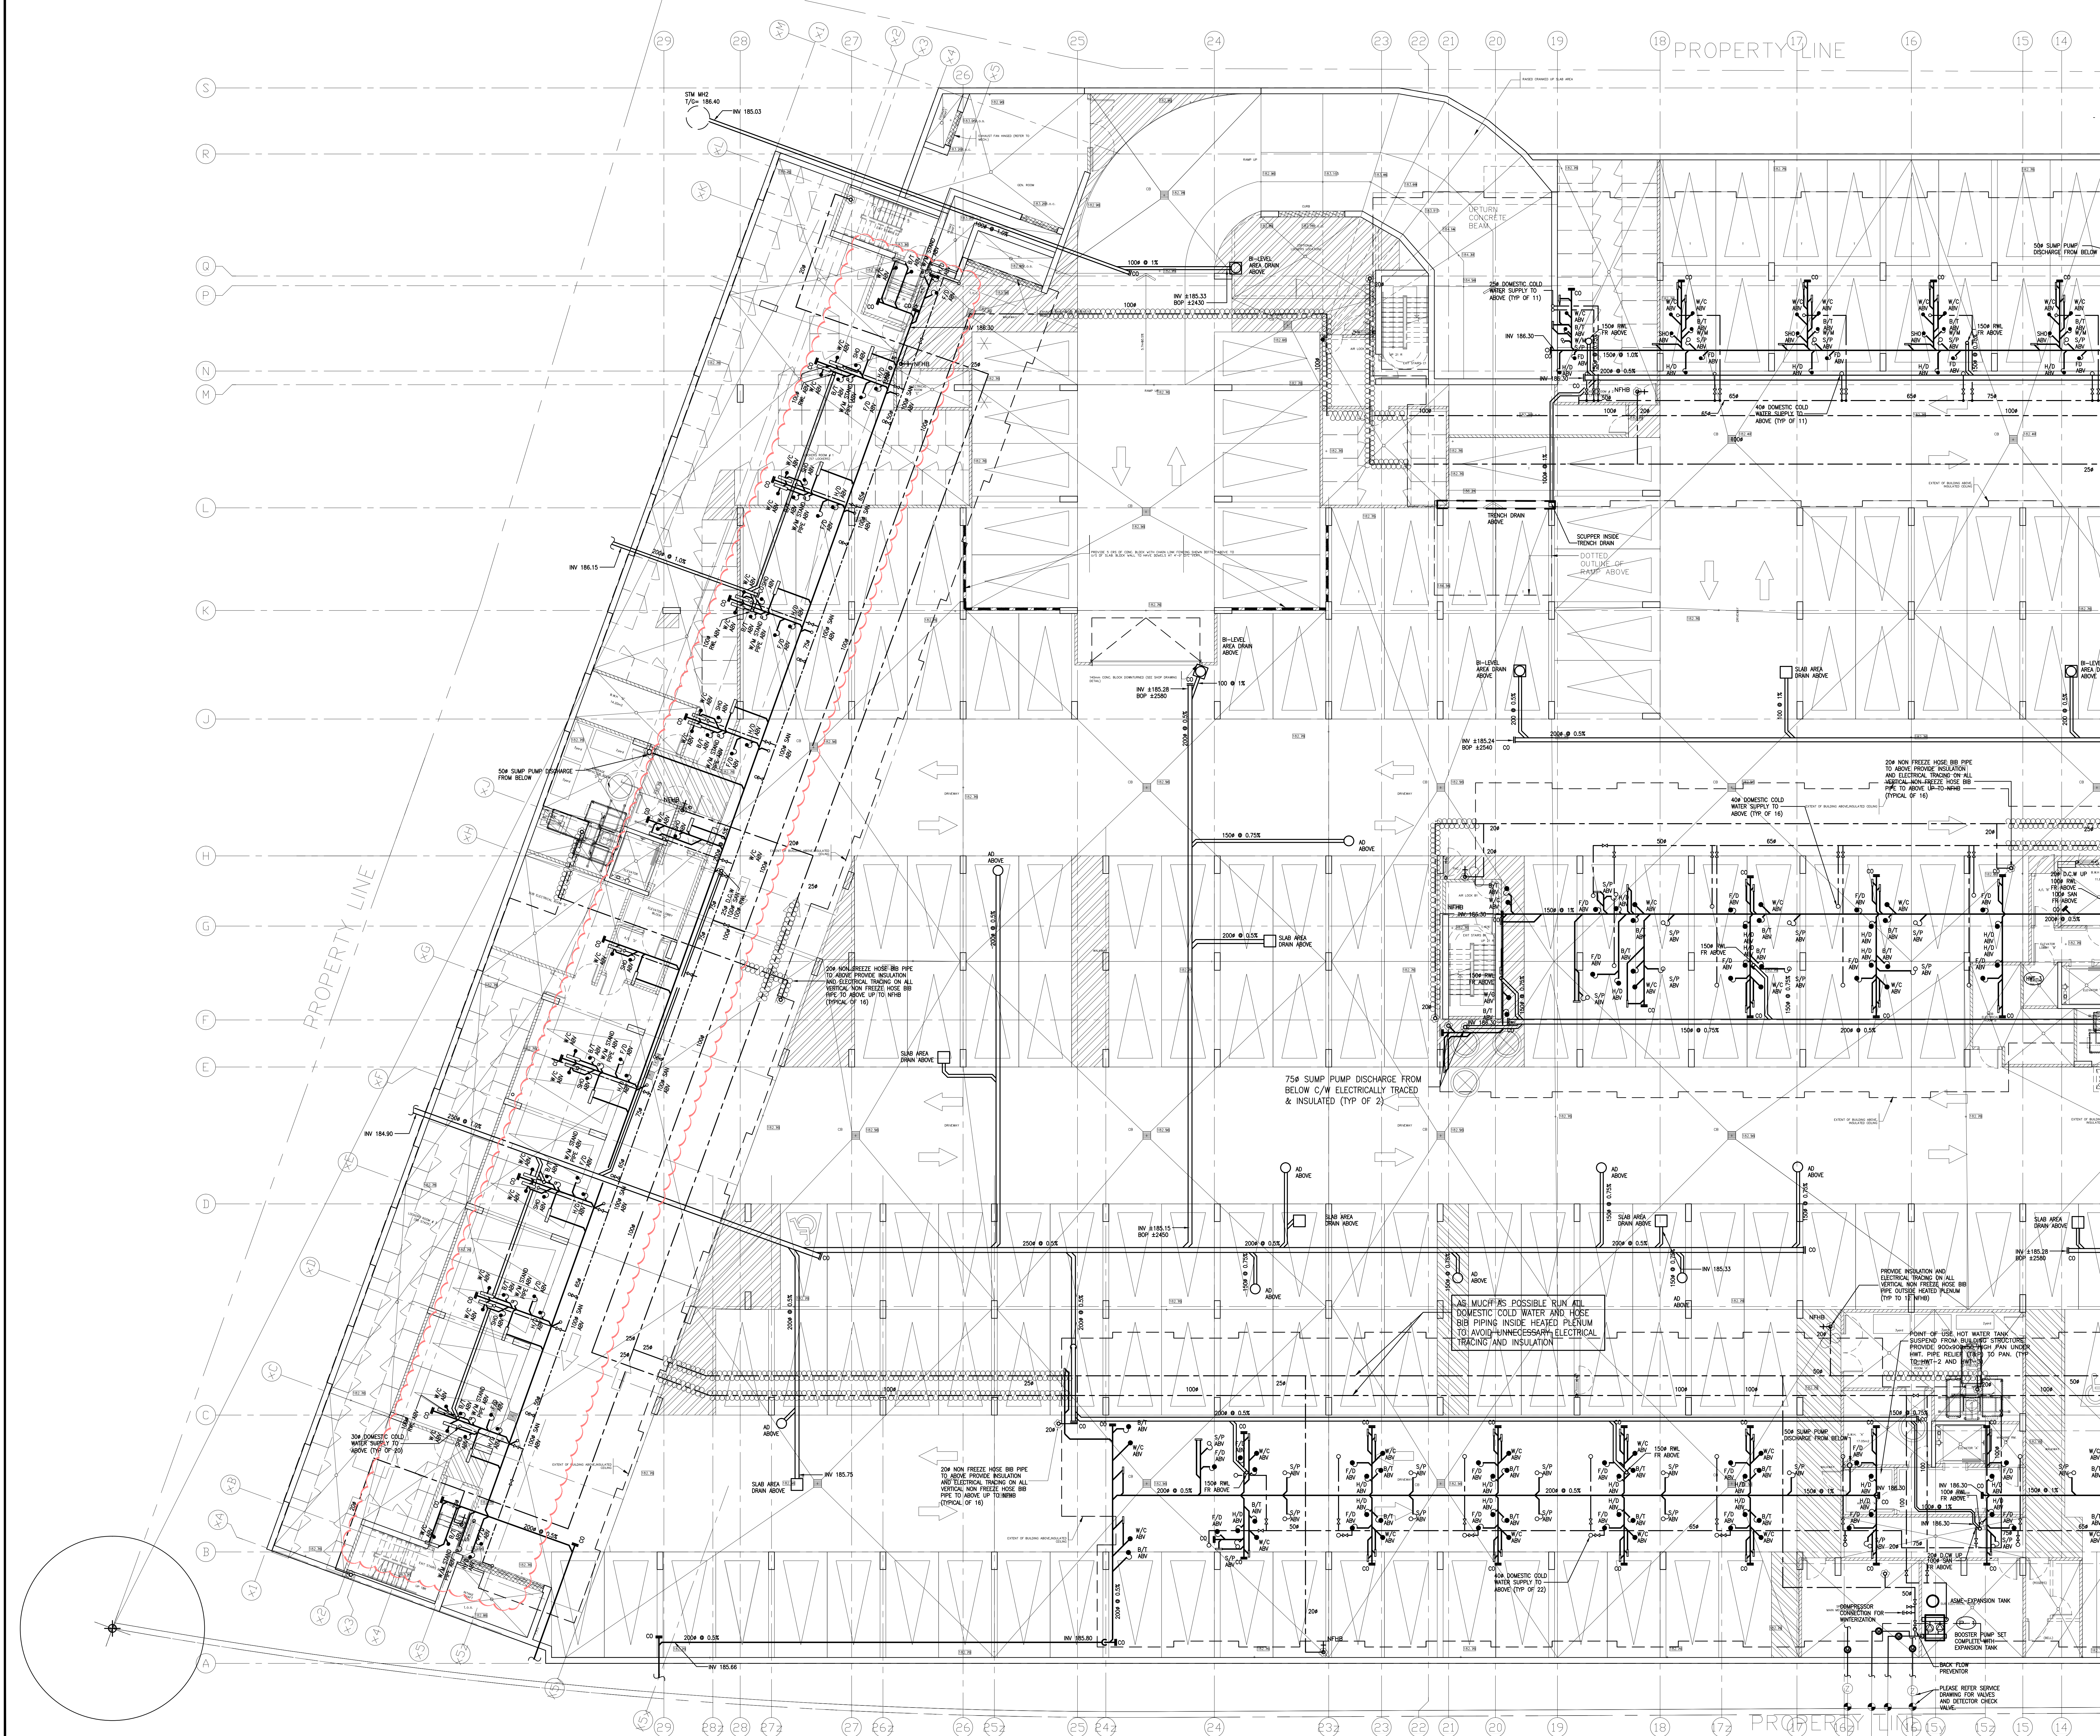

NO.	BY	DESCRIPTION	DATE
08	LB	ISSUED AS PER SITE INSTRUCTION M-02	JUN. 04, 2021
07	LB	ISSUED AS PER SITE INSTRUCTION M-01	APR. 28, 2021
06	LB	ISSUED FOR PERMIT BUILDING A.B.C.D	MAR. 03, 2021
05	LB	ISSUED FOR PERMIT	SEP. 28, 2020
04	RC	ADDENDUM #04	JUN. 12, 2020
03	RC	ADDENDUM #02	SEP. 13, 2019
02	RC	ADDENDUM #01	AUG. 13, 2019
01	RC	ISSUED FOR TENDER	AUG. 02, 2019


REVISIONS

This drawing is an instrument of service, is provided by and is the property of United Engineering Inc. The contractor must verify and accept responsibility for all dimensions and conditions on site and must notify United Engineering Inc. of any discrepancy before proceeding.

United Engineering Inc. is not responsible for the accuracy of Architectural, structural, interior design, etc. on this drawing.

Refer to the appropriate trade drawings before proceeding with any work. Installation must conform to all applicable codes and requirements of the authorities having jurisdiction.

This drawing is not to be scaled, all symbols are graphic representations only.

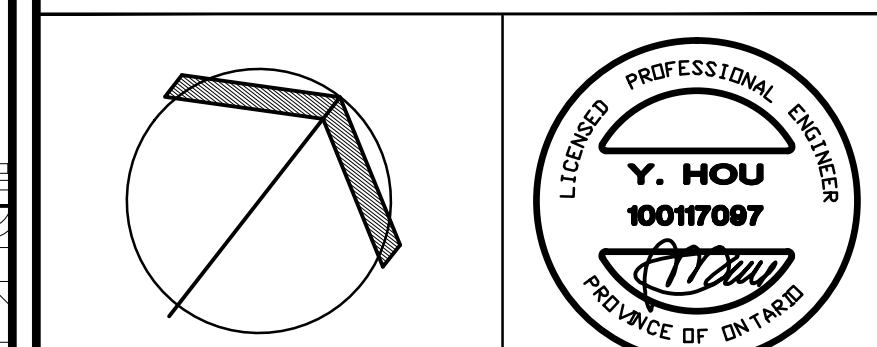


UNITED ENGINEERING INC.
Mechanical Electrical Consulting Engineers
3645 Keele Street, Suite 105,
Toronto, Ontario, M3J 1M6
Tel: (416) 398 1599, Fax: (416) 398 1933

TITLE
PARKING LEVEL - PLUMBING
MECHANICAL - PART 1

PROJECT
BRAMPTON STACKED
FORESTSIDE ESTATES

**ATTMAY + PALLESCI DRIVE
BRAMPTON, ONTARIO**

DRAWN MC	CHECKED LM	SCALE 1:100
DATE MAY, 2019	PROJECT 18-017	DRAWING M-3A
		OF -

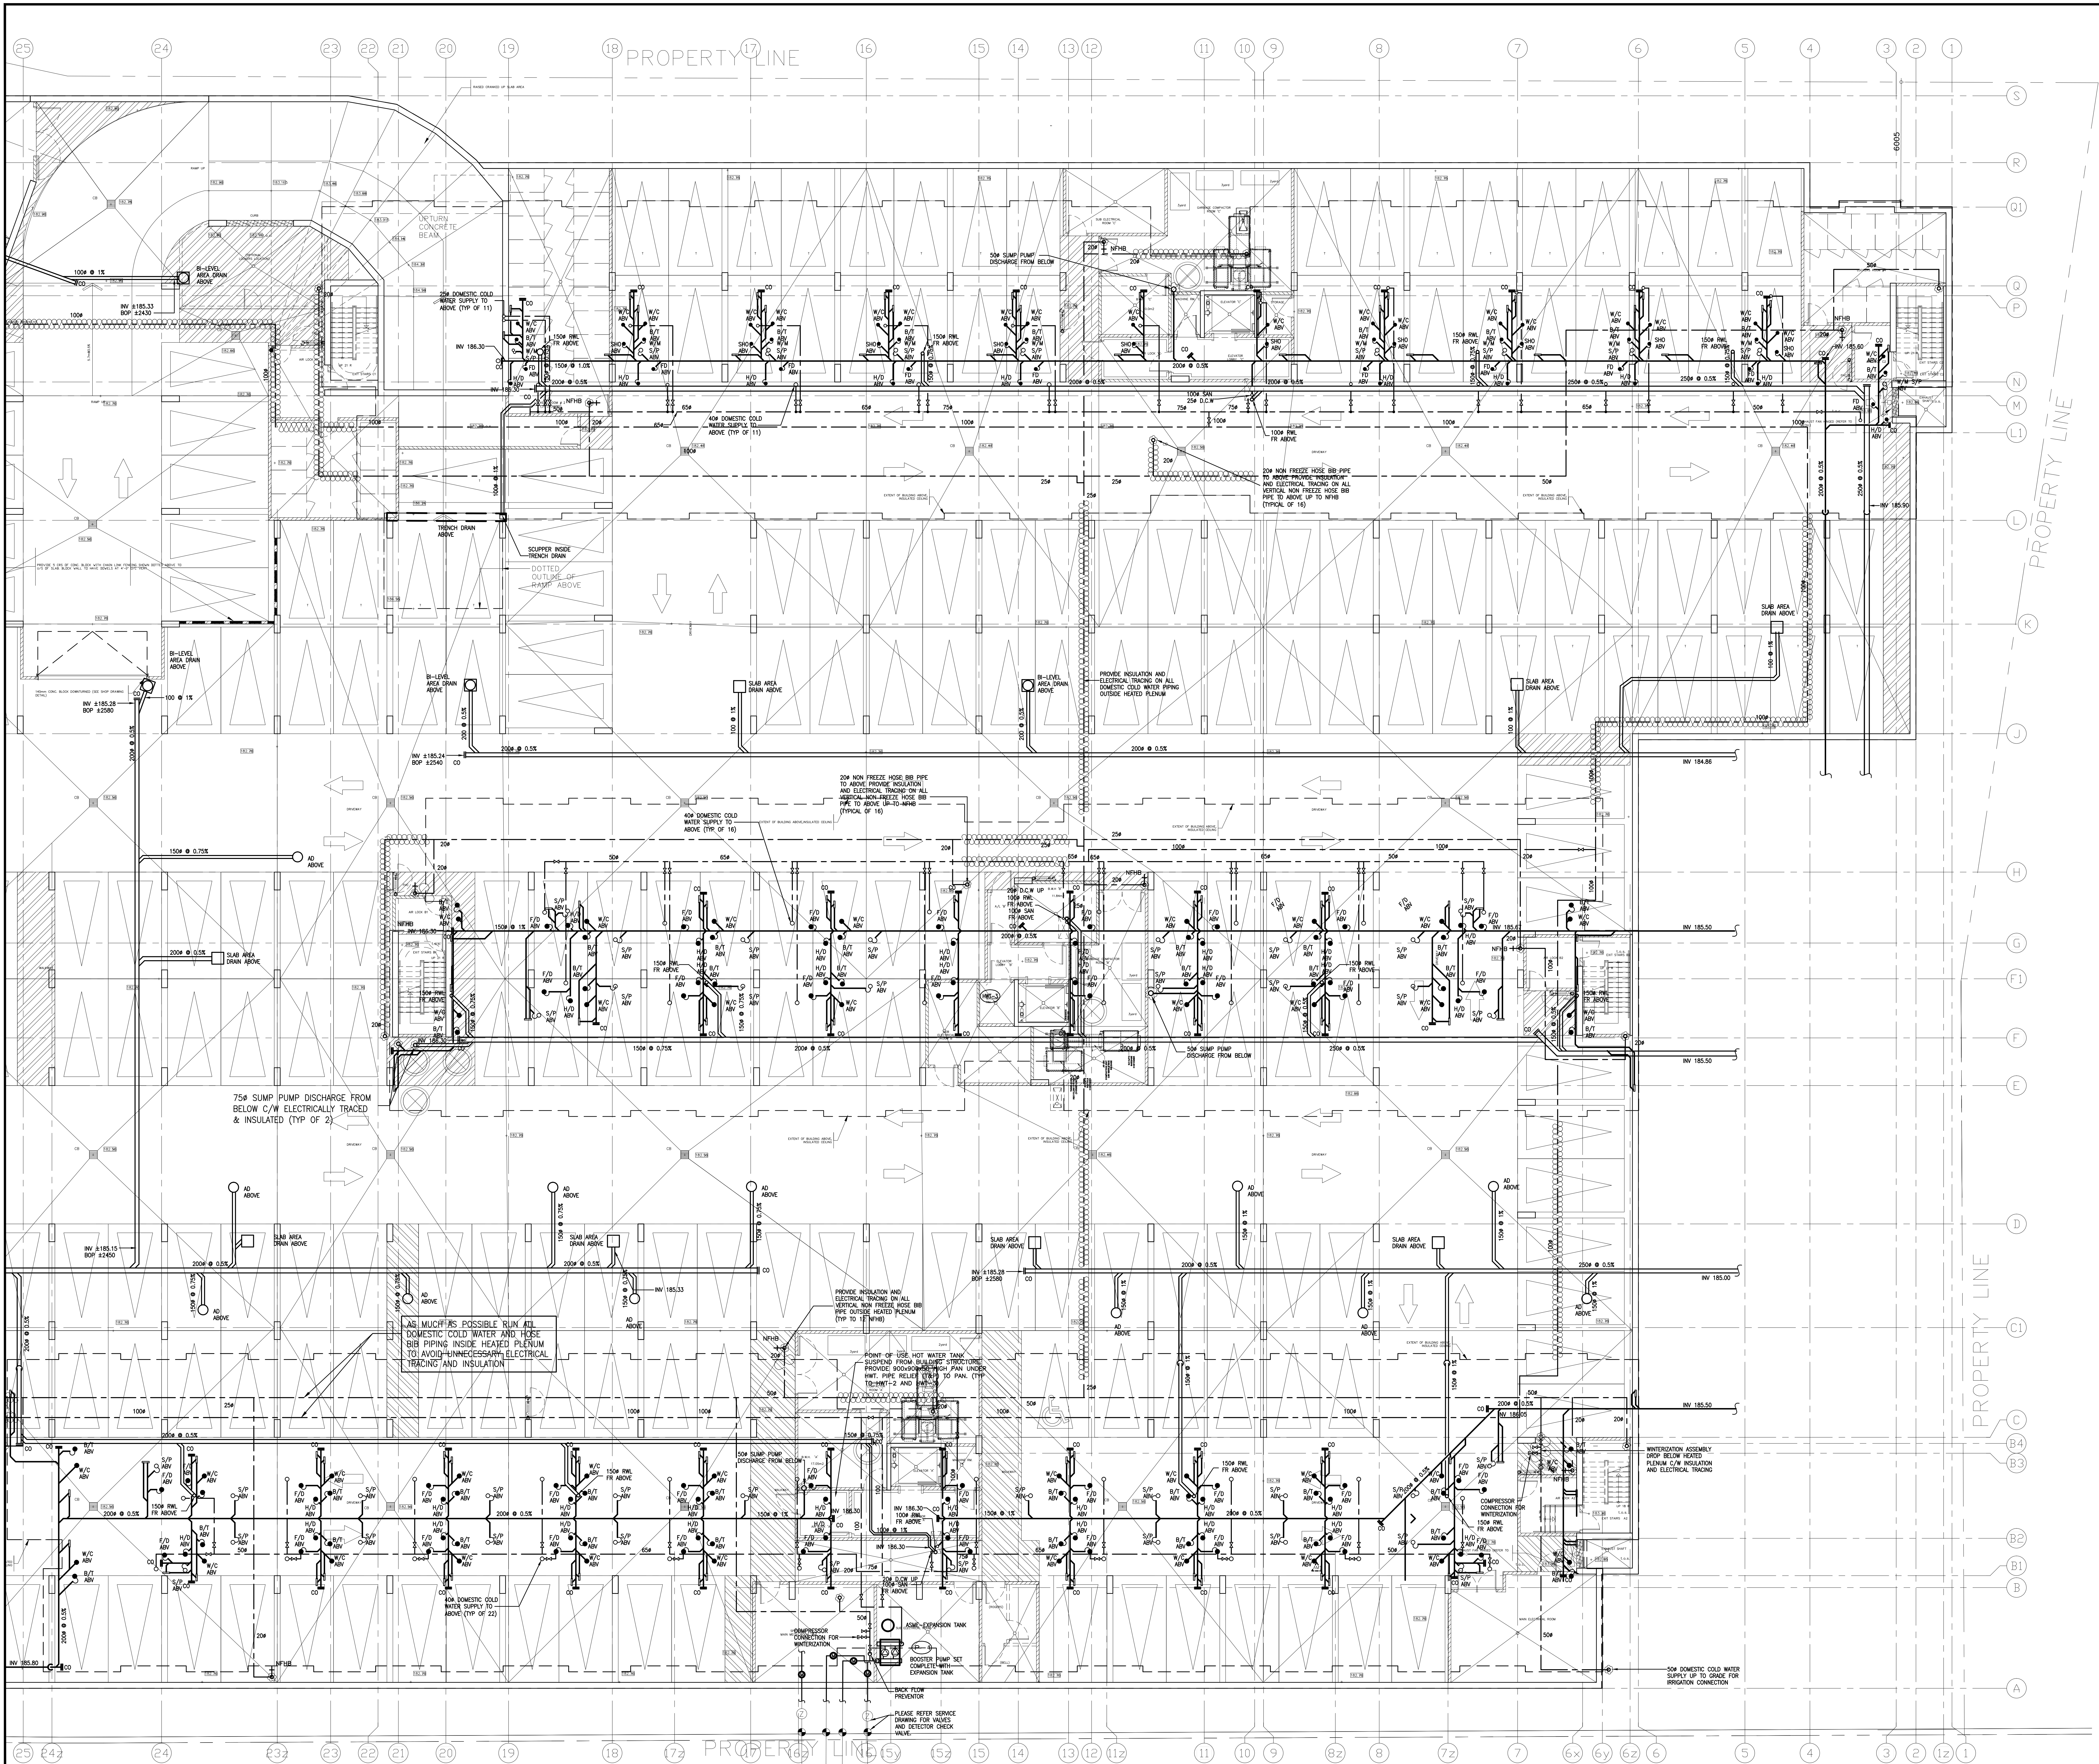

NO.	BY	DESCRIPTION	DATE
09	LB	ISSUED AS PER SITE INSTRUCTION M-02	JUN. 04, 2021
08	LB	ISSUED AS PER SITE INSTRUCTION M-01	APR. 28, 2021
07	LB	ISSUED FOR PERMIT BUILDING A.B.C.D	MAR. 03, 2021
06	LB	ISSUED AS PER ADDENDUM M-05	JAN. 20, 2021
05	LB	ISSUED FOR PERMIT	SEP. 28, 2020
04	RC	ADDENDUM #04	JUN. 12, 2020
03	RC	ADDENDUM #02	SEP. 13, 2019
02	RC	ADDENDUM #01	AUG. 13, 2019
01	RC	ISSUED FOR TENDER	AUG. 02, 2019


REVISIONS

This drawing is an instrument of service, is provided by and is the property of United Engineering Inc. The contractor must verify and accept responsibility for all dimensions and conditions on site and must notify United Engineering Inc. of any discrepancy before proceeding.

United Engineering Inc. is not responsible for the accuracy of Architectural, structural, interior design, etc., on this drawing.

Refer to the appropriate trade drawings before proceeding with any work. Installation must conform to all applicable codes and requirements of the authorities having jurisdiction.

This drawing is not to be scaled, all symbols are graphic representations only.

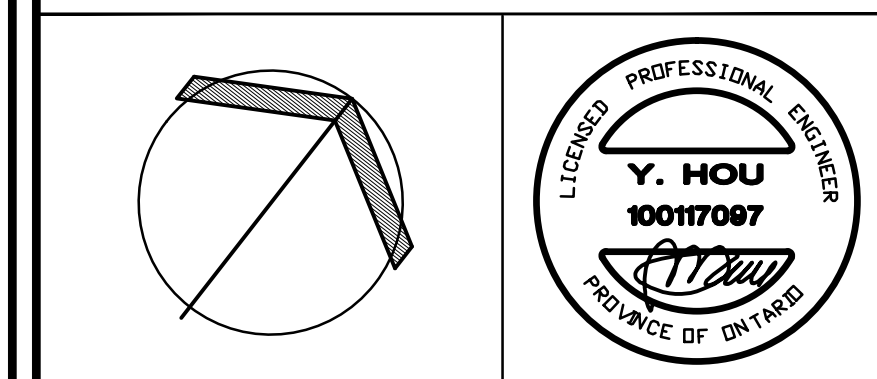


UNITED ENGINEERING INC.
Mechanical Electrical Consulting Engineers
3645 Keele Street, Suite 105,
Toronto, Ontario, M3J 1M6
Tel: (416) 398 1599, Fax: (416) 398 1933

TITLE
**PARKING LEVEL - PLUMBING
MECHANICAL - PART 2**
PROJECT

**BRAMPTON STACKED
FORESTSIDE ESTATES**
ATTMAR + PALLESCI DRIVE
BRAMPTON, ONTARIO


DRAWN MC	CHECKED LM	SCALE 1:100
DATE MAY, 2019	PROJECT 18-017	DRAWING M-3B OF

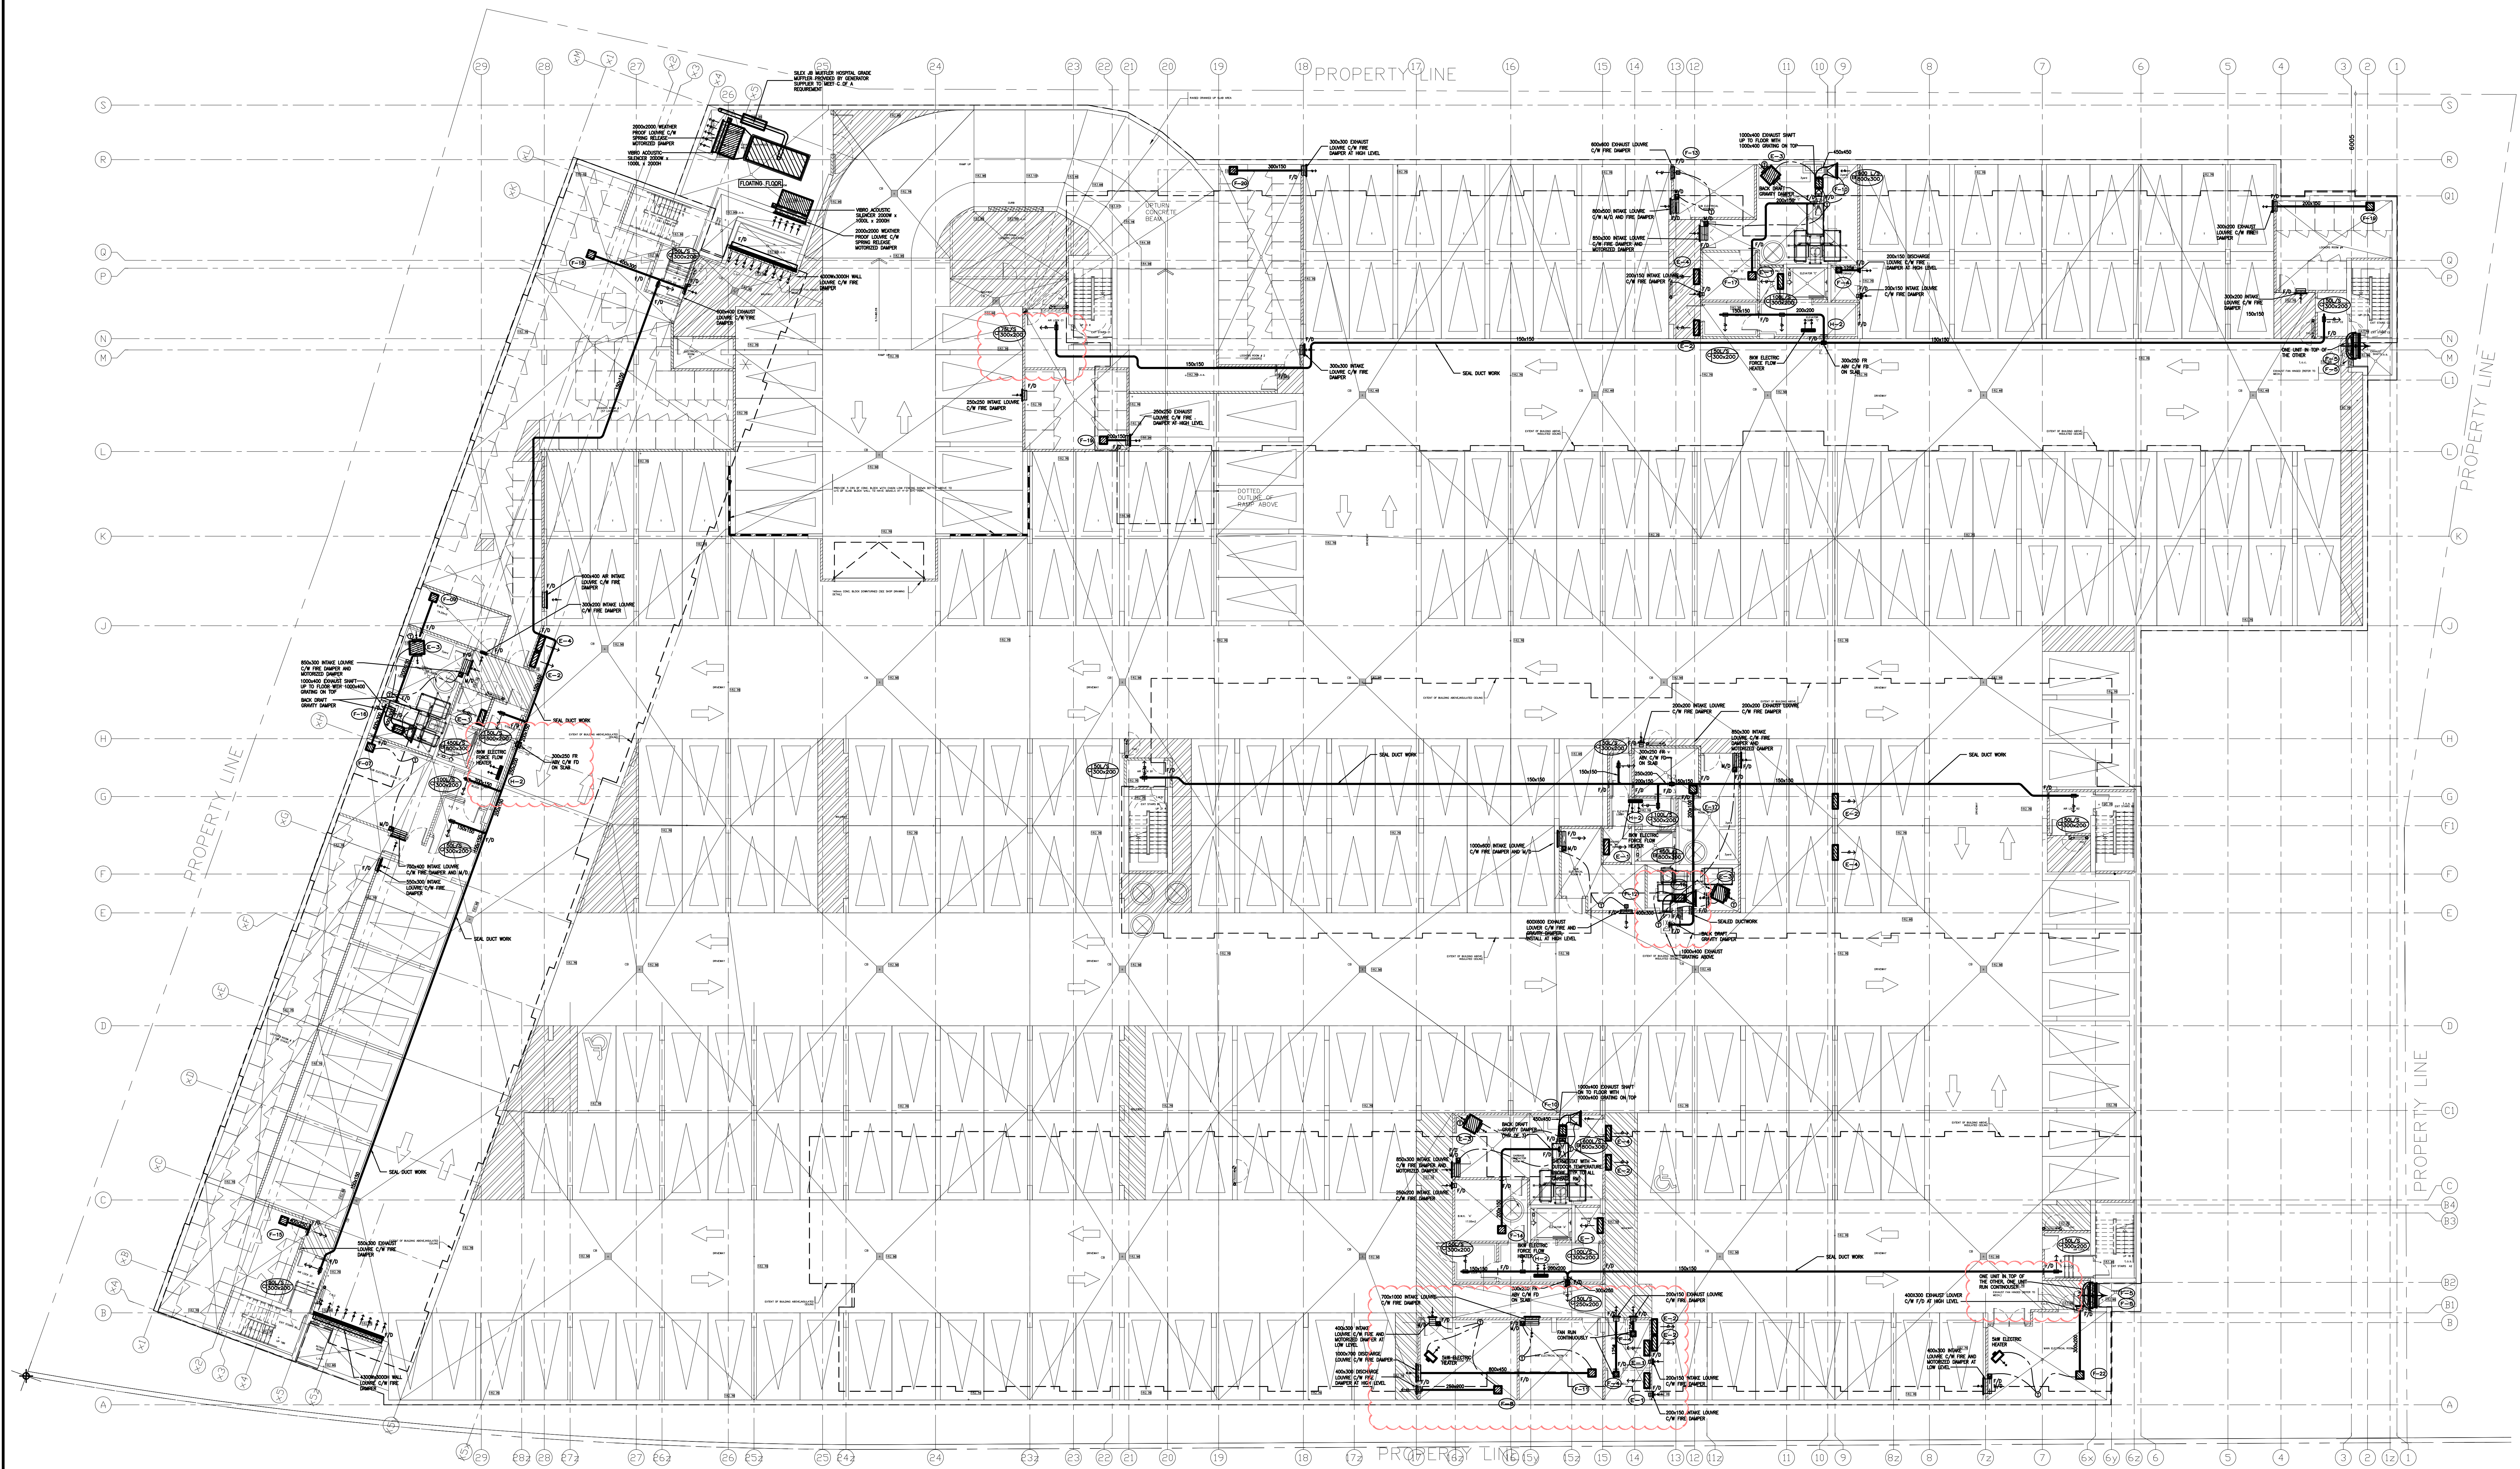

NO.	BY	DESCRIPTION	DATE
09	LB	ISSUED AS PER SITE INSTRUCTION M-02	JUN. 04, 2021
08	LB	ISSUED AS PER SITE INSTRUCTION M-01	APR. 28, 2021
07	LB	ISSUED FOR PROGRESSIVE CONSTRUCTION	MAR. 26, 2021
06	LB	ISSUED FOR PERMIT BUILDING A,B,C,D	MAR. 03, 2021
05	LB	ISSUED AS PER ADDENDUM M-05	JAN. 20, 2021
04	LB	ISSUED FOR PERMIT	SEP. 28, 2020
03	RC	ADDENDUM #04	JUN. 12, 2020
02	RC	ADDENDUM #02	SEP. 13, 2019
01	RC	ISSUED FOR TENDER	AUG. 02, 2019

REVISIONS

This drawing is an instrument of service, is provided by and is the property of United Engineering Inc. The contractor must verify and accept responsibility for all dimensions and conditions on site and must notify United Engineering Inc. of any discrepancy before proceeding. United Engineering Inc. is not responsible for the accuracy of Architectural, structural, interior design, etc. on this drawing. Refer to the appropriate trade drawings before proceeding with any work. Installation must conform to all applicable codes and requirements of the authorities having jurisdiction. This drawing is not to be scaled, all symbols are graphic representations only.

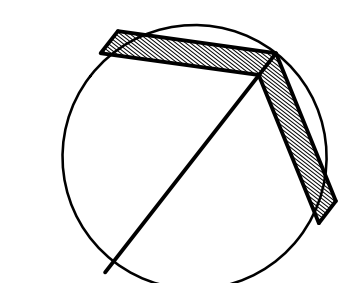

UNITED ENGINEERING INC.
Mechanical Electrical Consulting Engineers
3645 Keele Street, Suite 105,
Toronto, Ontario, M3J 1M6
Tel: (416) 398 1999, Fax: (416) 398 1933


TITLE
**PARKING LEVEL - HVAC
MECHANICAL**

PROJECT

**BRAMPTON STACKED
FORESTSIDE ESTATES**

**ATTMAR + PALLESCI DRIVE
BRAMPTON, ONTARIO**

DRAWN	CHECKED	SCALE
MC	LM	1:150
DATE	PROJECT	DRAWING
MAY, 2019	18-017	M-4
		OF

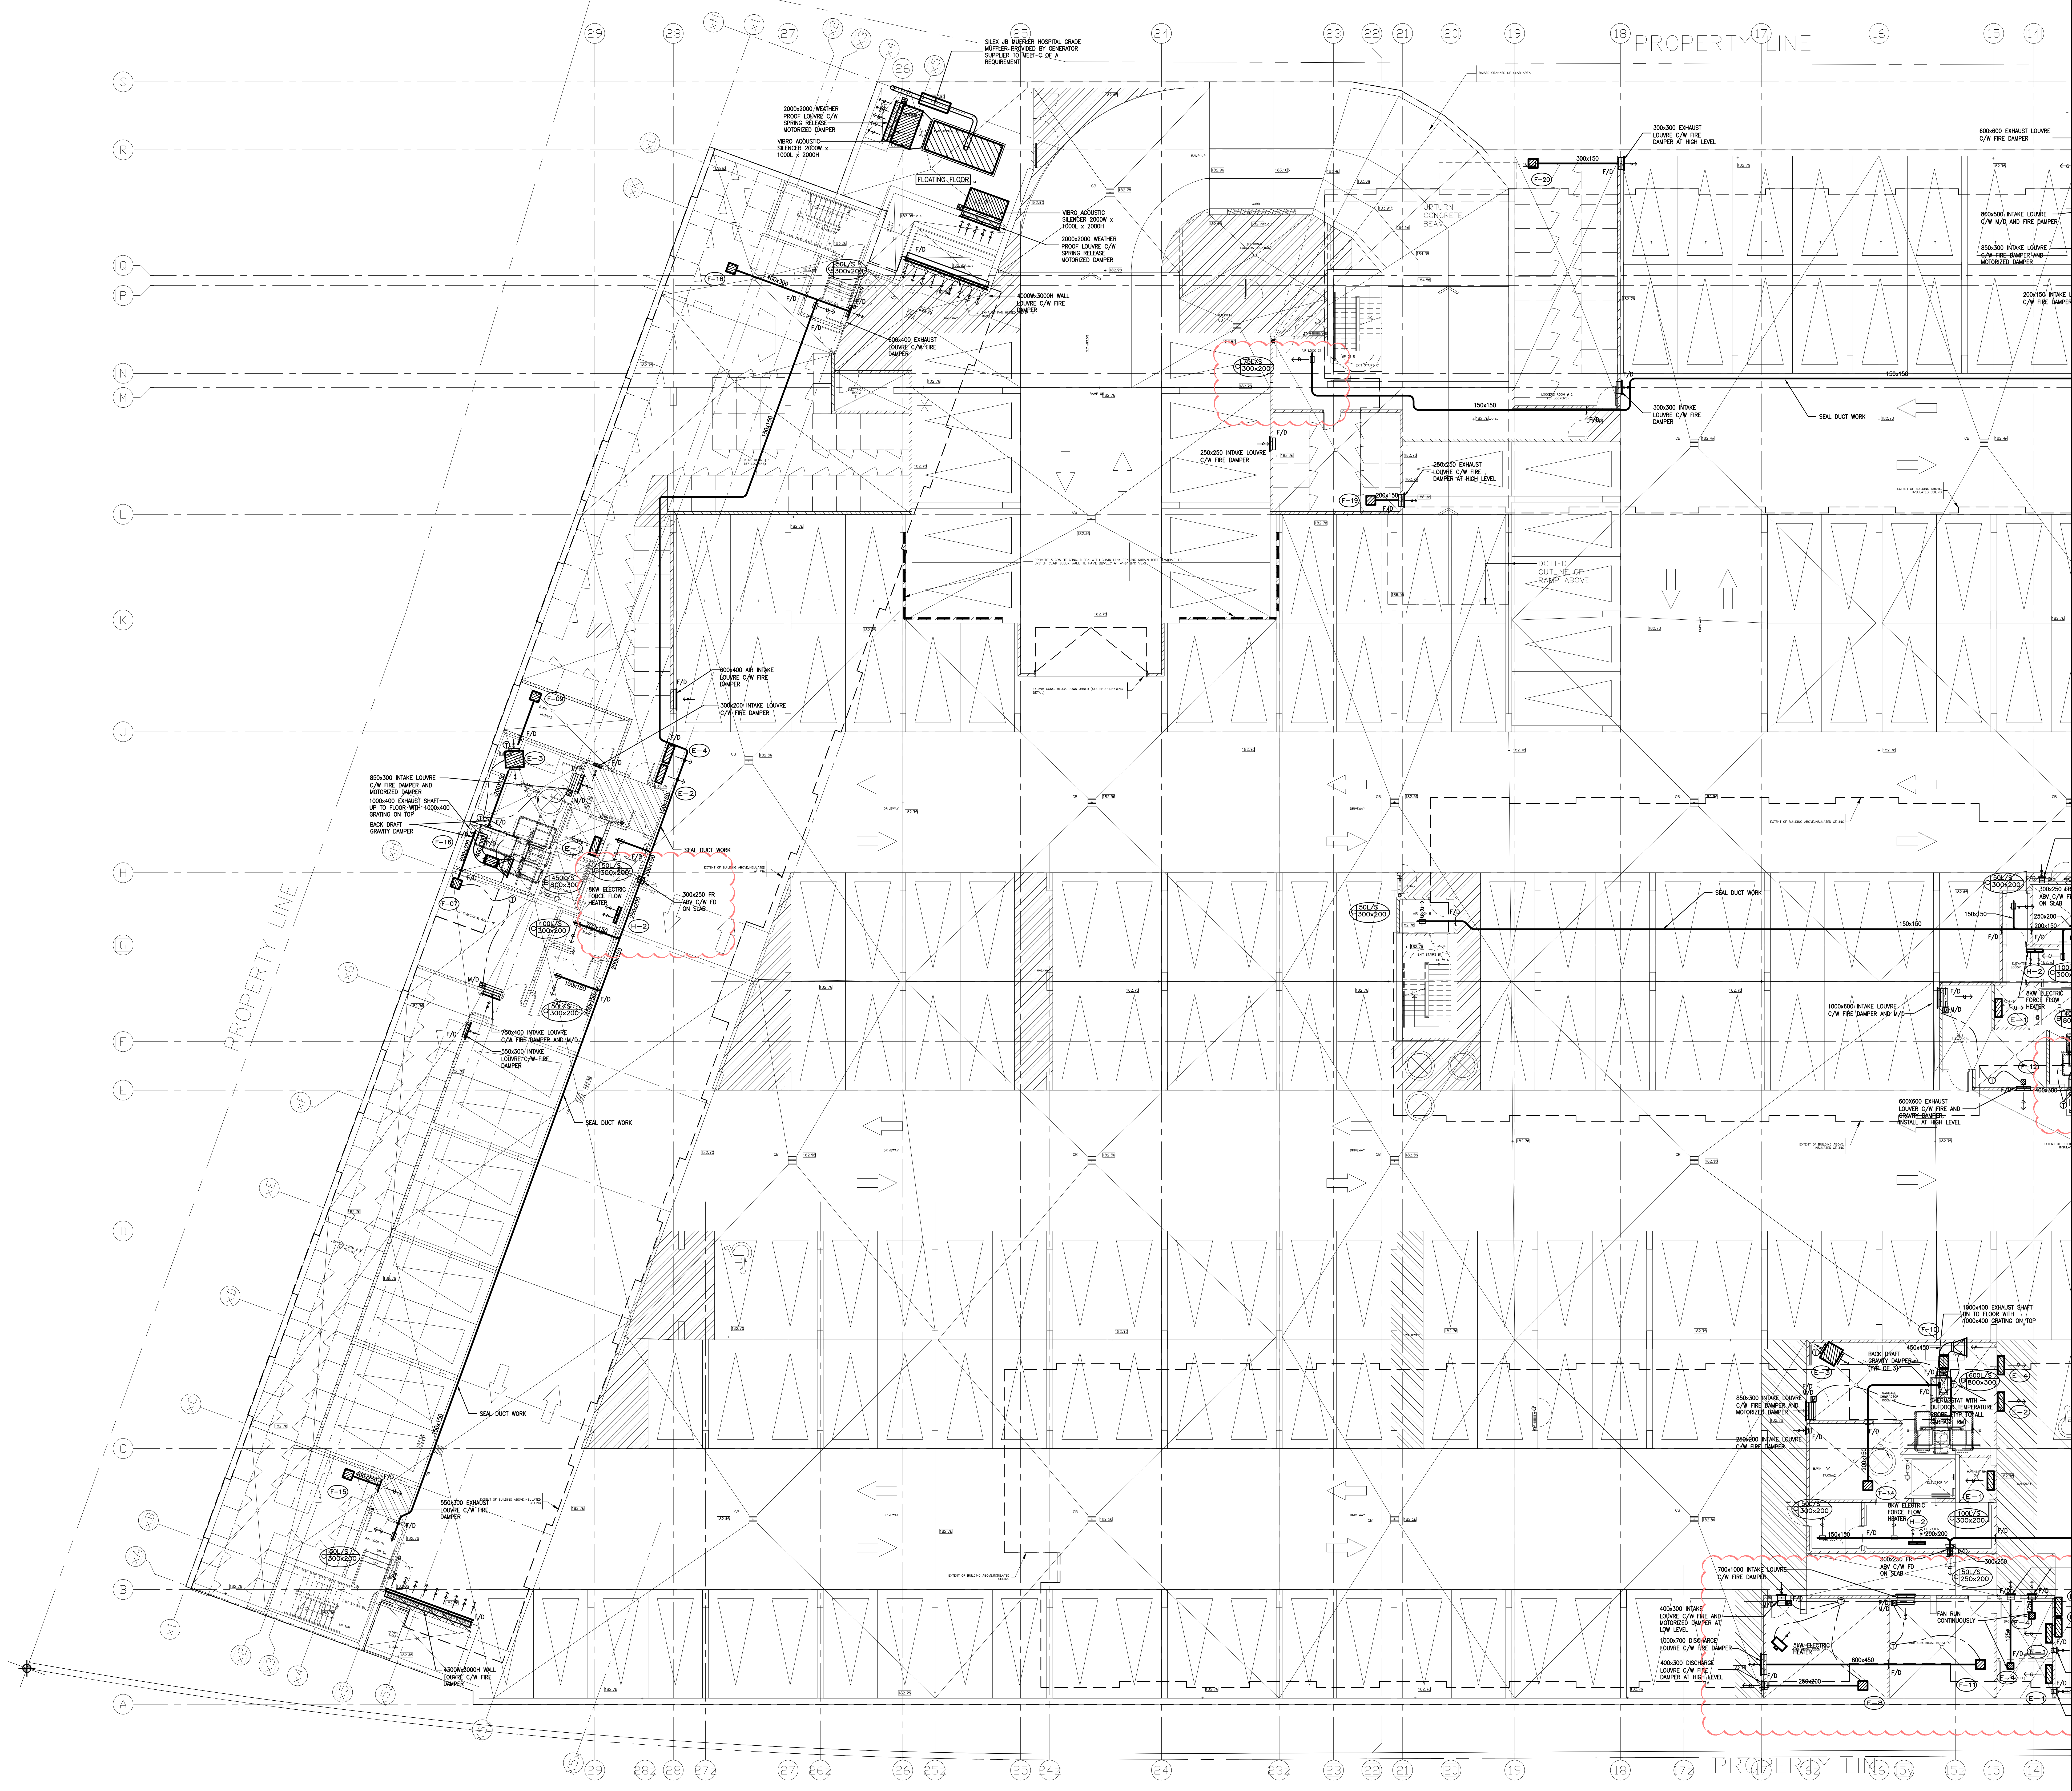

NO.	BY	DESCRIPTION	DATE
09	LB	ISSUED AS PER SITE INSTRUCTION M-02	JUN. 04, 2021
08	LB	ISSUED AS PER SITE INSTRUCTION M-01	APR. 28, 2021
07	LB	ISSUED FOR PROGRESSIVE CONSTRUCTION	MAR. 26, 2021
06	LB	ISSUED FOR PERMIT BUILDING A,B,C,D	MAR. 03, 2021
05	LB	ISSUED AS PER ADDENDUM M-05	JAN. 20, 2021
04	LB	ISSUED FOR PERMIT	SEP. 28, 2020
03	RC	ADDENDUM #04	JUN. 12, 2020
02	RC	ADDENDUM #02	SEP. 13, 2019
01	RC	ISSUED FOR TENDER	AUG. 02, 2019


REVISIONS

This drawing is an instrument of service, is provided by and is the property of United Engineering Inc. The contractor must verify and accept responsibility for all dimensions and conditions on site and must notify United Engineering Inc. of any discrepancy before proceeding.

United Engineering Inc. is not responsible for the accuracy of Architectural, structural, interior design, etc. on this drawing.


Refer to the appropriate trade drawings before proceeding with any work. Installation must conform to all applicable codes and requirements of the authorities having jurisdiction.

This drawing is not to be scaled, all symbols are graphic representations only.

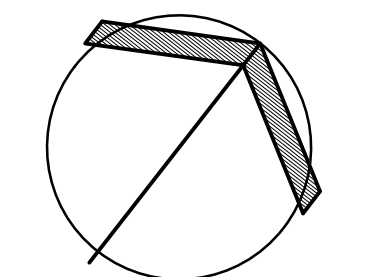

UNITED ENGINEERING INC.
Mechanical Electrical Consulting Engineers
3645 Keele Street, Suite 105,
Toronto, Ontario, M3J 1M6
Tel: (416) 398 1599, Fax: (416) 398 1933


TITLE PARKING LEVEL - HVAC MECHANICAL - PART 1	
PROJECT BRAMPTON STACKED FORESTSIDE ESTATES	
ATTMUR + PALLESCI DRIVE BRAMPTON, ONTARIO	
DRAWN MC	CHECKED LM
DATE MAY, 2019	SCALE 1:100
PROJECT 18-017	DRAWING M-4A
	OF

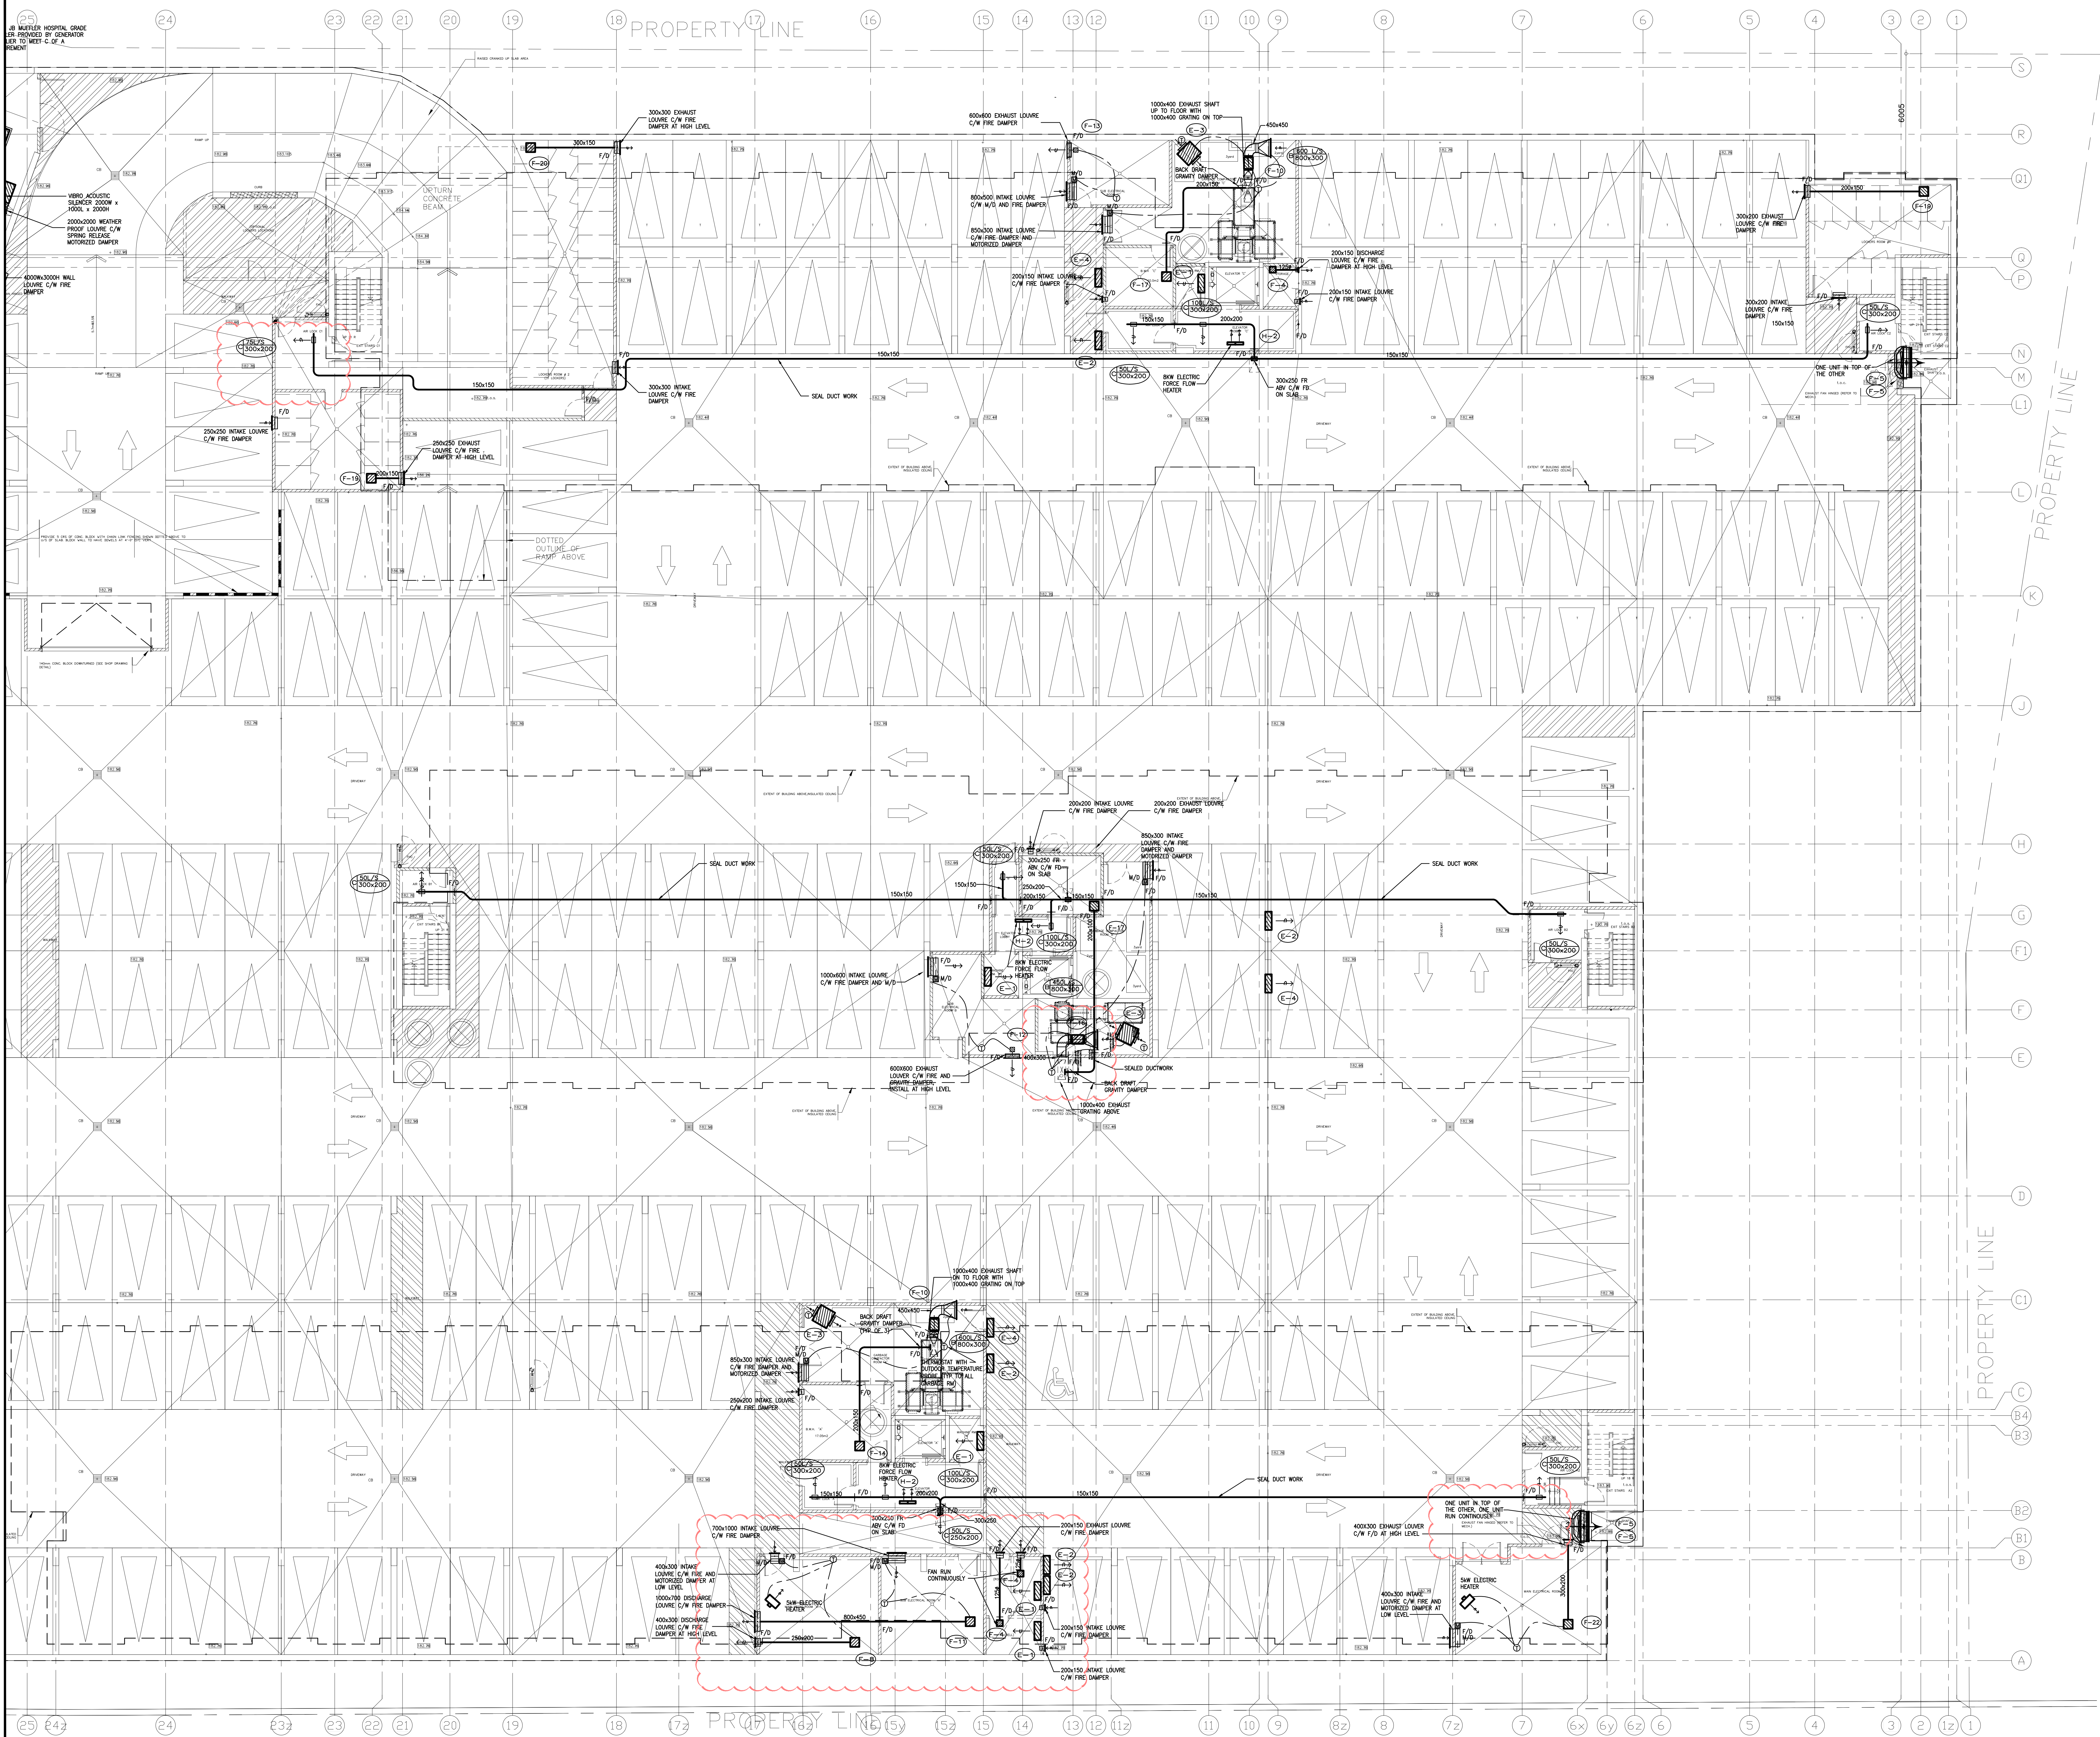

NO.	BY	DESCRIPTION	DATE
09	LB	ISSUED AS PER SITE INSTRUCTION M-02	JUN. 04, 2021
08	LB	ISSUED AS PER SITE INSTRUCTION M-01	APR. 28, 2021
07	LB	ISSUED FOR PROGRESSIVE CONSTRUCTION	MAR. 26, 2021
06	LB	ISSUED FOR PERMIT BUILDING A,B,C,D	MAR. 03, 2021
05	LB	ISSUED AS PER ADDENDUM M-05	JAN. 20, 2021
04	LB	ISSUED FOR PERMIT	SEP. 28, 2020
03	RC	ADDENDUM #04	JUN. 12, 2020
02	RC	ADDENDUM #02	SEP. 13, 2019
01	RC	ISSUED FOR TENDER	AUG. 02, 2019

REVISIONS

This drawing is an instrument of service, is provided by and is the property of United Engineering Inc. The contractor must verify and accept responsibility for all dimensions and conditions on site and must notify United Engineering Inc. of any discrepancy before proceeding. United Engineering Inc. is not responsible for the accuracy of Architectural, structural, interior design, etc., on this drawing. Refer to the appropriate trade drawings before proceeding with any work. Installation must conform to all applicable codes and requirements of the authorities having jurisdiction. This drawing is not to be scaled, all symbols are graphic representations only.

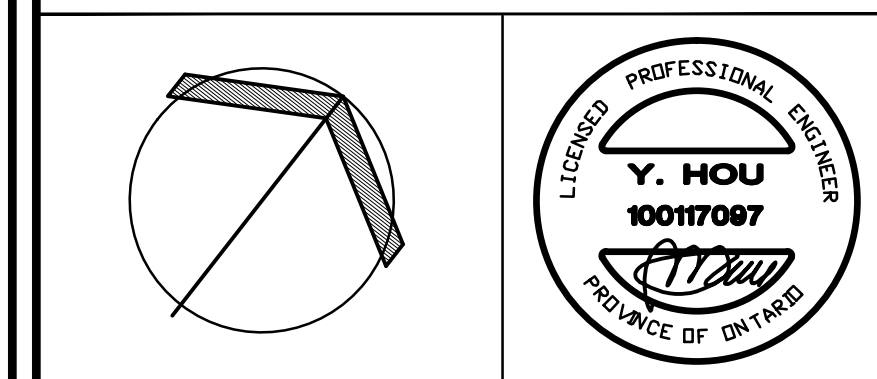

UNITED ENGINEERING INC.
Mechanical Electrical Consulting Engineers
3645 Keele Street, Suite 105,
Toronto, Ontario, M3J 1M6
Tel: (416) 398 1999, Fax: (416) 398 1933


TITLE
**PARKING LEVEL - HVAC
MECHANICAL - PART 2**

PROJECT

**BRAMPTON STACKED
FORESTSIDE ESTATES**

**ATTMAR + PALLESCI DRIVE
BRAMPTON, ONTARIO**

DRAWN MC	CHECKED LM	SCALE 1:100
DATE MAY, 2019	PROJECT 18-017	DRAWING M-4B
		OF

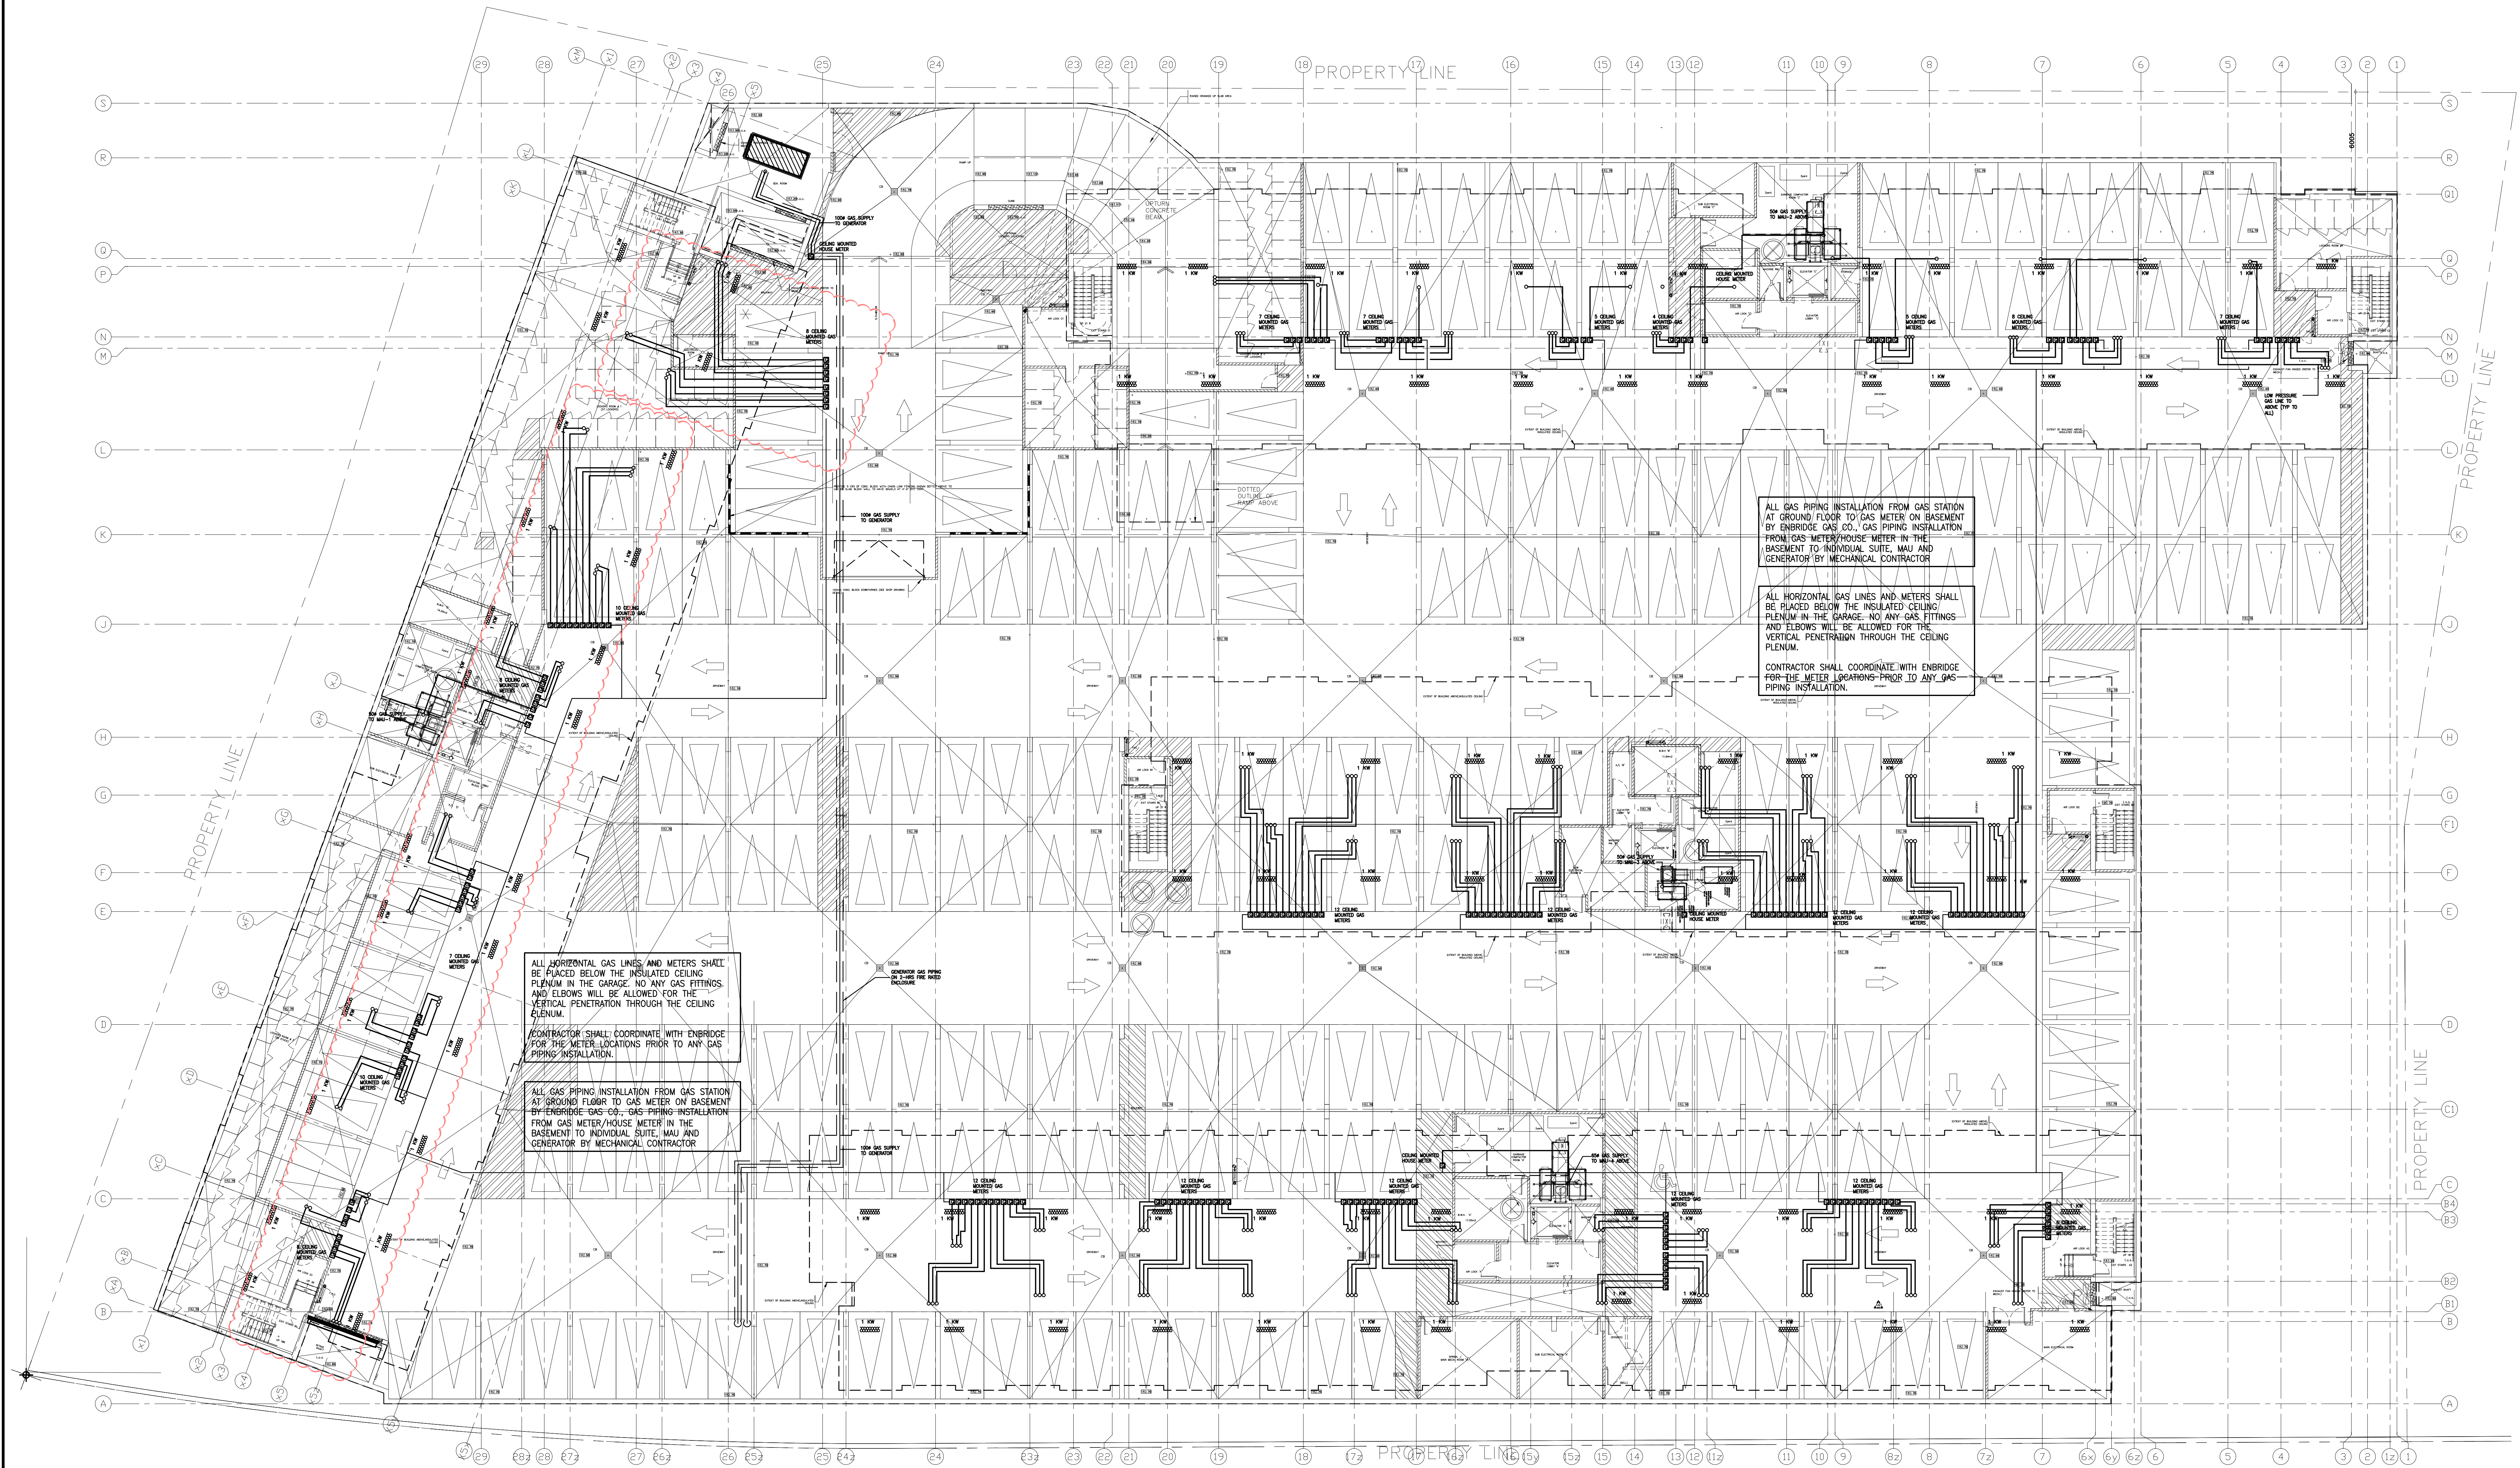

ALL HORIZONTAL GAS LINES AND METERS SHALL BE PLACED BELOW THE INSULATED CEILING PLENUM IN THE GARAGE. NO ANY GAS FITTINGS AND ELBOWS WILL BE ALLOWED FOR THE VERTICAL PENETRATION THROUGH THE CEILING PLENUM.

CONTRACTOR SHALL COORDINATE WITH ENBRIDGE FOR THE METER LOCATIONS PRIOR TO ANY GAS PIPING INSTALLATION.

ALL GAS PIPING INSTALLATION FROM GAS STATION AT GROUND FLOOR TO GAS METER ON BASEMENT BY ENBRIDGE GAS CO. - GAS PIPING INSTALLATION FROM GAS METER/HOUSE METER IN THE BASEMENT TO INDIVIDUAL SUITE, MAU AND GENERATOR BY MECHANICAL CONTRACTOR

ALL GAS PIPING INSTALLATION FROM GAS STATION AT GROUND FLOOR TO GAS METER ON BASEMENT BY ENBRIDGE GAS CO. - GAS PIPING INSTALLATION FROM GAS METER/HOUSE METER IN THE BASEMENT TO INDIVIDUAL SUITE, MAU AND GENERATOR BY MECHANICAL CONTRACTOR

ALL HORIZONTAL GAS LINES AND METERS SHALL BE PLACED BELOW THE INSULATED CEILING PLENUM IN THE GARAGE. NO ANY GAS FITTINGS AND ELBOWS WILL BE ALLOWED FOR THE VERTICAL PENETRATION THROUGH THE CEILING PLENUM.

CONTRACTOR SHALL COORDINATE WITH ENBRIDGE FOR THE METER LOCATIONS PRIOR TO ANY GAS PIPING INSTALLATION.

NO.	BY	DESCRIPTION	DATE
07	LB	ISSUED AS PER SITE INSTRUCTION M-02	JUN. 04, 2021
06	LB	ISSUED FOR PROGRESSIVE CONSTRUCTION	MAR. 28, 2021
05	LB	ISSUED FOR PERMIT BUILDING A,B,C,D	MAR. 03, 2021
04	LB	ISSUED AS PER ADDENDUM M-05	JAN. 20, 2021
03	LB	ISSUED FOR PERMIT	SEP. 28, 2020
02	RC	ADDENDUM #04	JUN. 12, 2020
01	RC	ISSUED FOR TENDER	AUG. 02, 2019


REVISIONS

This drawing is an instrument of service, is provided by and is the property of United Engineering Inc. The contractor must verify and accept responsibility for all dimensions and conditions on site and must notify United Engineering Inc. of any discrepancy before proceeding.

United Engineering Inc. is not responsible for the accuracy of Architectural, structural, interior design, etc., on this drawing.

Refer to the appropriate trade drawings before proceeding with any work. Installation must conform to all applicable codes and requirements of the authorities having jurisdiction.

This drawing is not to be scaled, all symbols are graphic representations only.

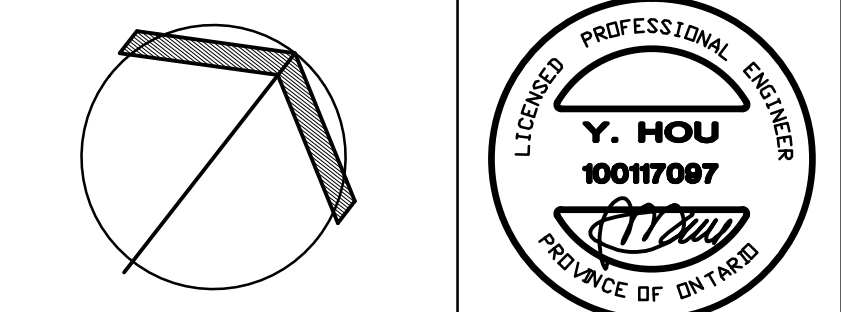

UNITED ENGINEERING INC.
Mechanical Electrical Consulting Engineers
3645 Keele Street, Suite 105,
Toronto, Ontario, M3J 1M6
Tel: (416) 398 1999, Fax: (416) 398 1933

TITLE
PARKING LEVEL - HVAC + GAS MECHANICAL

PROJECT
BRAMPTON STACKED FORESTSIDE ESTATES
ATTMAR + PALLESCI DRIVE
BRAMPTON, ONTARIO

DRAWN MC	CHECKED LM	SCALE 1:150
DATE MAY, 2019	PROJECT 18-017	DRAWING M-4C OF -



NO.	BY	DESCRIPTION	DATE
07	LB	ISSUED AS PER SITE INSTRUCTION M-02	JUN. 04, 2021
06	LB	ISSUED FOR PROGRESSIVE CONSTRUCTION	MAR. 28, 2021
05	LB	ISSUED FOR PERMIT BUILDING A.B.C.D	MAR. 03, 2021
04	LB	ISSUED AS PER ADDENDUM M-05	JAN. 20, 2021
03	LB	ISSUED FOR PERMIT	SEP. 28, 2020
02	RC	ADDENDUM #04	JUN. 12, 2020
01	RC	ISSUED FOR TENDER	AUG. 02, 2019


REVISIONS

This drawing is an instrument of service, is provided by and is the property of United Engineering Inc. The contractor must verify and accept responsibility for all dimensions and conditions on site and must notify United Engineering Inc. of any discrepancy before proceeding.

United Engineering Inc. is not responsible for the accuracy of Architectural, structural, interior design, etc., on this drawing.

Refer to the appropriate trade drawings before proceeding with any work. Installation must conform to all applicable codes and requirements of the authorities having jurisdiction.

This drawing is not to be scaled, all symbols are graphic representations only.

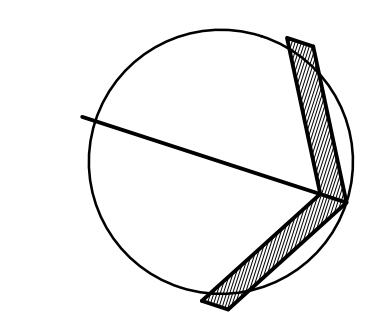

UNITED ENGINEERING INC.
Mechanical Electrical Consulting Engineers
3645 Keele Street, Suite 105,
Toronto, Ontario, M3J 1M6
Tel: (416) 398 1999, Fax: (416) 398 1933


TITLE
**BLOCK 'D'
GROUND FLOOR - PLUMBING/SANITARY**

PROJECT

**BRAMPTON STACKED
FORESTSIDE ESTATES**

**ATTMAR + PALLESCI DRIVE
BRAMPTON, ONTARIO**

DRAWN MC	CHECKED LM	SCALE 1:50
DATE MAY, 2019	PROJECT 18-017	DRAWING M-5
		OF -

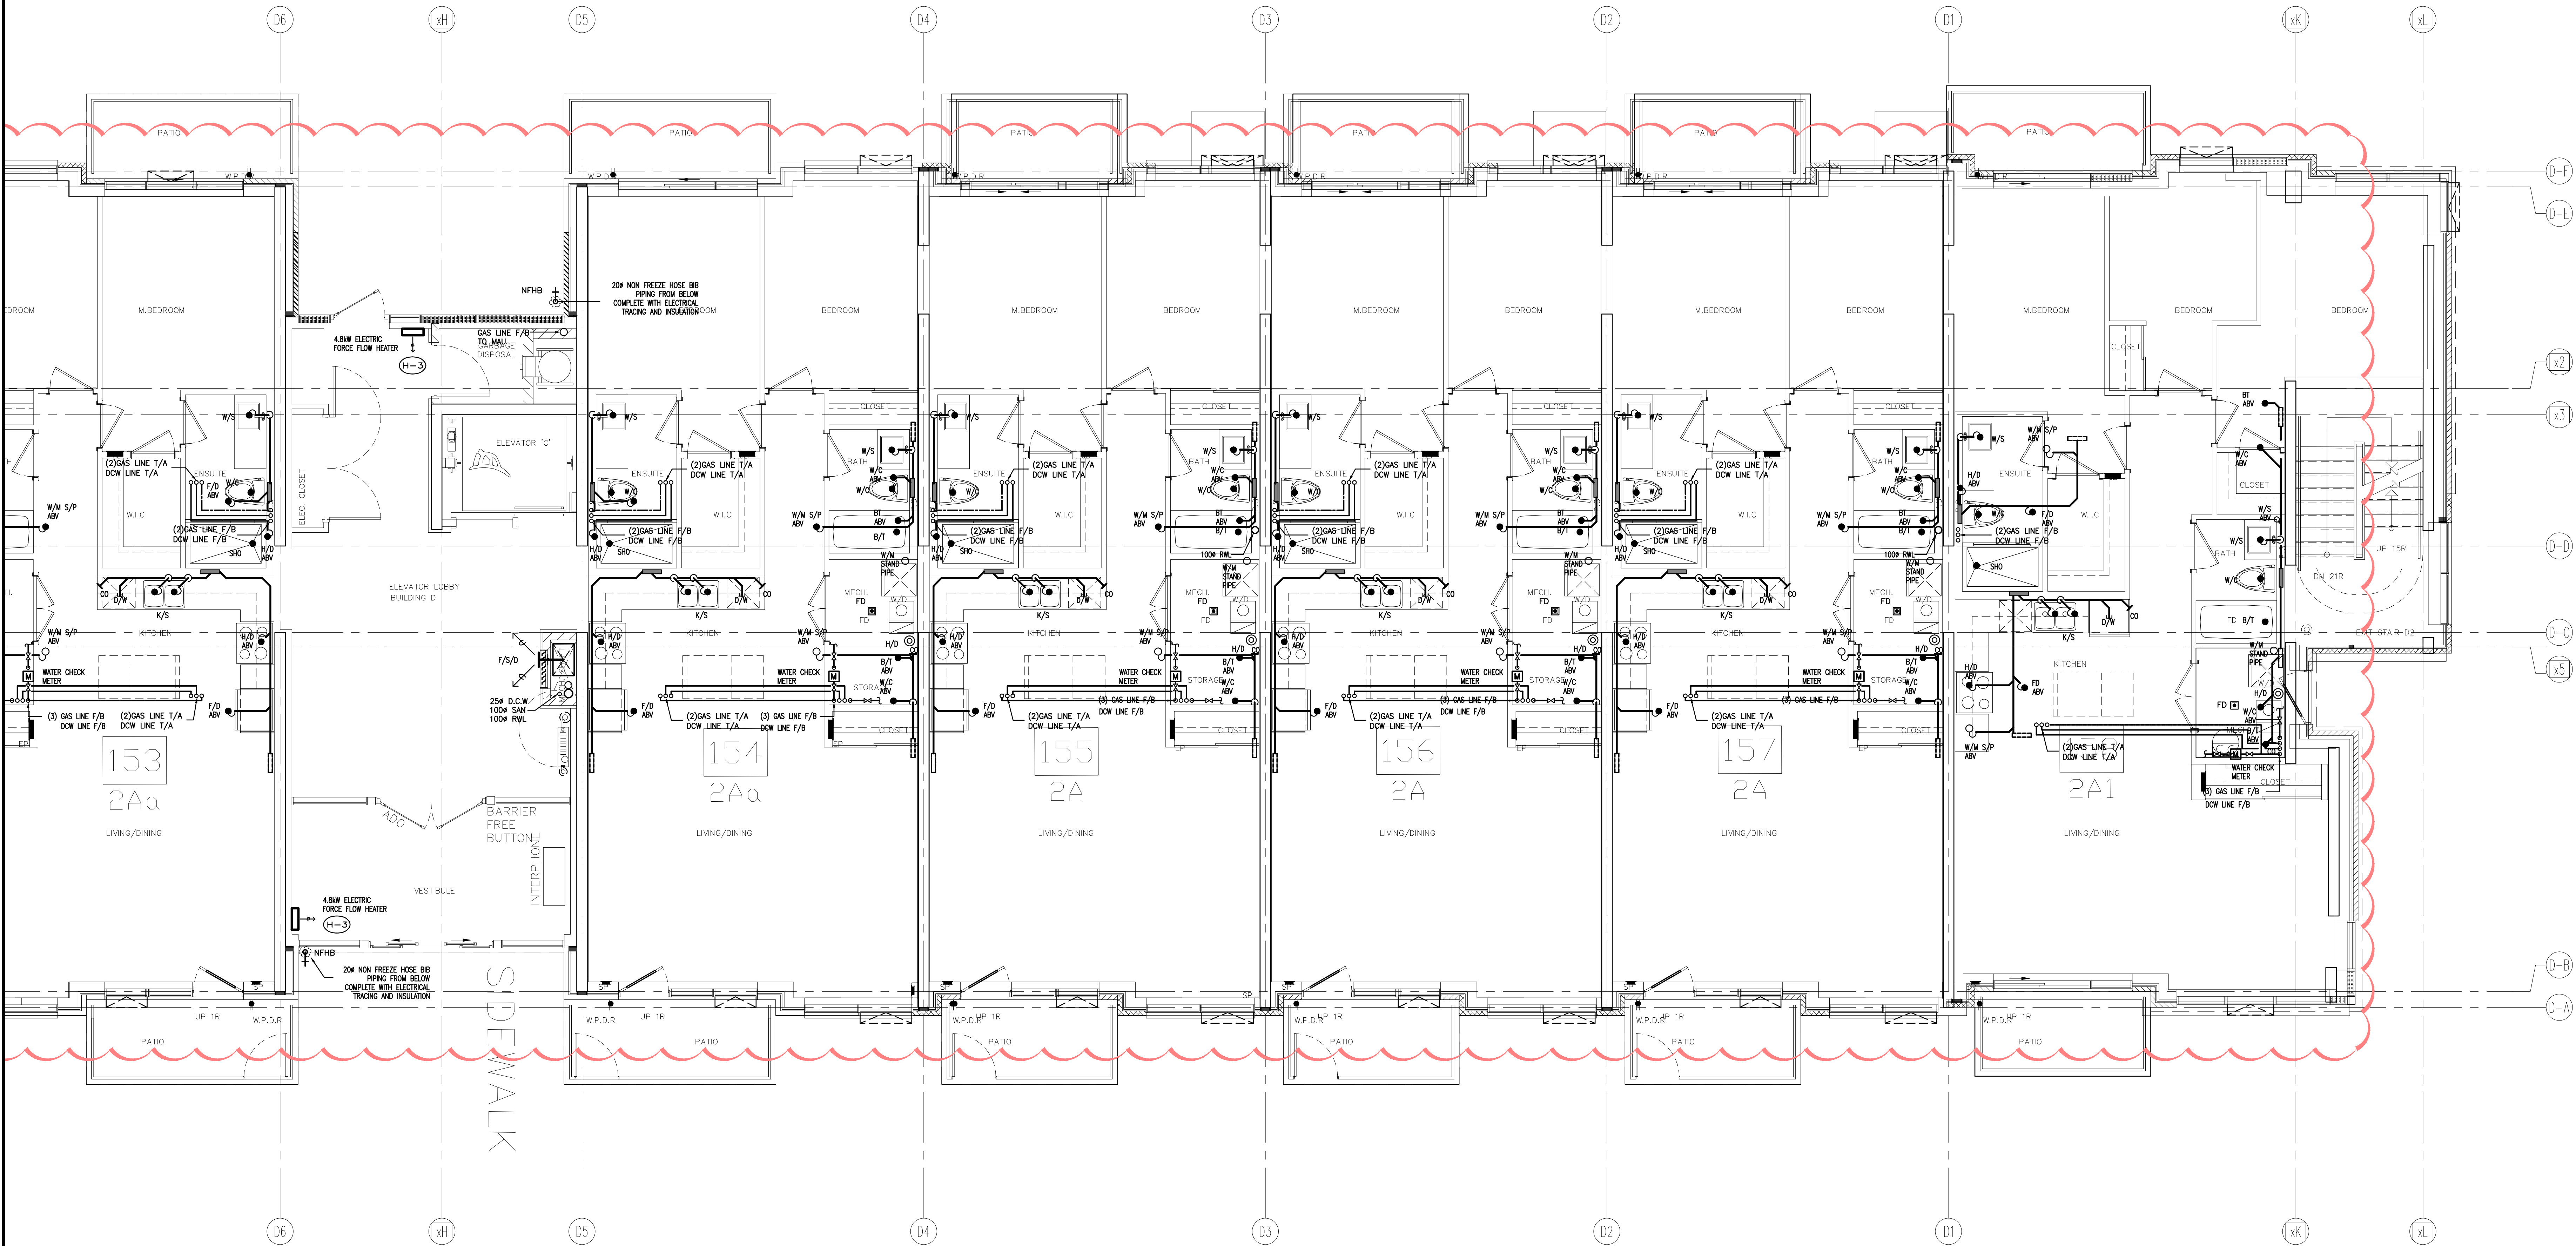

NO.	BY	DESCRIPTION	DATE
08	LB	ISSUED AS PER SITE INSTRUCTION M-02	JUN. 04, 2021
07	LB	ISSUED FOR PROGRESSIVE CONSTRUCTION	MAR. 26, 2021
06	LB	ISSUED AS PER ADDENDUM M-06	MAR. 25, 2021
05	LB	ISSUED FOR PERMIT BUILDING A,B,C,D	MAR. 03, 2021
04	LB	ISSUED AS PER ADDENDUM M-05	JAN. 20, 2021
03	LB	ISSUED FOR PERMIT	SEP. 28, 2020
02	RC	ADDENDUM #04	JUN. 12, 2020
01	RC	ISSUED FOR TENDER	AUG. 02, 2019


REVISIONS

This drawing is an instrument of service, is provided by and is the property of United Engineering Inc. The contractor must verify and accept responsibility for all dimensions and conditions on site and must notify United Engineering Inc. of any discrepancy before proceeding.

United Engineering Inc. is not responsible for the accuracy of Architectural, structural, interior design, etc., on this drawing.

Refer to the appropriate trade drawings before proceeding with any work. Installation must conform to all applicable codes and requirements of the authorities having jurisdiction.

This drawing is not to be scaled, all symbols are graphic representations only.

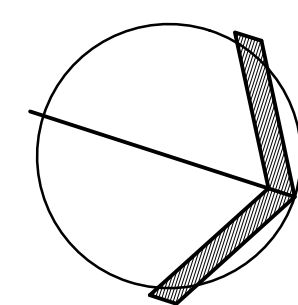

UNITED ENGINEERING INC.
Mechanical Electrical Consulting Engineers
3645 Keele Street, Suite 105,
Toronto, Ontario, M3J 1M6
Tel: (416) 398 1999, Fax: (416) 398 1933

TITLE
**BLOCK 'D'
GROUND FLOOR - PLUMBING/SANITARY**

PROJECT

**BRAMPTON STACKED
FORESTSIDE ESTATES**

**ATTMAR + PALLESCI DRIVE
BRAMPTON, ONTARIO**


DRAWN	CHECKED	SCALE
MC	LM	1:50
DATE	PROJECT	DRAWING
MAY, 2019	18-017	M-6
		OF



NO.	BY	DESCRIPTION	DATE
07	LB	ISSUED AS PER SITE INSTRUCTION M-02	JUN. 04, 2021
06	LB	ISSUED FOR PROGRESSIVE CONSTRUCTION	MAR. 26, 2021
05	LB	ISSUED FOR PERMIT BUILDING A,B,C,D	MAR. 03, 2021
04	LB	ISSUED AS PER ADDENDUM M-05	JAN. 20, 2021
03	LB	ISSUED FOR PERMIT	SEP. 28, 2020
02	RC	ADDENDUM #04	JUN. 12, 2020
01	RC	ISSUED FOR TENDER	AUG. 02, 2019

REVISIONS

This drawing, is an instrument of service, is provided by and is the property of United Engineering Inc. The contractor must verify and accept responsibility for all dimensions and conditions on site and must notify United Engineering Inc. of any discrepancy before proceeding.
United Engineering Inc. is not responsible for the accuracy of Architectural, structural, interior design, etc., on this drawing.
Refer to the appropriate trade drawings before proceeding with any work. Installation must conform to all applicable codes and requirements of the authorities having jurisdiction.
This drawing is not to be scaled, all symbols are graphic representations only.

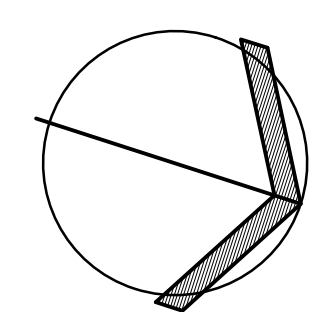

UNITED ENGINEERING INC.
Mechanical Electrical Consulting Engineers
3645 Keele Street, Suite 105,
Toronto, Ontario, M3J 1M6
Tel: (416) 398 1999, Fax: (416) 398 1933

TITLE BLOCK 'D' 2ND FLOOR - PLUMBING/SANITARY		
PROJECT BRAMPTON STACKED FORESTSIDE ESTATES		
ATTMAY + PALLESCI DRIVE BRAMPTON, ONTARIO		
DRAWN MC	CHECKED LM	SCALE 1:50
DATE MAY, 2019	PROJECT 18-017	DRAWING M-7 OF -



NO.	BY	DESCRIPTION	DATE
01	RC	ISSUED FOR TENDER	AUG. 02, 2019
02	RC	ADDENDUM #04	JUN. 12, 2020
03	LB	ISSUED FOR PERMIT	SEP. 28, 2020
04	LB	ISSUED AS PER ADDENDUM M-05	JAN. 20, 2021
05	LB	ISSUED FOR PERMIT BUILDING A,B,C,D	MAR. 03, 2021
06	LB	ISSUED FOR PROGRESSIVE CONSTRUCTION	MAR. 28, 2021
07	LB	ISSUED AS PER SITE INSTRUCTION M-02	JUN. 04, 2021


REVISIONS

This drawing is an instrument of service, is provided by and is the property of United Engineering Inc. The contractor must verify and accept responsibility for all dimensions and conditions on site and must notify United Engineering Inc. of any discrepancy before proceeding.

United Engineering Inc. is not responsible for the accuracy of Architectural, structural, interior design, etc., on this drawing.

Refer to the appropriate trade drawings before proceeding with any work. Installation must conform to all applicable codes and requirements of the authorities having jurisdiction.

This drawing is not to be scaled, all symbols are graphic representations only.

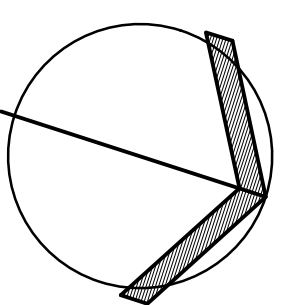

UNITED ENGINEERING INC.
Mechanical Electrical Consulting Engineers
3645 Keele Street, Suite 105,
Toronto, Ontario, M3J 1M6
Tel: (416) 398 1599, Fax: (416) 398 1933


TITLE
BLOCK 'D'
3RD FLOOR - PLUMBING/SANITARY

PROJECT

**BRAMPTON STACKED
FORESTSIDE ESTATES**

**ATTMAR + PALLESCI DRIVE
BRAMPTON, ONTARIO**

DRAWN MC	CHECKED LM	SCALE 1:50
DATE MAY, 2019	PROJECT 18-017	DRAWING M-9 OF -

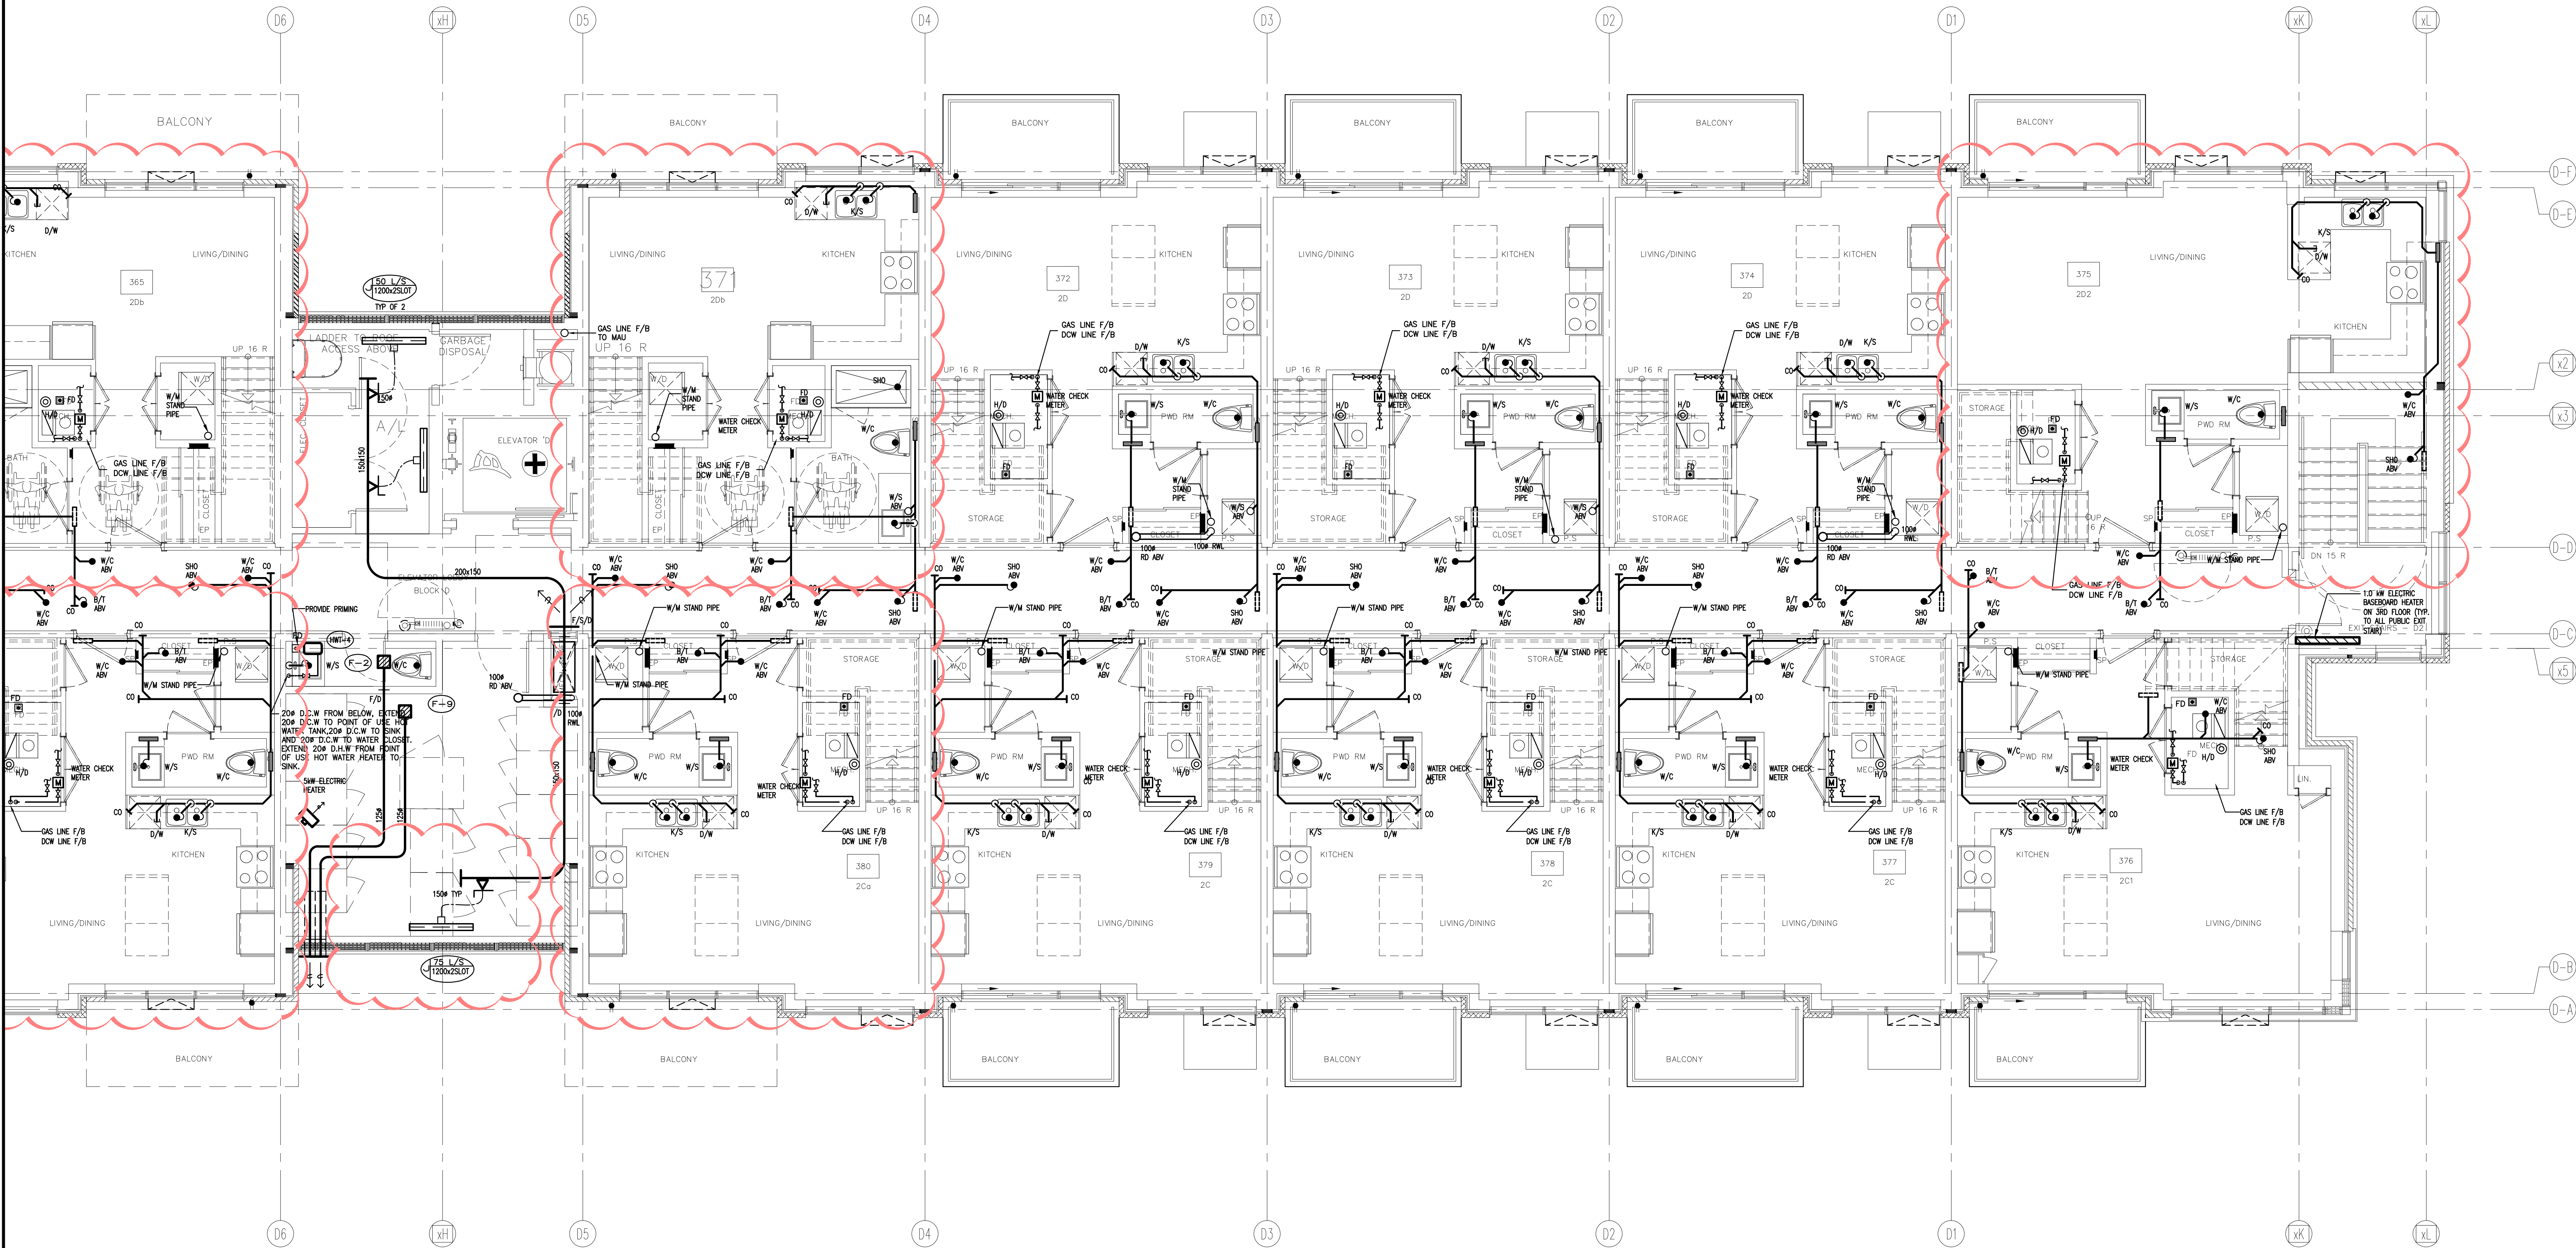

NO.	BY	DESCRIPTION	DATE
08	LB	ISSUED AS PER SITE INSTRUCTION M-02	JUN. 04, 2021
07	LB	ISSUED FOR PROGRESSIVE CONSTRUCTION	MAR. 26, 2021
06	LB	ISSUED AS PER ADDENDUM M-06	MAR. 25, 2021
05	LB	ISSUED FOR PERMIT BUILDING A,B,C,D	MAR. 03, 2021
04	LB	ISSUED AS PER ADDENDUM M-05	JAN. 20, 2021
03	LB	ISSUED FOR PERMIT	SEP. 28, 2020
02	RC	ADDENDUM #04	JUN. 12, 2020
01	RC	ISSUED FOR TENDER	AUG. 02, 2019



REVISIONS

This drawing, is an instrument of service, is provided by and is the property of United Engineering Inc. The contractor must verify and accept responsibility for all dimensions and conditions on site and must notify United Engineering Inc. of any discrepancy before proceeding.

United Engineering Inc. is not responsible for the accuracy of Architectural, structural, interior design, etc., on this drawing.

Refer to the appropriate trade drawings before proceeding with any work. Installation must conform to all applicable codes and requirements of the authorities having jurisdiction.

This drawing is not to be scaled, all symbols are graphic representations only.

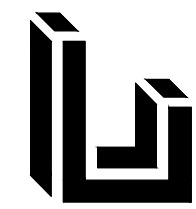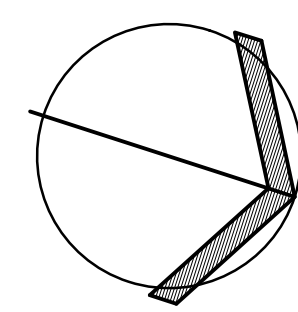

UNITED ENGINEERING INC.
Mechanical Electrical Consulting Engineers
3645 Keele Street, Suite 105,
Toronto, Ontario, M3J 1M6
Tel: (416) 398 1999, Fax: (416) 398 1933


TITLE
**BLOCK 'D'
3RD FLOOR - PLUMBING/SANITARY**

PROJECT

**BRAMPTON STACKED
FORESTSIDE ESTATES**

**ATTMAR + PALLESCI DRIVE
BRAMPTON, ONTARIO**

DRAWN MC	CHECKED LM	SCALE 1:50
DATE MAY, 2019	PROJECT 18-017	DRAWING M-10 OF -

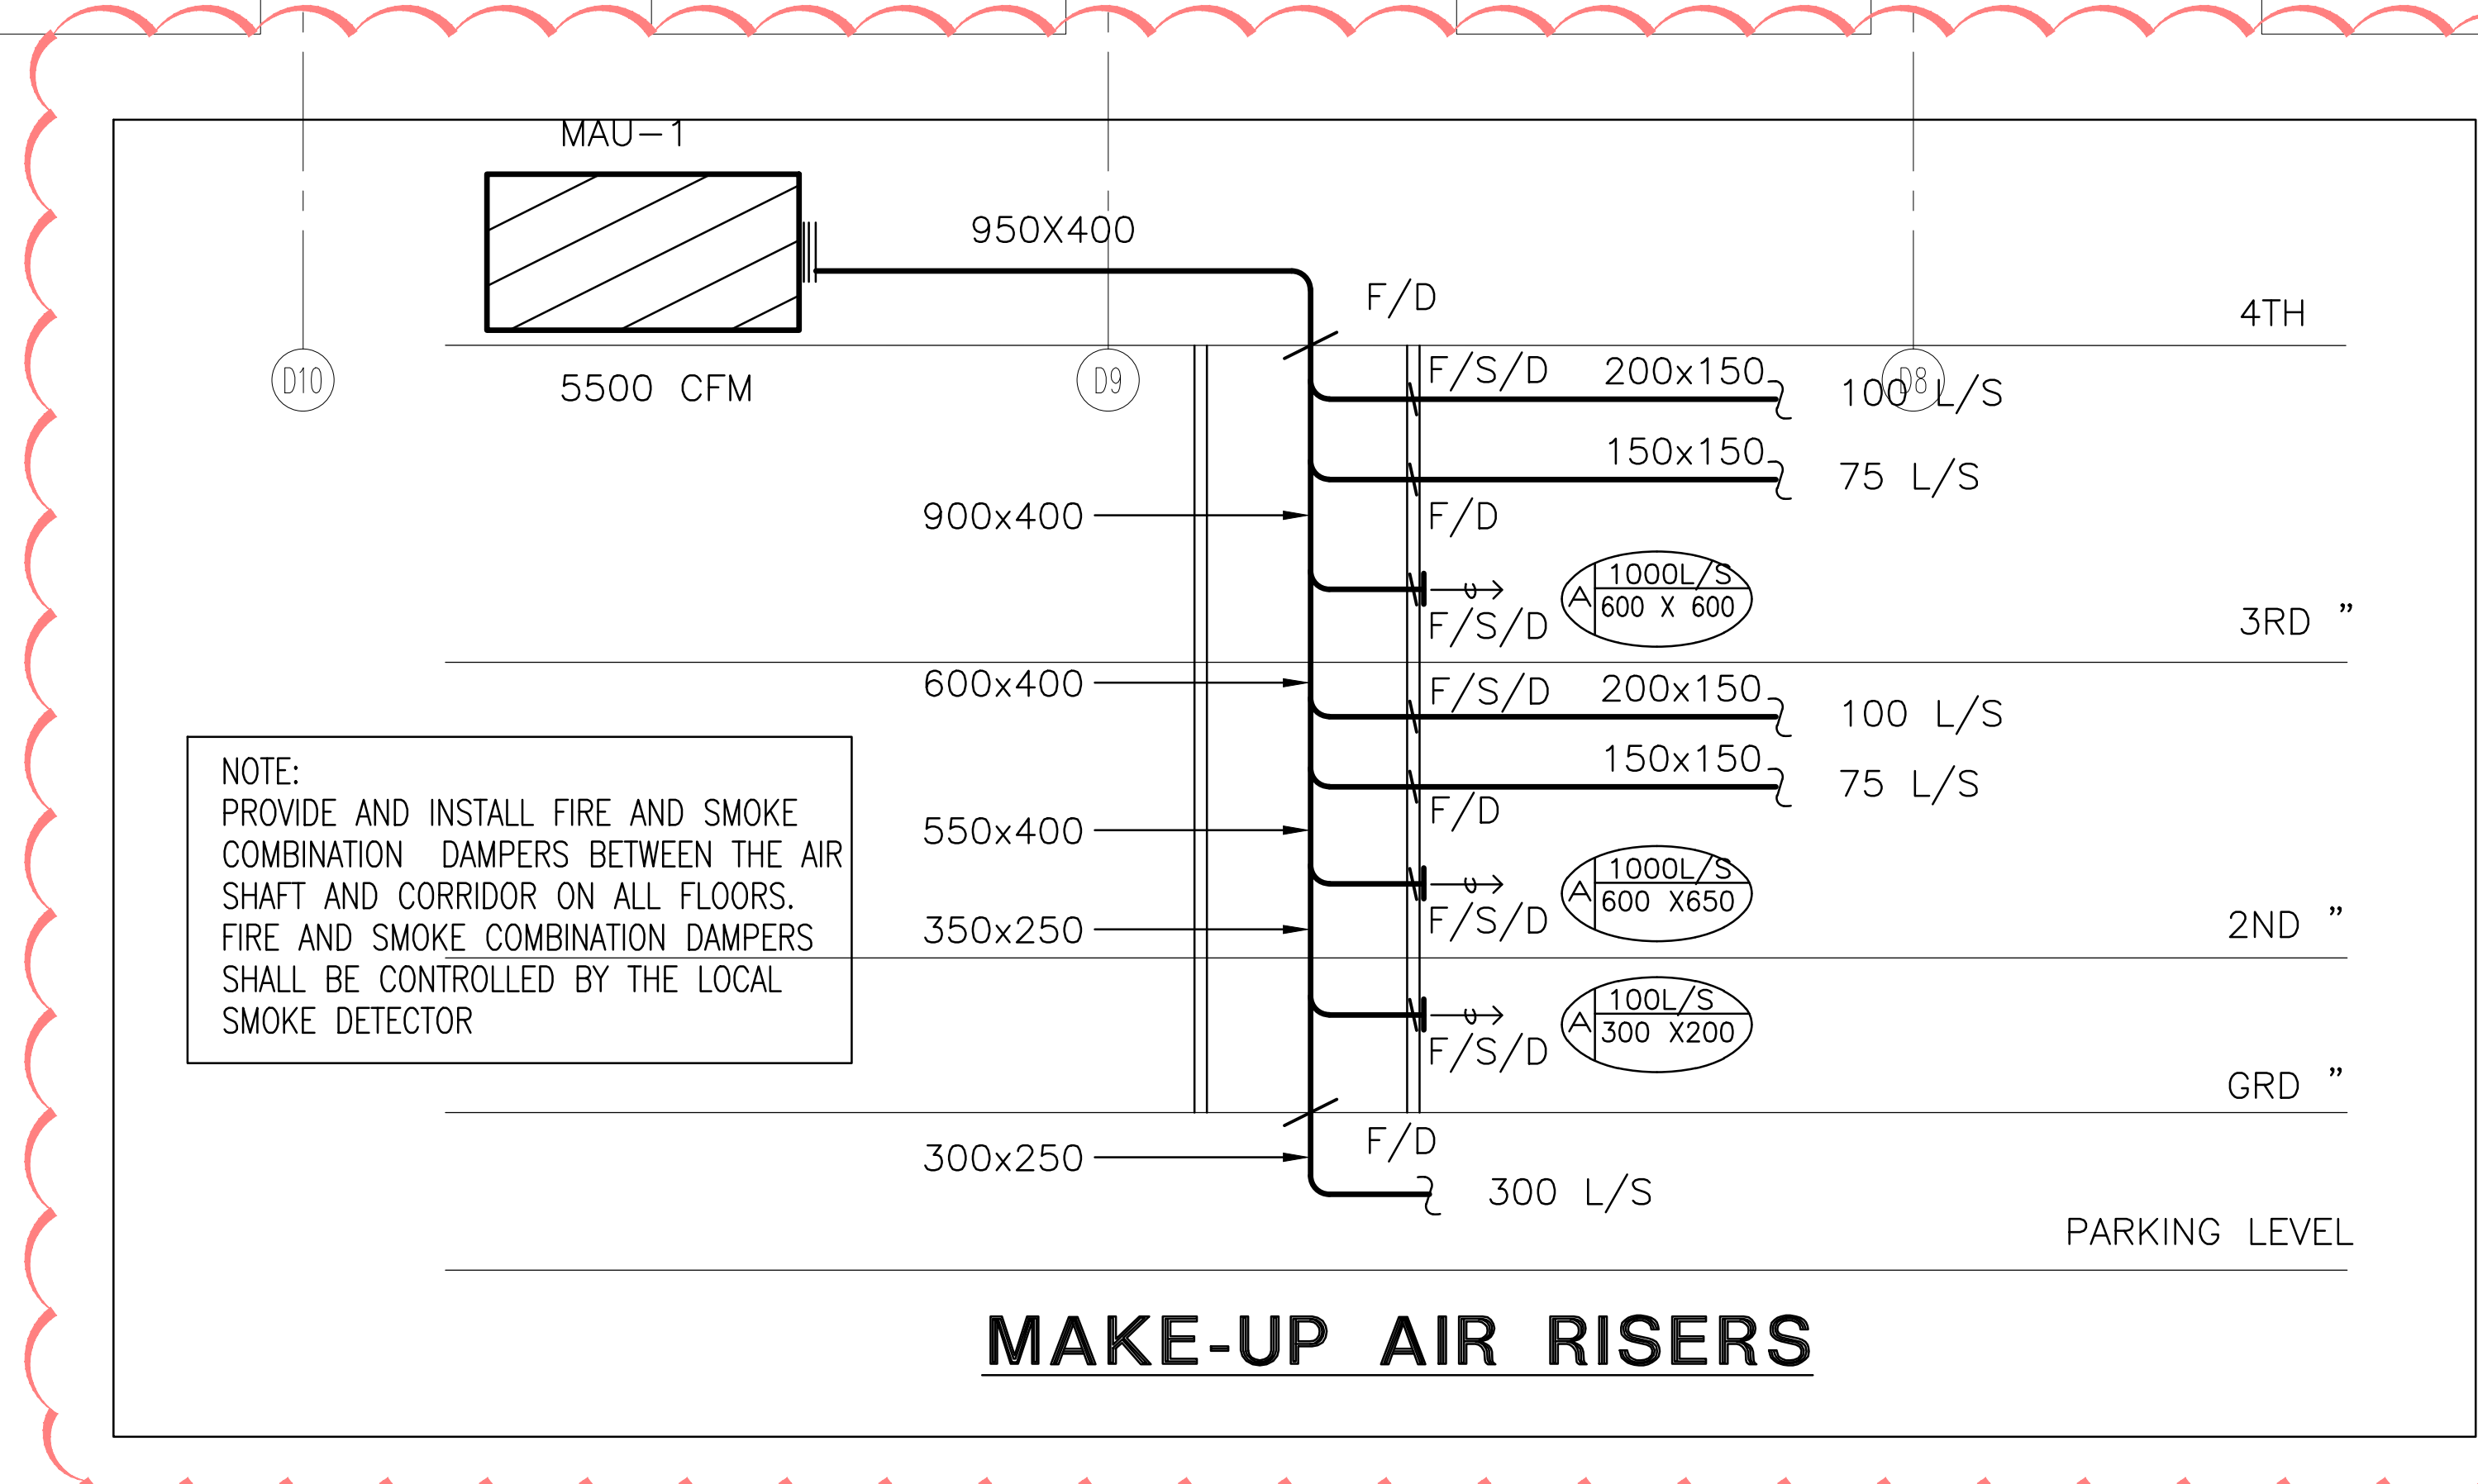


09	LB	ISSUED AS PER SITE INSTRUCTION M-02	JUN. 04, 2021
08	LB	ISSUED AS PER SITE INSTRUCTION M-01	APR. 28, 2021
07	LB	ISSUED FOR PROGRESSIVE CONSTRUCTION	MAR. 26, 2021
06	LB	ISSUED AS PER ADDENDUM M-06	MAR. 25, 2021
05	LB	ISSUED FOR PERMIT BUILDING A,B,C,D	MAR. 03, 2021
04	LB	ISSUED AS PER ADDENDUM M-05	JAN. 20, 2021
03	LB	ISSUED FOR PERMIT	SEP. 28, 2020
02	RC	ADDENDUM #04	JUN. 12, 2020
01	RC	ISSUED FOR TENDER	AUG. 02, 2019
NO.	BY	DESCRIPTION	DATE

This drawing, is an instrument of service, is provided by and is the property of United Engineering Inc. The contractor must verify and accept responsibility for all dimensions and conditions on site and must notify United Engineering Inc. of any discrepancy before proceeding.

United Engineering Inc. is not responsible for the accuracy of Architectural, structural, interior design, etc. on this drawing.

Refer to the appropriate trade drawings before proceeding with any work. Installation must conform to all applicable codes and requirements of all the authorities having jurisdiction.

This drawing is not to be scaled, all symbols are graphic representations only.

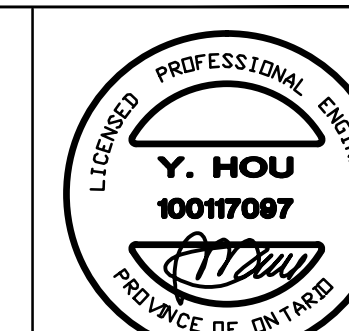

DRAWN MC	CHECKED LM	SCALE 1:50
DATE MAY, 2019	PROJECT 18-017	DRAWING M-11
		OF




4TH FLOOR LOBBY ENTRANCE BUILDING D

NO.	BY	DESCRIPTION	DATE
08	LB	ISSUED AS PER SITE INSTRUCTION M-02	JUN. 04, 2021
07	LB	ISSUED FOR PROGRESSIVE CONSTRUCTION	MAR. 26, 2021
06	LB	ISSUED AS PER ADDENDUM M-06	MAR. 25, 2021
05	LB	ISSUED FOR PERMIT BUILDING A.B.C.D	MAR. 03, 2021
04	LB	ISSUED AS PER ADDENDUM M-05	JAN. 20, 2021
03	LB	ISSUED FOR PERMIT	SEP. 28, 2020
02	RC	ADDENDUM #04	JUN. 12, 2020
01	RC	ISSUED FOR TENDER	AUG. 02, 2019

REVISIONS

This drawing is an instrument of service, is provided by and is the property of United Engineering Inc. The contractor must verify and accept responsibility for all dimensions and conditions on site and must notify United Engineering Inc. of any discrepancy before proceeding. United Engineering Inc. is not responsible for the accuracy of Architectural, structural, interior design, etc., on this drawing. Refer to the appropriate trade drawings before proceeding with any work. Installation must conform to all applicable codes and requirements of the authorities having jurisdiction. This drawing is not to be scaled, all symbols are graphic representations only.

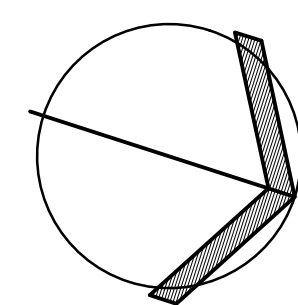

UNITED ENGINEERING INC.
Mechanical Electrical Consulting Engineers
3645 Keele Street, Suite 105,
Toronto, Ontario, M3J 1M6
Tel: (416) 398 1999, Fax: (416) 398 1933


TITLE
**BLOCK 'D'
3RD FLOOR - PLUMBING/SANITARY**

PROJECT

**BRAMPTON STACKED
FORESTSIDE ESTATES**

**ATTMAR + PALLESCHI DRIVE
BRAMPTON, ONTARIO**

DRAWN	CHECKED	SCALE
MC	LM	1:50
DATE	PROJECT	DRAWING
MAY, 2019	18-017	M-12
		OF

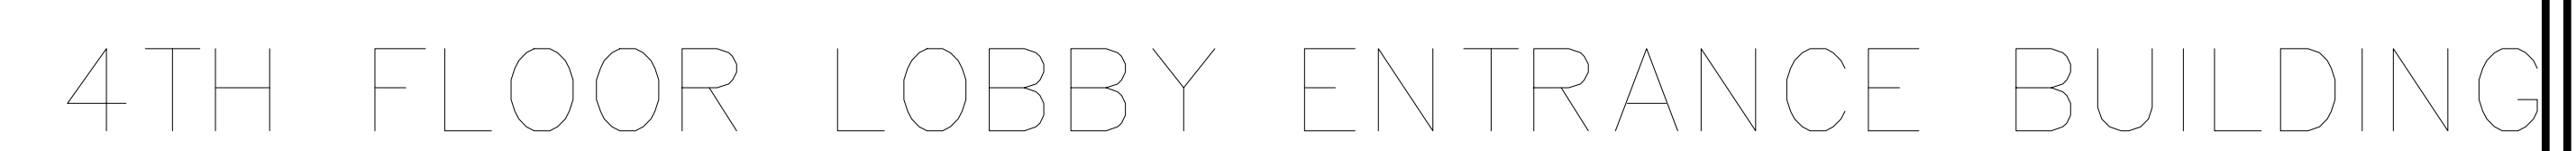

REVISIONS	
-----------	--

This drawing, is an instrument of service, is provided by and is the property of United Engineering Inc. The contractor must verify and accept responsibility for all dimensions and conditions on site and must notify United Engineering Inc. of any discrepancy before proceeding.

United Engineering Inc. is not responsible for the accuracy of Architectural, structural, interior design, etc. on this drawing.

Refer to the appropriate trade drawings before proceeding with any work. Installation must conform to all applicable codes and requirements of the authorities having jurisdiction.

This drawing is not to be scaled, all symbols are graphic representations only.




UNITED ENGINEERING INC.
 Mechanical Electrical Consulting Engineers
 3645 Keele Street, Suite 105,
 Toronto, Ontario, M3J 1M6
 Tel: (416) 398 1999, Fax: (416) 398 1933

TITLE	BLOCK 'D' ROOF - PLUMBING/SANITARY
-------	---------------------------------------

**BRAMPTON STACKED
FORESTSIDE ESTATES**

ATTMAR + PALLESCHI DRIVE
BRAMPTON, ONTARIO

DRAWN MC	CHECKED LM	SCALE 1:50
DATE MAY, 2019	PROJECT 18-017	DRAWING M-13
		OF

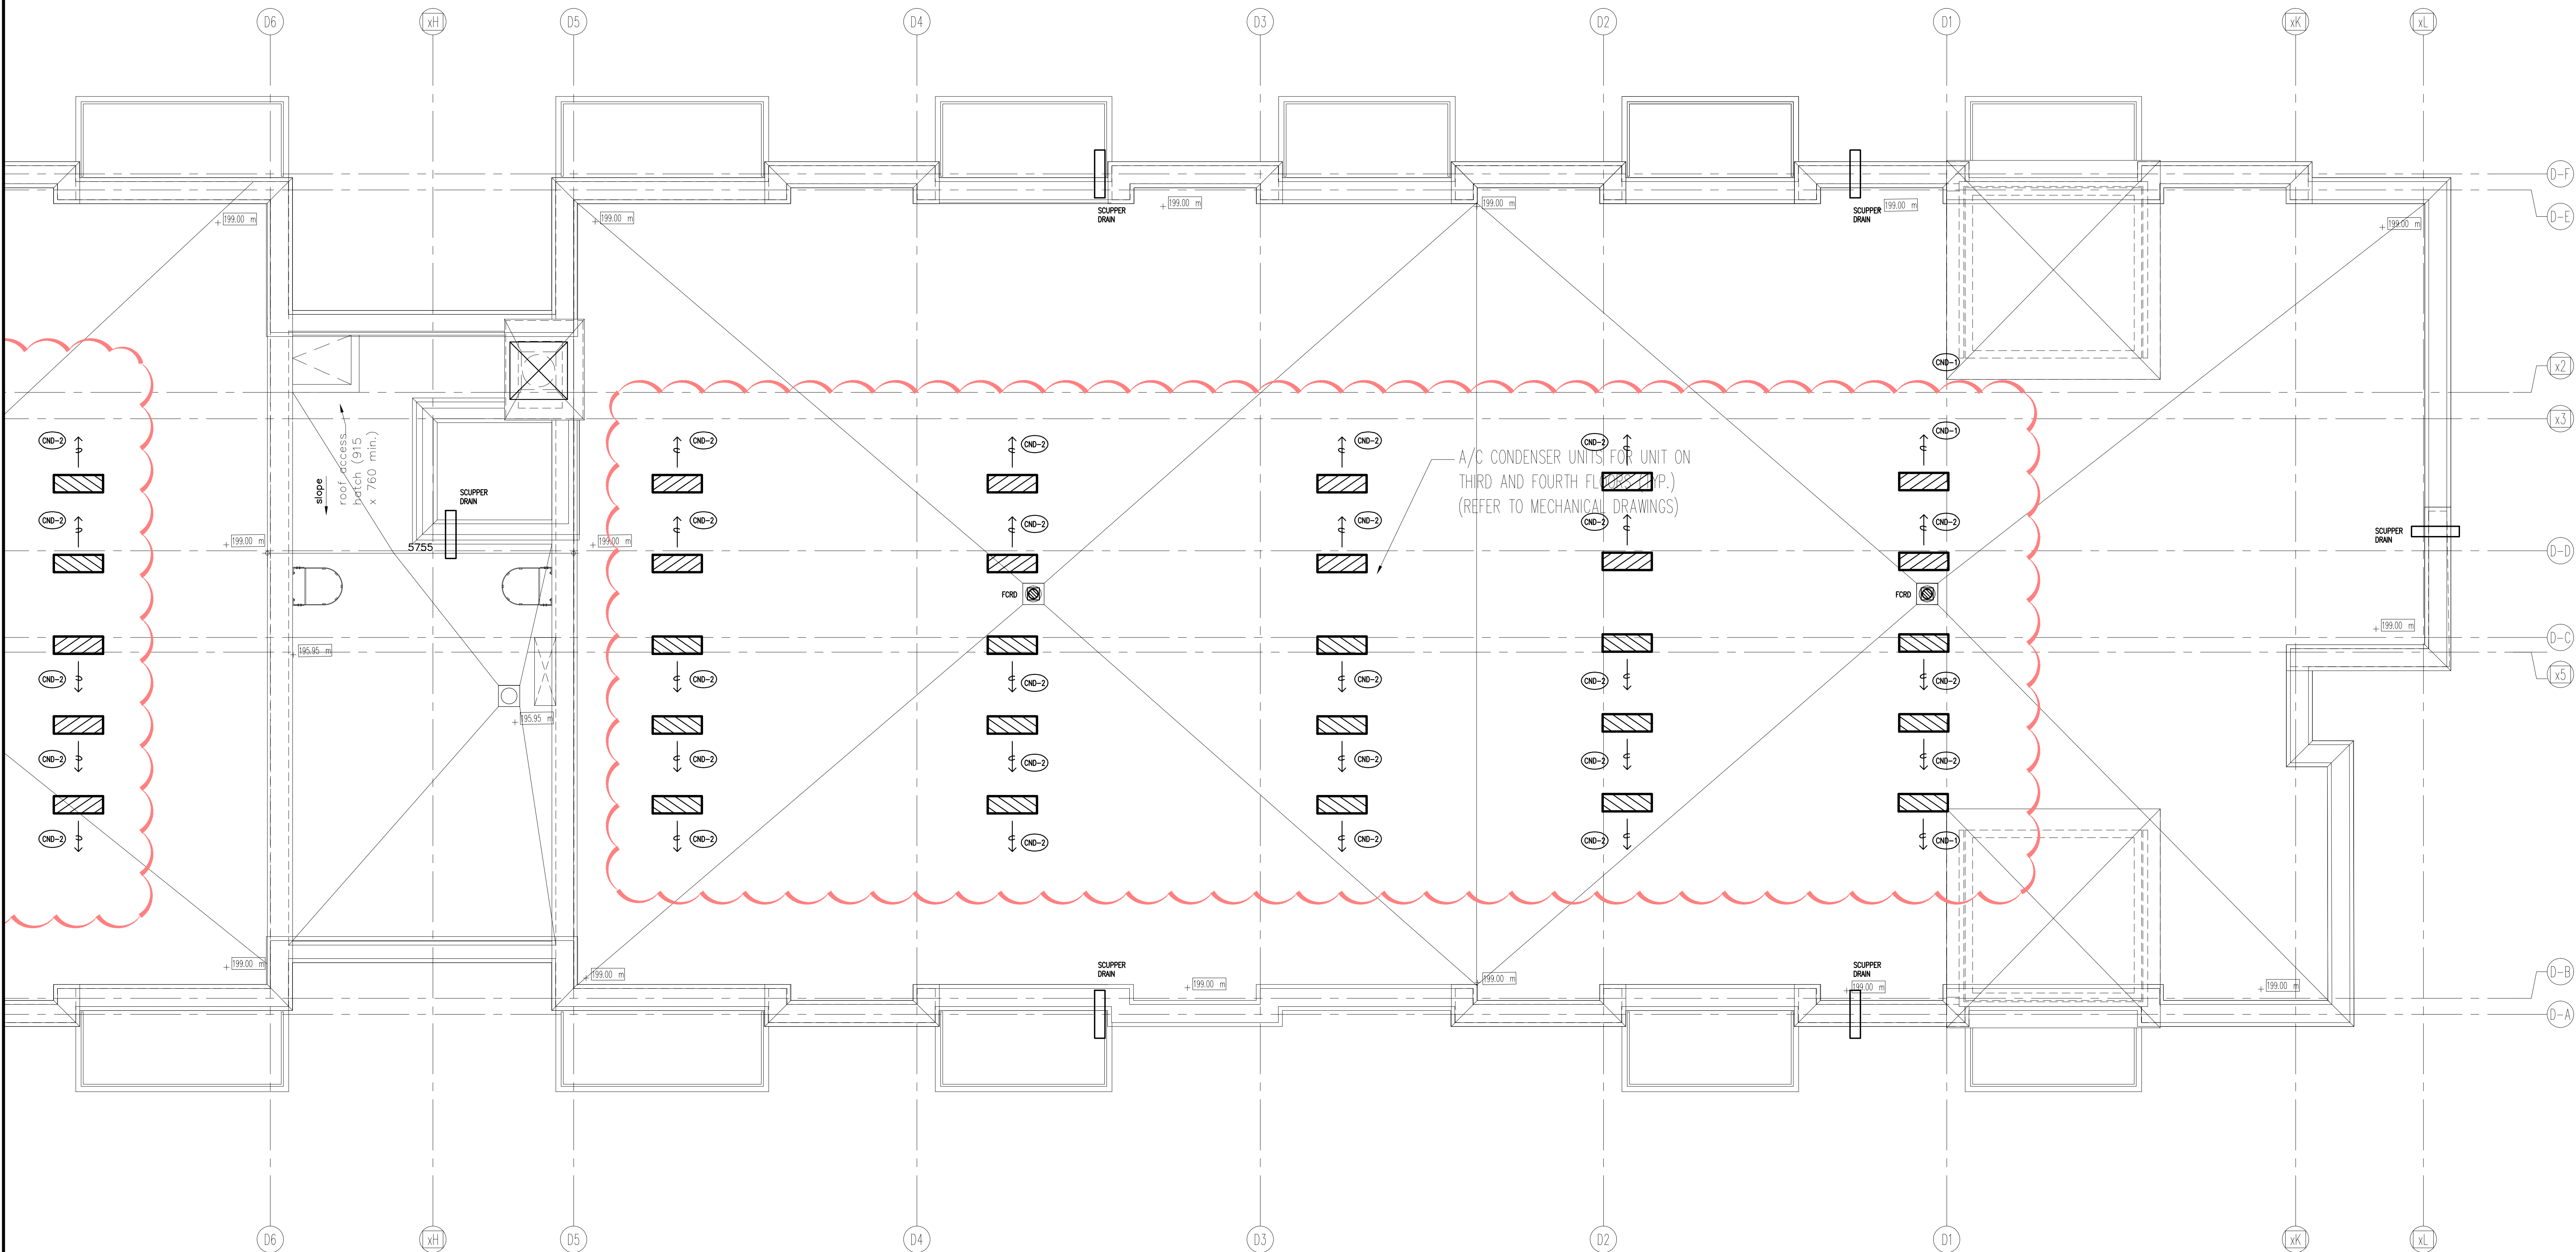


TH FLOOR LOBBY ENTRANCE BUILDING D

NO.	BY	DESCRIPTION	DATE
07	LB	ISSUED AS PER SITE INSTRUCTION M-02	JUN. 04, 2021
06	LB	ISSUED FOR PROGRESSIVE CONSTRUCTION	MAR. 28, 2021
05	LB	ISSUED FOR PERMIT BUILDING A,B,C,D	MAR. 03, 2021
04	LB	ISSUED AS PER ADDENDUM M-05	JAN. 20, 2021
03	LB	ISSUED FOR PERMIT	SEP. 28, 2020
02	RC	ADDENDUM #04	JUN. 12, 2020
01	RC	ISSUED FOR TENDER	AUG. 02, 2019

REVISIONS

This drawing, is an instrument of service, is provided by and is the property of United Engineering Inc.. The contractor must verify and accept responsibility for all dimensions and conditions on site and must notify United Engineering Inc. of any discrepancy before proceeding. United Engineering Inc. is not responsible for the accuracy of Architectural, structural, interior design, etc., on this drawing. Refer to the appropriate trade drawings before proceeding with any work. Installation must conform to all applicable codes and requirements of the authorities having jurisdiction. This drawing is not to be scaled, all symbols are graphic representations only.

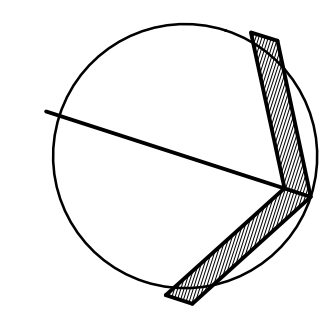

UNITED ENGINEERING INC.
Mechanical Electrical Consulting Engineers
3645 Keele Street, Suite 105,
Toronto, Ontario, M3J 1M6
Tel: (416) 398 1999, Fax: (416) 398 1933

TITLE
**BLOCK 'D'
ROOF - PLUMBING/SANITARY**

PROJECT

**BRAMPTON STACKED
FORESTSIDE ESTATES**

**ATTMAR + PALLESCHI DRIVE
BRAMPTON, ONTARIO**

DRAWN	CHECKED	SCALE
MC	LM	1:50
DATE	PROJECT	DRAWING
MAY, 2019	18-017	M-14 OF -



NO.	BY	DESCRIPTION	DATE
07	LB	ISSUED AS PER SITE INSTRUCTION M-02	JUN. 04, 2021
06	LB	ISSUED FOR PROGRESSIVE CONSTRUCTION	MAR. 28, 2021
05	LB	ISSUED FOR PERMIT BUILDING A,B,C,D	MAR. 03, 2021
04	LB	ISSUED AS PER ADDENDUM M-05	JAN. 20, 2021
03	LB	ISSUED FOR PERMIT	SEP. 28, 2020
02	RC	ADDENDUM #04	JUN. 12, 2020
01	RC	ISSUED FOR TENDER	AUG. 02, 2019


REVISIONS

This drawing is an instrument of service, is provided by and is the property of United Engineering Inc. The contractor must verify and accept responsibility for all dimensions and conditions on site and must notify United Engineering Inc. of any discrepancy before proceeding.

United Engineering Inc. is not responsible for the accuracy of Architectural, structural, interior design, etc., on this drawing.

Refer to the appropriate trade drawings before proceeding with any work. Installation must conform to all applicable codes and requirements of the authorities having jurisdiction.

This drawing is not to be scaled, all symbols are graphic representations only.

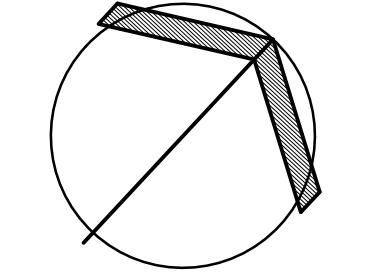

UNITED ENGINEERING INC.
Mechanical Electrical Consulting Engineers
3645 Keele Street, Suite 105,
Toronto, Ontario, M3J 1M6
Tel: (416) 398 1999, Fax: (416) 398 1933


TITLE
**BLOCK 'C'
GROUND FLOOR - PLUMBING/SANITARY**

PROJECT

**BRAMPTON STACKED
FORESTSIDE ESTATES**

**ATTMAR + PALLESCI DRIVE
BRAMPTON, ONTARIO**

DRAWN	CHECKED	SCALE
MC	LM	1:50
DATE	PROJECT	DRAWING
MAY, 2019	18-017	M-15
		OF

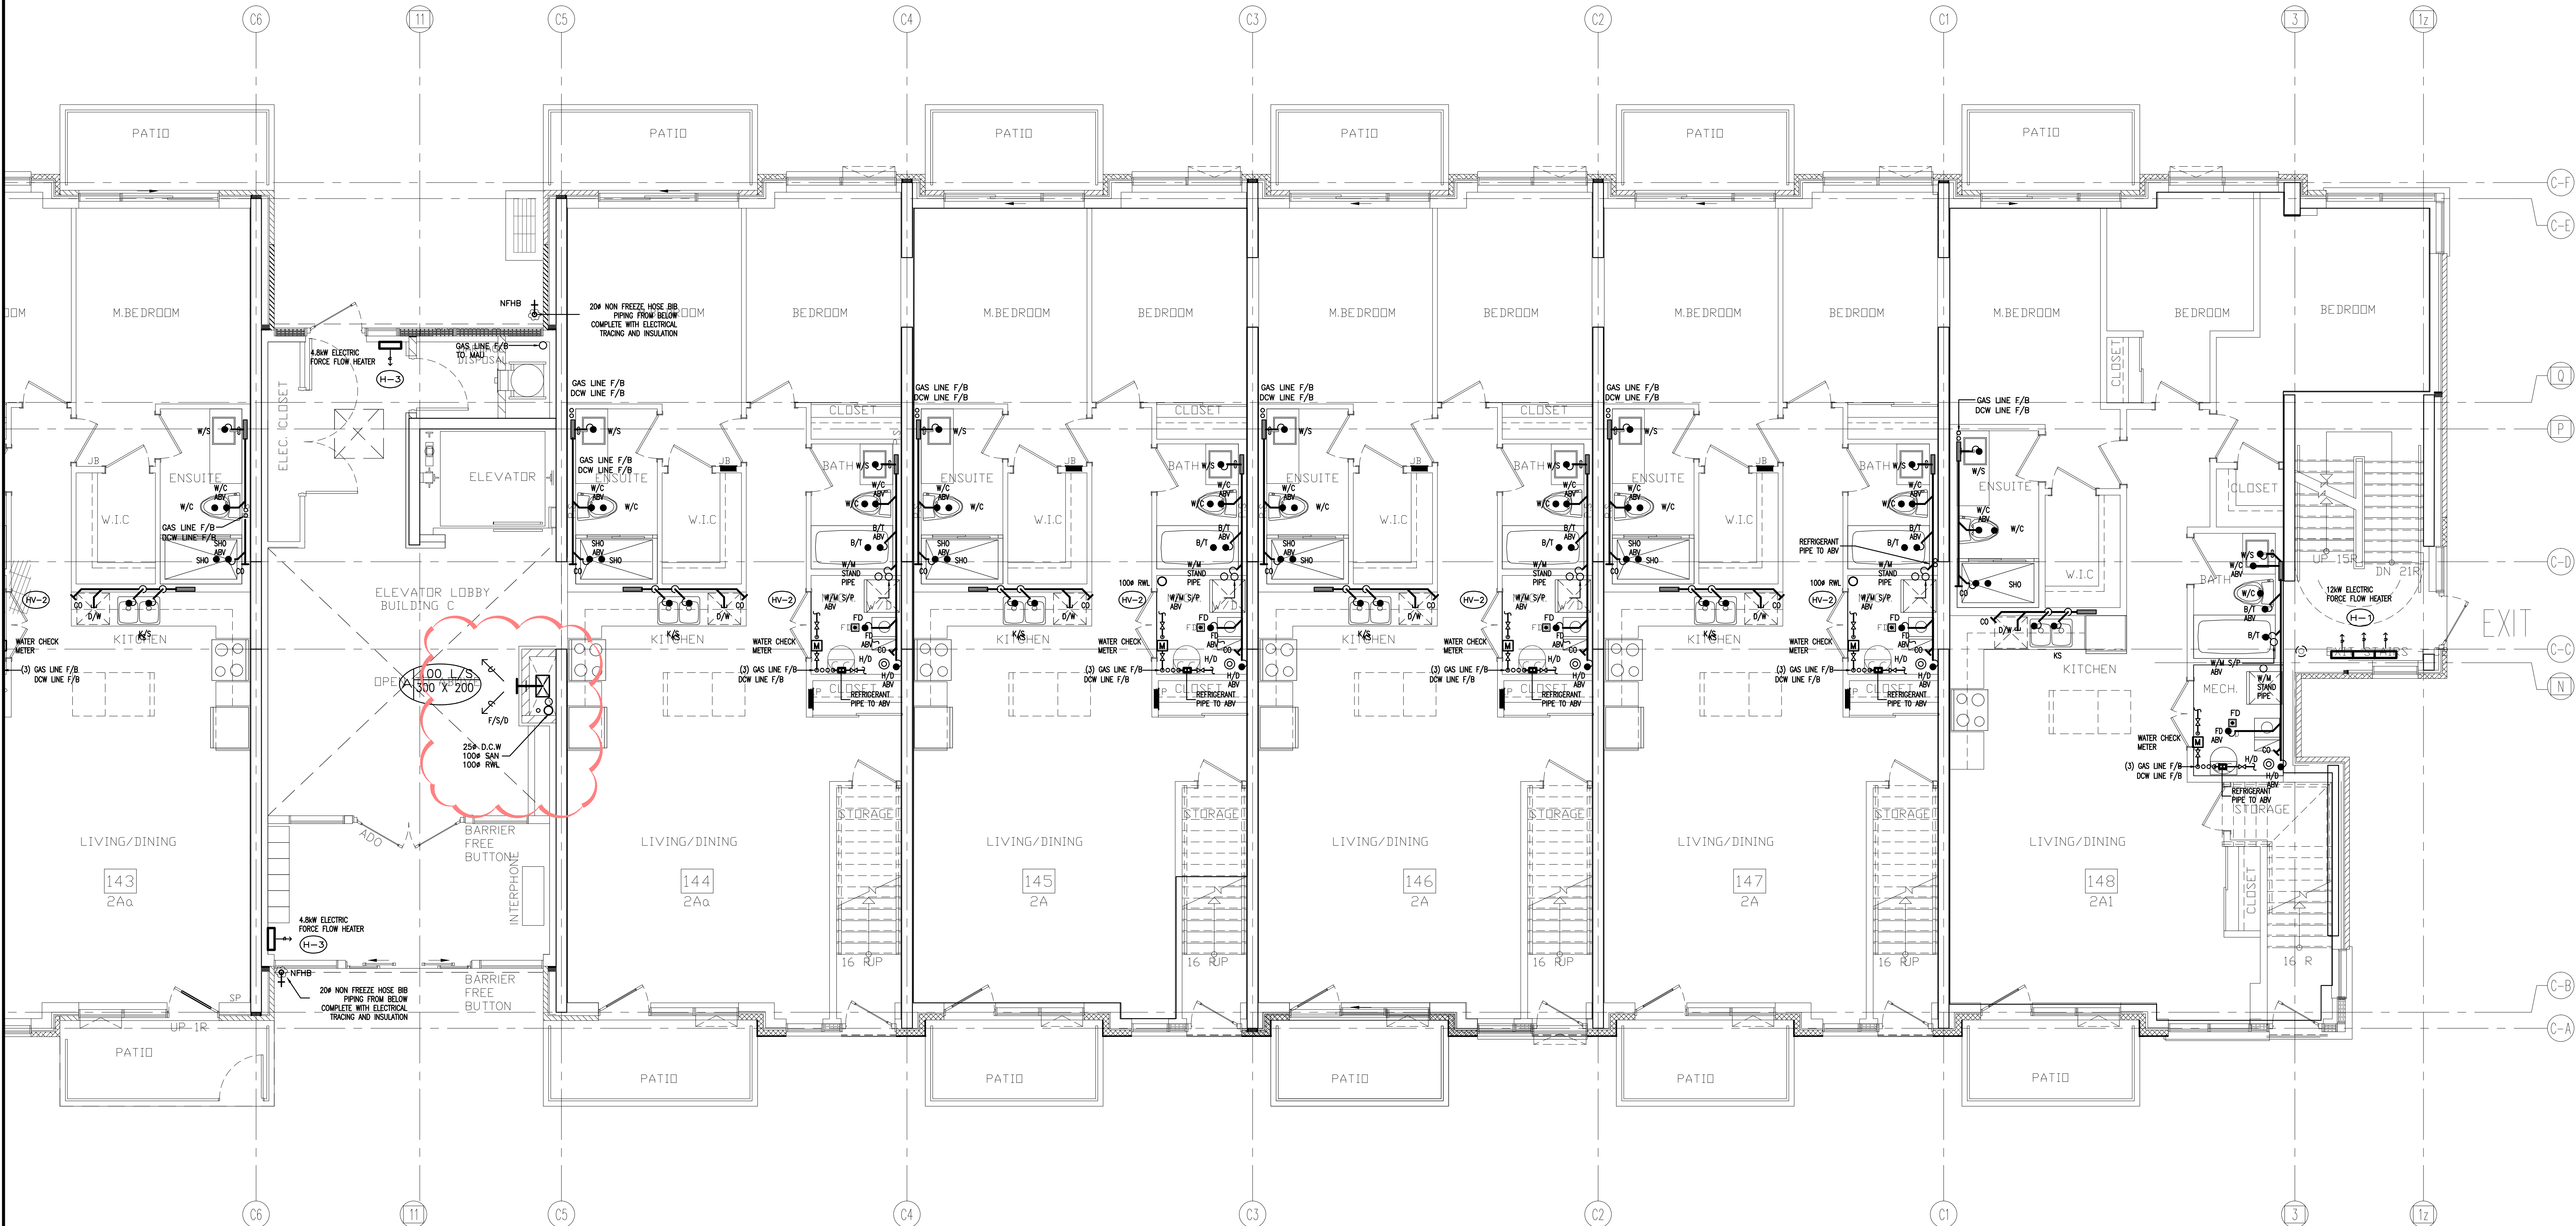

08	LB	ISSUED AS PER SITE INSTRUCTION M-02	JUN. 04, 2021
07	LB	ISSUED FOR PROGRESSIVE CONSTRUCTION	MAR. 26, 2021
06	LB	ISSUED AS PER ADDENDUM M-06	MAR. 25, 2021
05	LB	ISSUED FOR PERMIT BUILDING A,B,C,D	MAR. 03, 2021
04	LB	ISSUED AS PER ADDENDUM M-05	JAN. 20, 2021
03	LB	ISSUED FOR PERMIT	SEP. 28, 2020
02	RC	ADDENDUM #04	JUN. 12, 2020
01	RC	ISSUED FOR TENDER	AUG. 02, 2019
NO.	BY	DESCRIPTION	DATE



REVISIONS

This drawing, is an instrument of service, is provided by and is the property of United Engineering Inc. The contractor must verify and accept responsibility for all dimensions and conditions on site and must notify United Engineering Inc. of any discrepancy before proceeding.

United Engineering Inc. is not responsible for the accuracy of Architectural, structural, interior design, etc., on this drawing.

Refer to the appropriate trade drawings before proceeding with any work. Installation must conform to all applicable codes and requirements of the authorities having jurisdiction.

This drawing is not to be scaled, all symbols are graphic representations only.

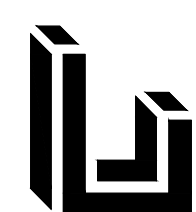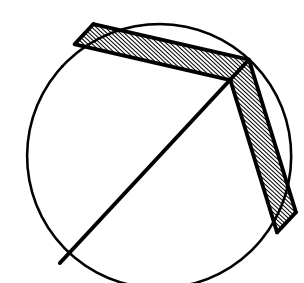

UNITED ENGINEERING INC.
Mechanical Electrical Consulting Engineers
3645 Keele Street, Suite 105,
Toronto, Ontario, M3J 1M6
Tel: (416) 398 1999, Fax: (416) 398 1933


TITLE
**BLOCK 'C'
GROUND FLOOR - PLUMBING/SANITARY**

PROJECT

**BRAMPTON STACKED
FORESTSIDE ESTATES**

**ATTMAR + PALLESCHI DRIVE
BRAMPTON, ONTARIO**

DRAWN	CHECKED	SCALE
MC	LM	1:50
DATE	PROJECT	DRAWING
MAY, 2019	18-017	M-16
		OF

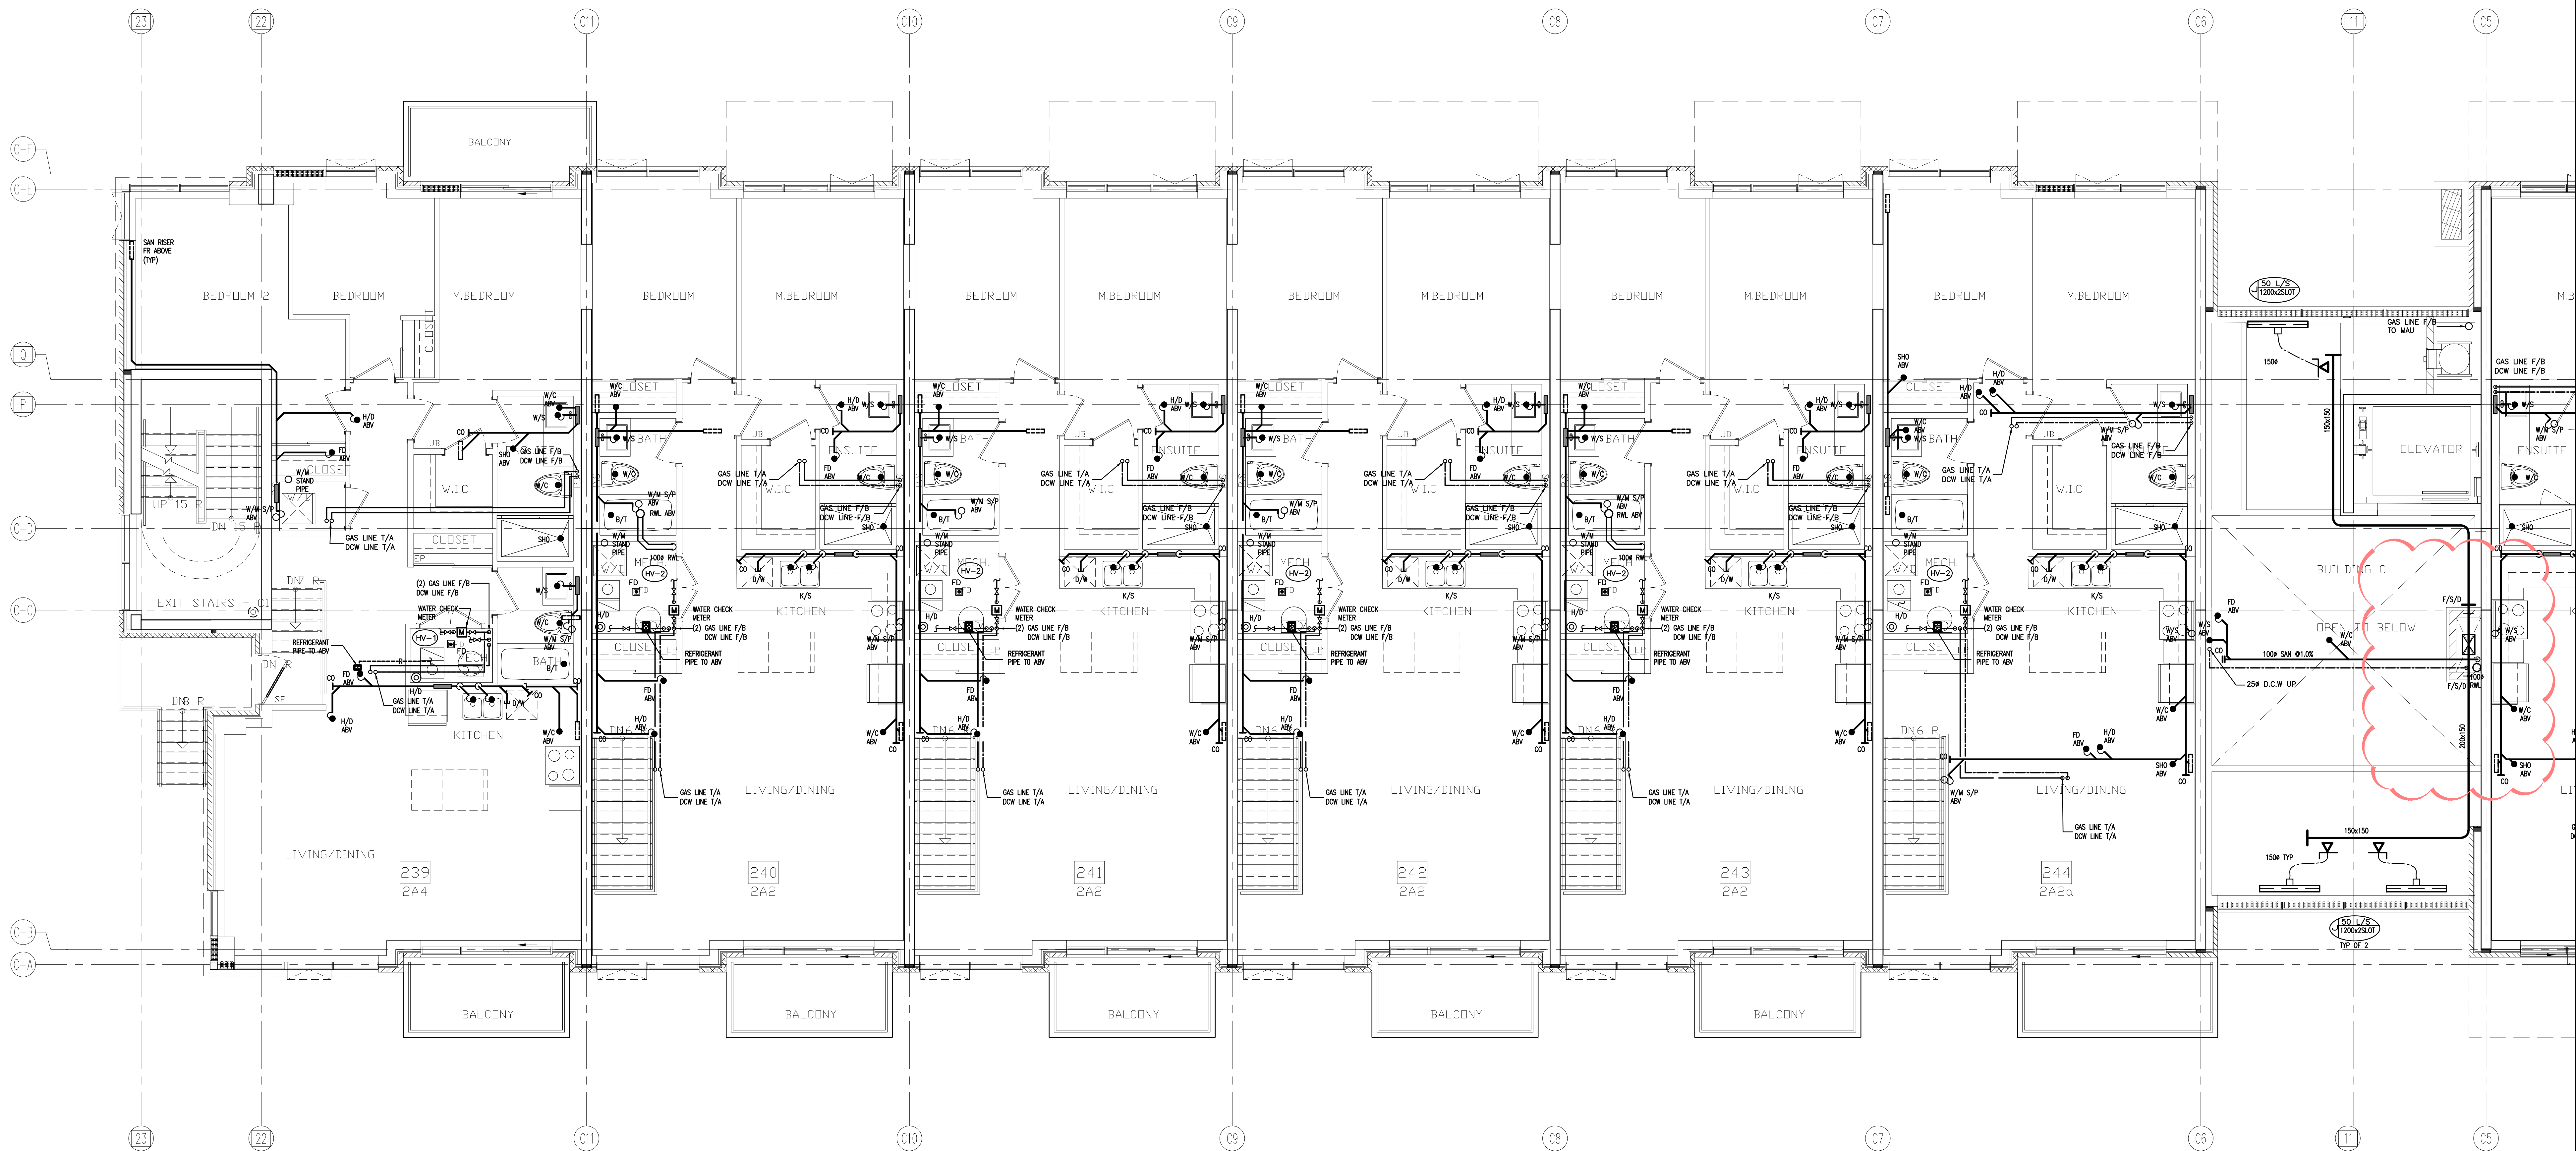

NO.	BY	DESCRIPTION	DATE
07	LB	ISSUED AS PER SITE INSTRUCTION M-02	JUN. 04, 2021
06	LB	ISSUED FOR PROGRESSIVE CONSTRUCTION	MAR. 26, 2021
05	LB	ISSUED FOR PERMIT BUILDING A,B,C,D	MAR. 03, 2021
04	LB	ISSUED AS PER ADDENDUM M-05	JAN. 20, 2021
03	LB	ISSUED FOR PERMIT	SEP. 28, 2020
02	RC	ADDENDUM #04	JUN. 12, 2020
01	RC	ISSUED FOR TENDER	AUG. 02, 2019


REVISIONS

This drawing is an instrument of service, is provided by and is the property of United Engineering Inc. The contractor must verify and accept responsibility for all dimensions and conditions on site and must notify United Engineering Inc. of any discrepancy before proceeding.

United Engineering Inc. is not responsible for the accuracy of Architectural, structural, interior design, etc., on this drawing.

Refer to the appropriate trade drawings before proceeding with any work. Installation must conform to all applicable codes and requirements of the authorities having jurisdiction.

This drawing is not to be scaled, all symbols are graphic representations only.

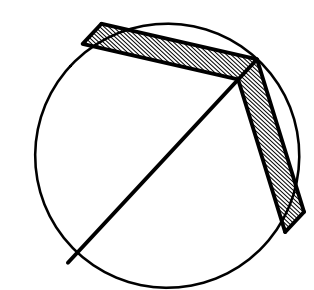

UNITED ENGINEERING INC.
Mechanical Electrical Consulting Engineers
3645 Keele Street, Suite 105,
Toronto, Ontario, M3J 1M6
Tel: (416) 398 1999, Fax: (416) 398 1933


TITLE
BLOCK 'C'
2ND FLOOR - PLUMBING/SANITARY

PROJECT

**BRAMPTON STACKED
FORESTSIDE ESTATES**

**ATTMAR + PALLESCHI DRIVE
BRAMPTON, ONTARIO**

DRAWN MC	CHECKED LM	SCALE 1:50
DATE MAY, 2019	PROJECT 18-017	DRAWING M-17 OF -

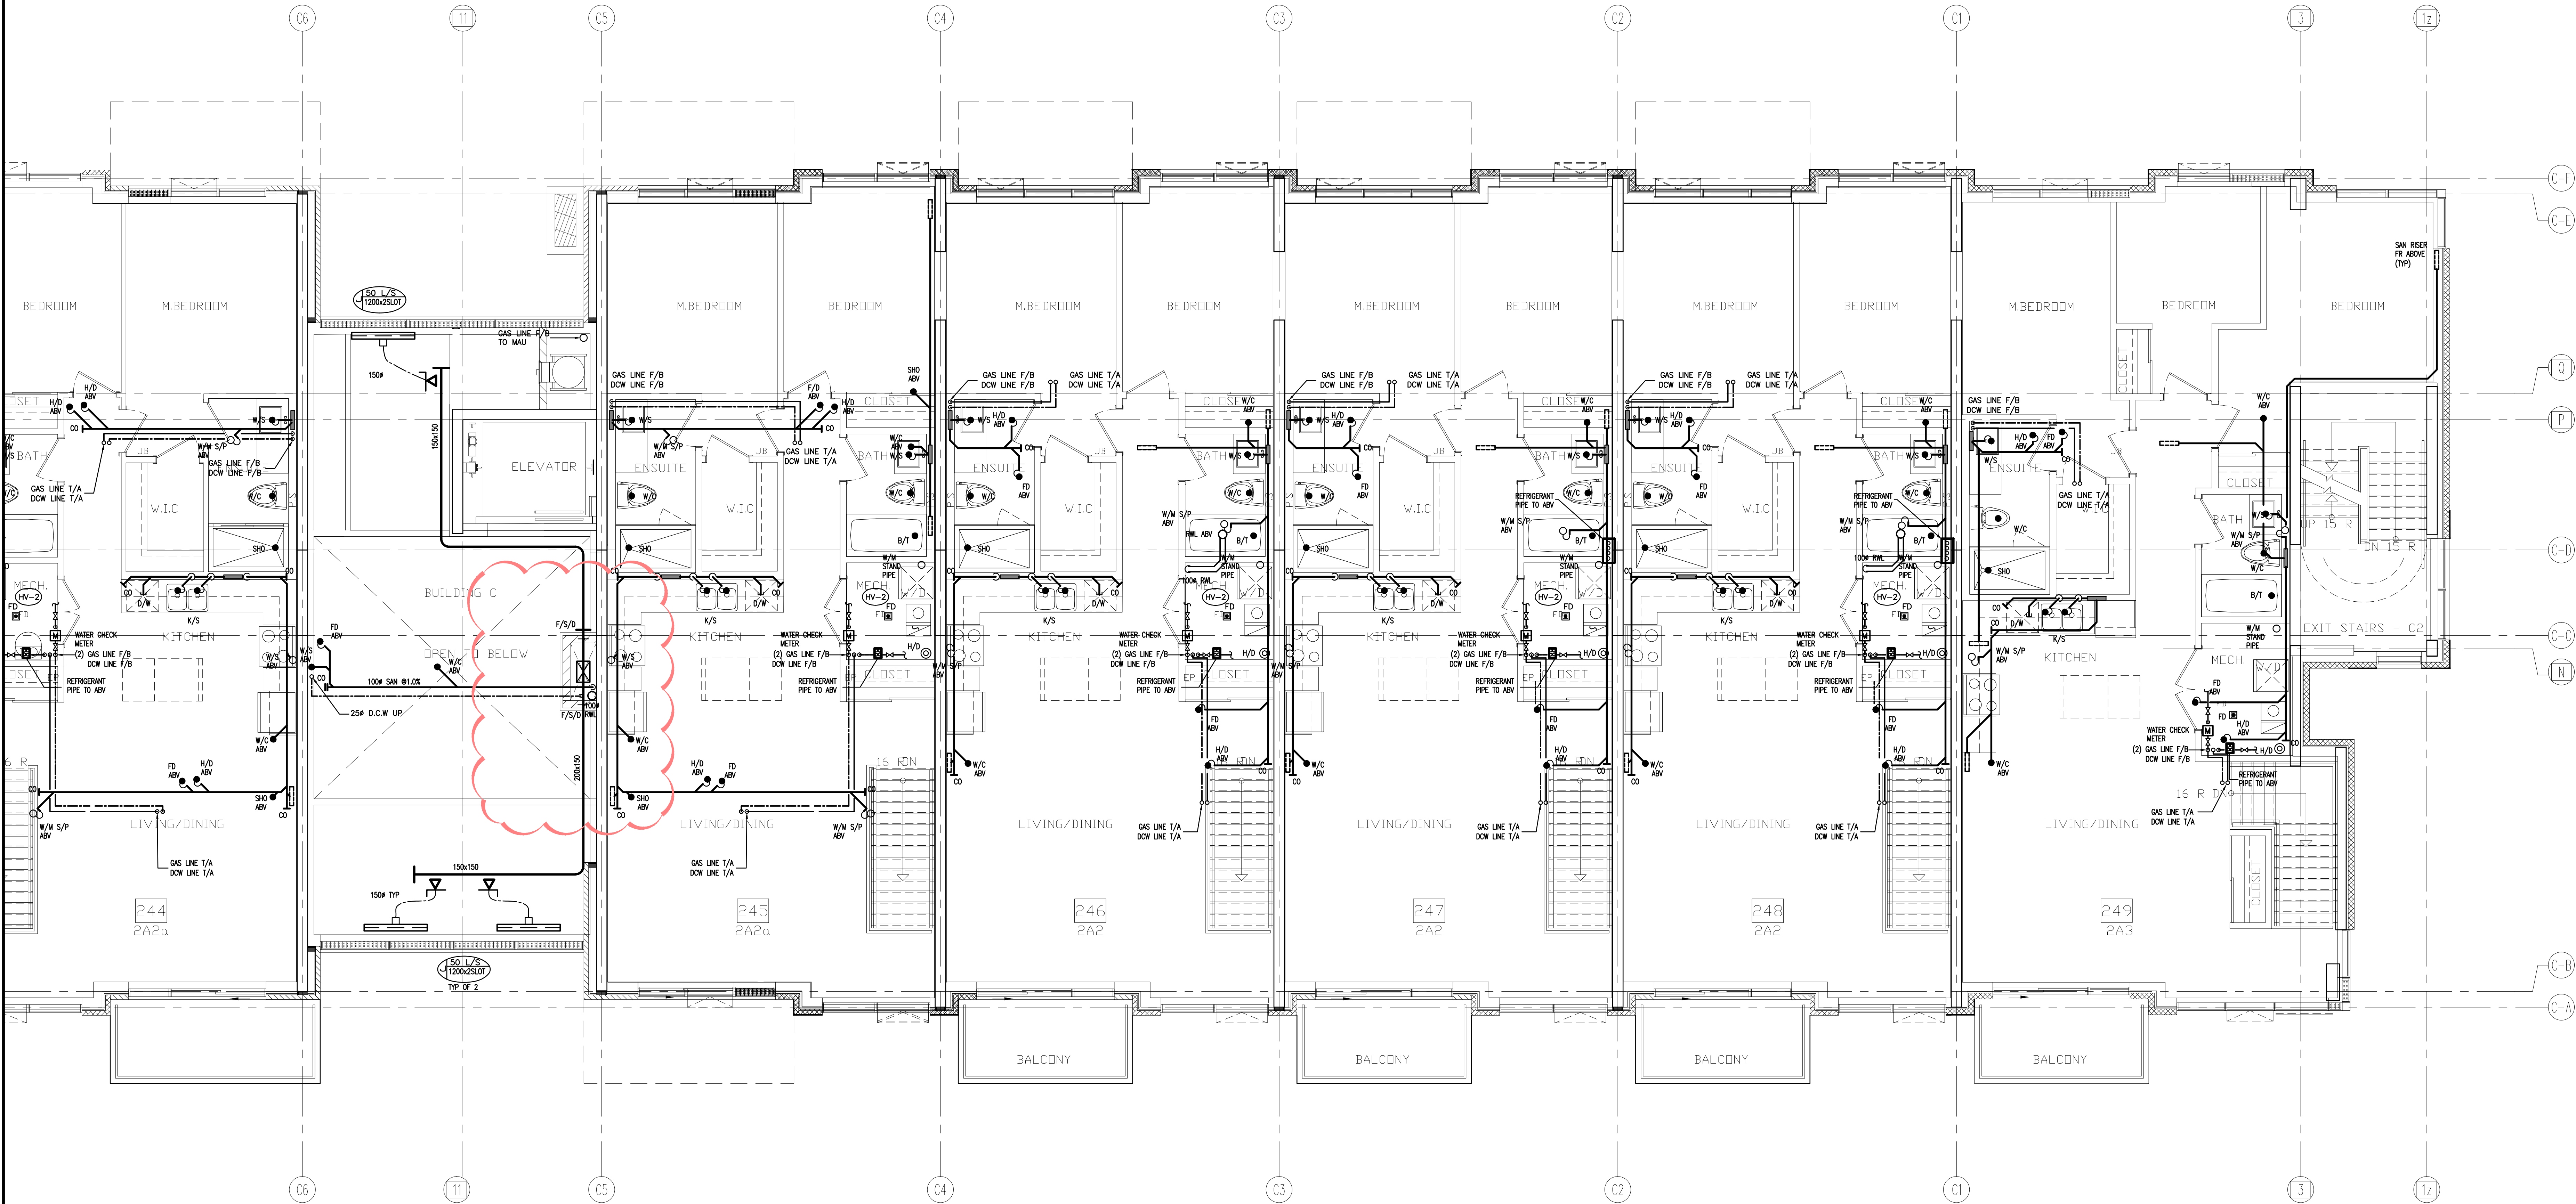

NO.	BY	DESCRIPTION	DATE
08	LB	ISSUED AS PER SITE INSTRUCTION M-02	JUN. 04, 2021
07	LB	ISSUED FOR PROGRESSIVE CONSTRUCTION	MAR. 26, 2021
06	LB	ISSUED AS PER ADDENDUM M-06	MAR. 25, 2021
05	LB	ISSUED FOR PERMIT BUILDING A,B,C,D	MAR. 03, 2021
04	LB	ISSUED AS PER ADDENDUM M-05	JAN. 20, 2021
03	LB	ISSUED FOR PERMIT	SEP. 28, 2020
02	RC	ADDENDUM #04	JUN. 12, 2020
01	RC	ISSUED FOR TENDER	AUG. 02, 2019


REVISIONS

This drawing is an instrument of service, is provided by and is the property of United Engineering Inc. The contractor must verify and accept responsibility for all dimensions and conditions on site and must notify United Engineering Inc. of any discrepancy before proceeding.

United Engineering Inc. is not responsible for the accuracy of Architectural, structural, interior design, etc., on this drawing.

Refer to the appropriate trade drawings before proceeding with any work. Installation must conform to all applicable codes and requirements of the authorities having jurisdiction.

This drawing is not to be scaled, all symbols are graphic representations only.

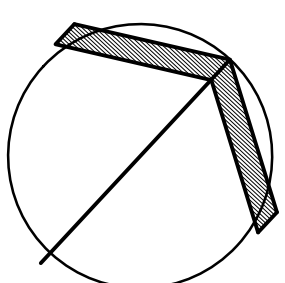

UNITED ENGINEERING INC.
Mechanical Electrical Consulting Engineers
3645 Keele Street, Suite 105,
Toronto, Ontario, M3J 1M6
Tel: (416) 398 1999, Fax: (416) 398 1933


TITLE
**BLOCK 'C'
2ND FLOOR - PLUMBING/SANITARY**

PROJECT

**BRAMPTON STACKED
FORESTSIDE ESTATES**

**ATTMAR + PALLESCHI DRIVE
BRAMPTON, ONTARIO**

DRAWN	CHECKED	SCALE
MC	LM	1:50
DATE	PROJECT	DRAWING
MAY, 2019	18-017	M-18
		OF

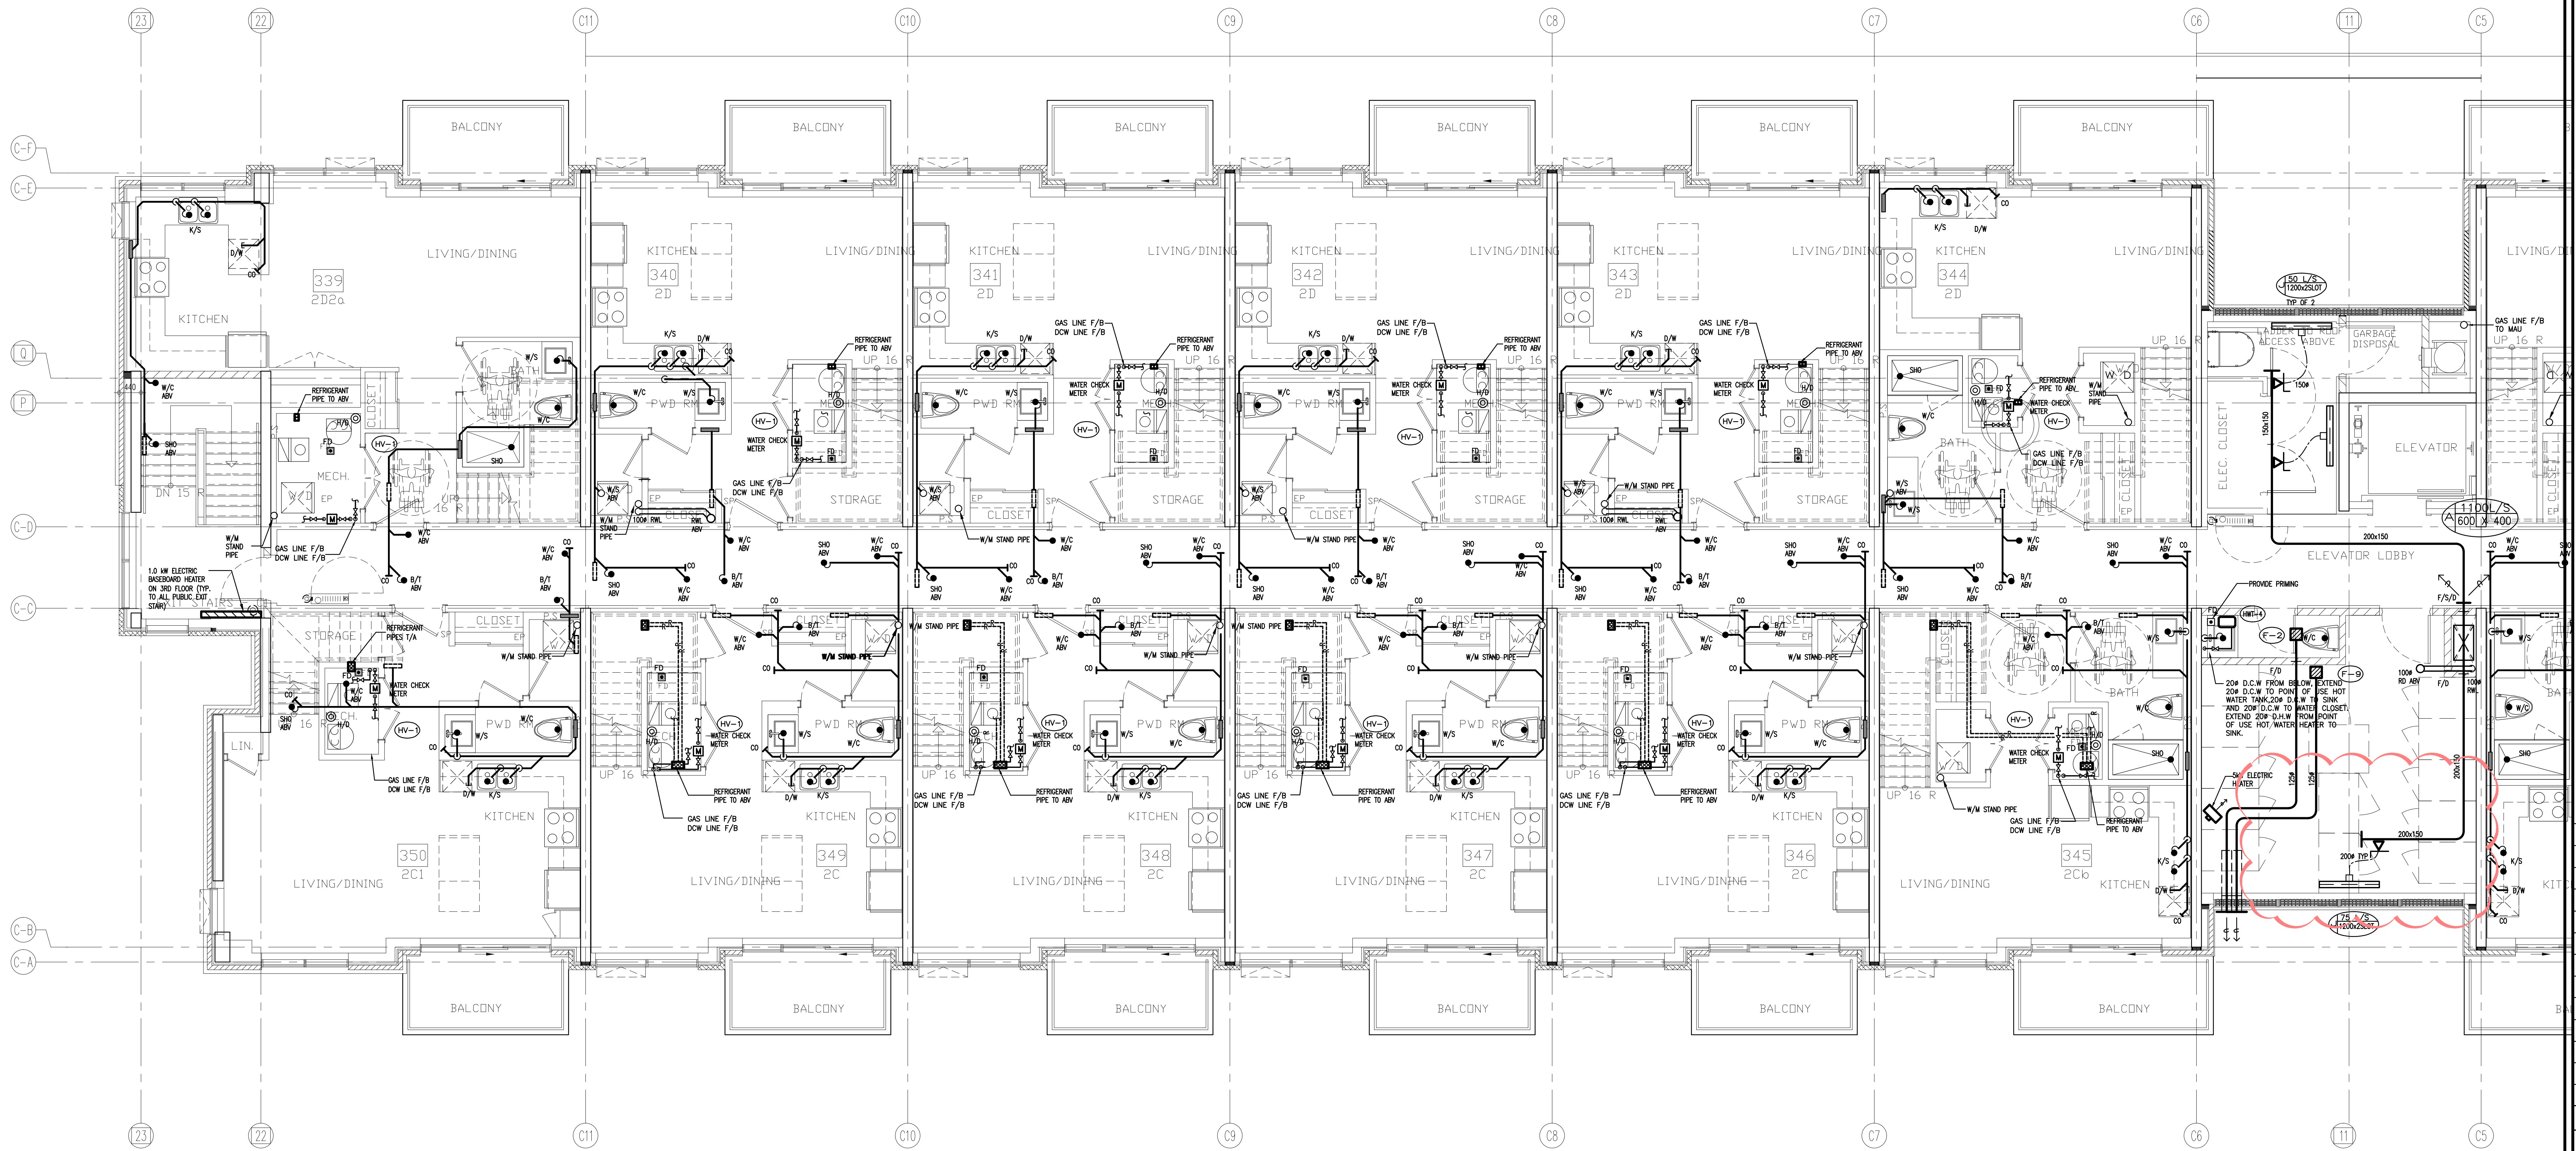

NO.	BY	DESCRIPTION	DATE
07	LB	ISSUED AS PER SITE INSTRUCTION M-02	JUN. 04, 2021
06	LB	ISSUED FOR PROGRESSIVE CONSTRUCTION	MAR. 28, 2021
05	LB	ISSUED FOR PERMIT BUILDING A,B,C,D	MAR. 03, 2021
04	LB	ISSUED AS PER ADDENDUM M-05	JAN. 20, 2021
03	LB	ISSUED FOR PERMIT	SEP. 28, 2020
02	RC	ADDENDUM #04	JUN. 12, 2020
01	RC	ISSUED FOR TENDER	AUG. 02, 2019


REVISIONS

This drawing is an instrument of service, is provided by and is the property of United Engineering Inc. The contractor must verify and accept responsibility for all dimensions and conditions on site and must notify United Engineering Inc. of any discrepancy before proceeding.

United Engineering Inc. is not responsible for the accuracy of Architectural, structural, interior design, etc. on this drawing.


Refer to the appropriate trade drawings before proceeding with any work. Installation must conform to all applicable codes and requirements of the authorities having jurisdiction.

This drawing is not to be scaled, all symbols are graphic representations only.

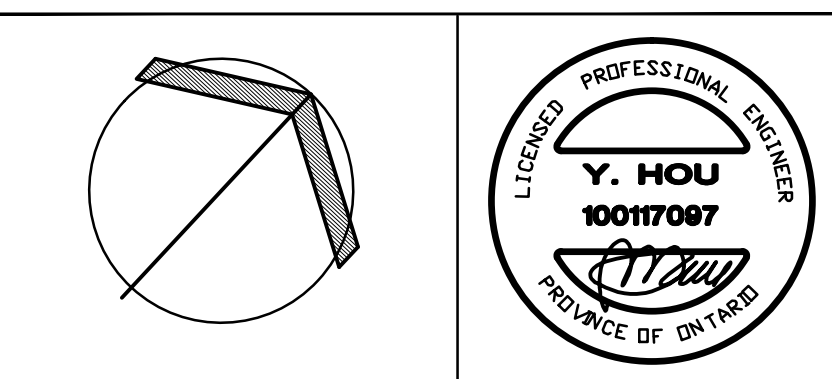

UNITED ENGINEERING INC.
Mechanical Electrical Consulting Engineers
3645 Keele Street, Suite 105,
Toronto, Ontario, M3J 1M6
Tel: (416) 398 1999, Fax: (416) 398 1933

TITLE BLOCK 'C' 3RD FLOOR - PLUMBING/SANITARY		
PROJECT BRAMPTON STACKED FORESTSIDE ESTATES		
ATTMAY + PALLESCI DRIVE BRAMPTON, ONTARIO		
DRAWN MC	CHECKED LM	SCALE 1:50
DATE MAY, 2019	PROJECT 18-017	DRAWING M-19 OF -

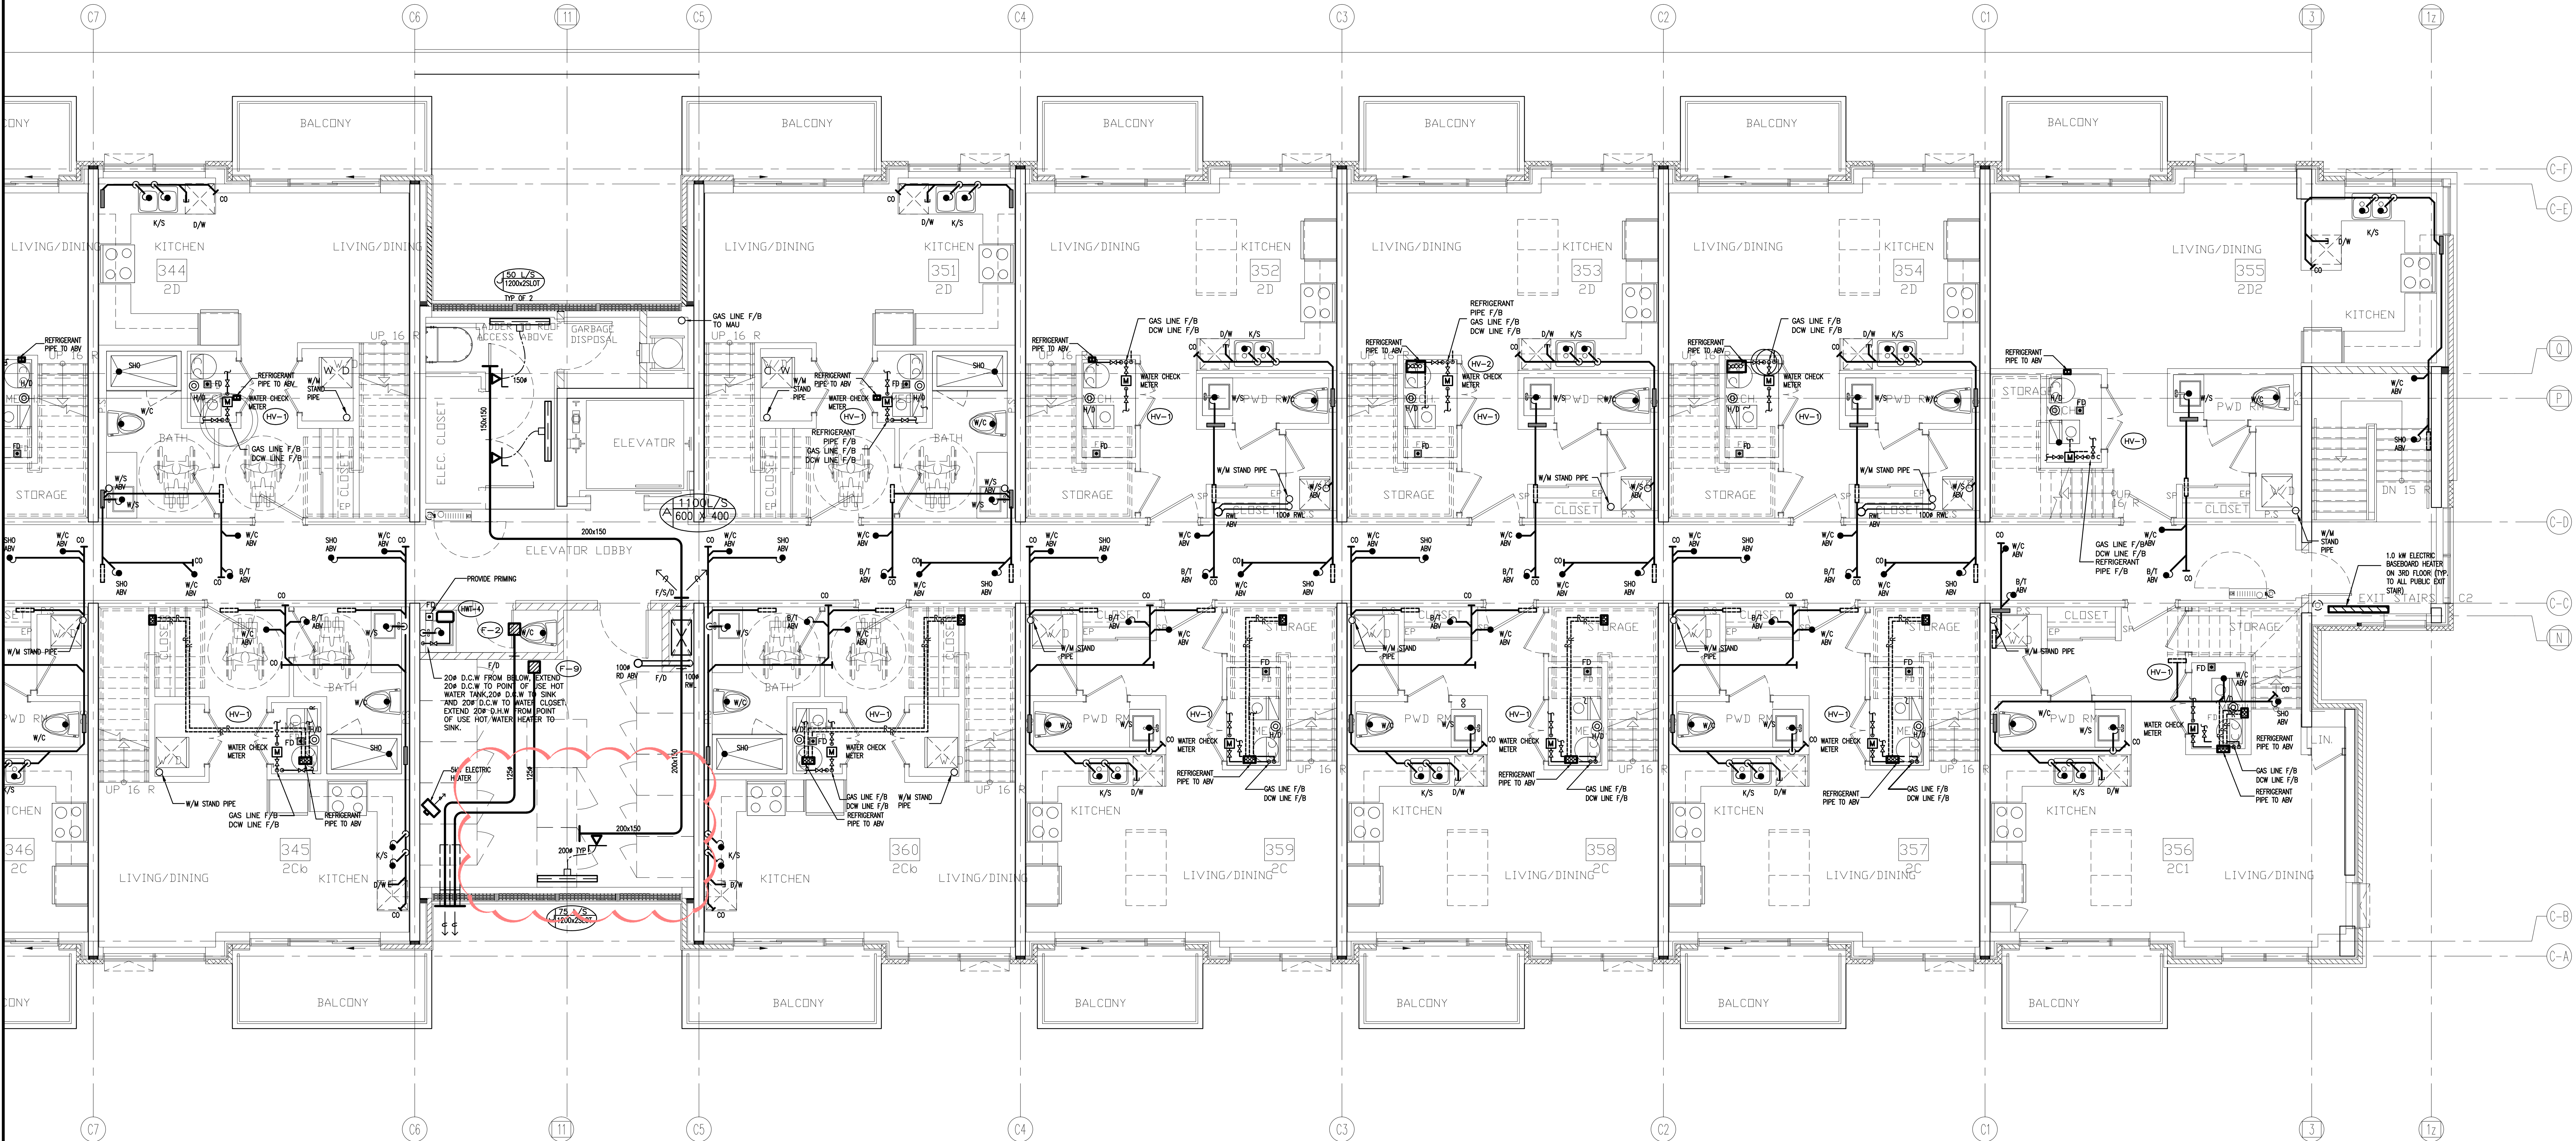

NO.	BY	DESCRIPTION	DATE
08	LB	ISSUED AS PER SITE INSTRUCTION M-02	JUN. 04, 2021
07	LB	ISSUED FOR PROGRESSIVE CONSTRUCTION	MAR. 26, 2021
06	LB	ISSUED AS PER ADDENDUM M-06	MAR. 25, 2021
05	LB	ISSUED FOR PERMIT BUILDING A.B.C.D	MAR. 03, 2021
04	LB	ISSUED AS PER ADDENDUM M-05	JAN. 20, 2021
03	LB	ISSUED FOR PERMIT	SEP. 28, 2020
02	RC	ADDENDUM #04	JUN. 12, 2020
01	RC	ISSUED FOR TENDER	AUG. 02, 2019


REVISIONS

This drawing is an instrument of service, is provided by and is the property of United Engineering Inc. The contractor must verify and accept responsibility for all dimensions and conditions on site and must notify United Engineering Inc. of any discrepancy before proceeding.

United Engineering Inc. is not responsible for the accuracy of Architectural, structural, interior design, etc., on this drawing.

Refer to the appropriate trade drawings before proceeding with any work. Installation must conform to all applicable codes and requirements of the authorities having jurisdiction.

This drawing is not to be scaled, all symbols are graphic representations only.

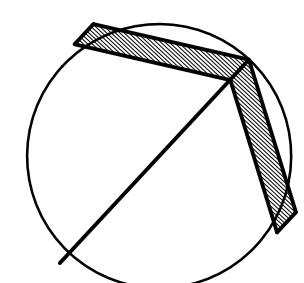

UNITED ENGINEERING INC.
Mechanical Electrical Consulting Engineers
3645 Keele Street, Suite 105,
Toronto, Ontario, M3J 1M6
Tel: (416) 398 1999, Fax: (416) 398 1933



TITLE
**BLOCK 'C'
3RD FLOOR - PLUMBING/SANITARY**

PROJECT

**BRAMPTON STACKED
FORESTSIDE ESTATES**

**ATTMAR + PALLESCHI DRIVE
BRAMPTON, ONTARIO**

DRAWN	CHECKED	SCALE
MC	LM	1:50
DATE	PROJECT	DRAWING
MAY, 2019	18-017	M-20
		OF -

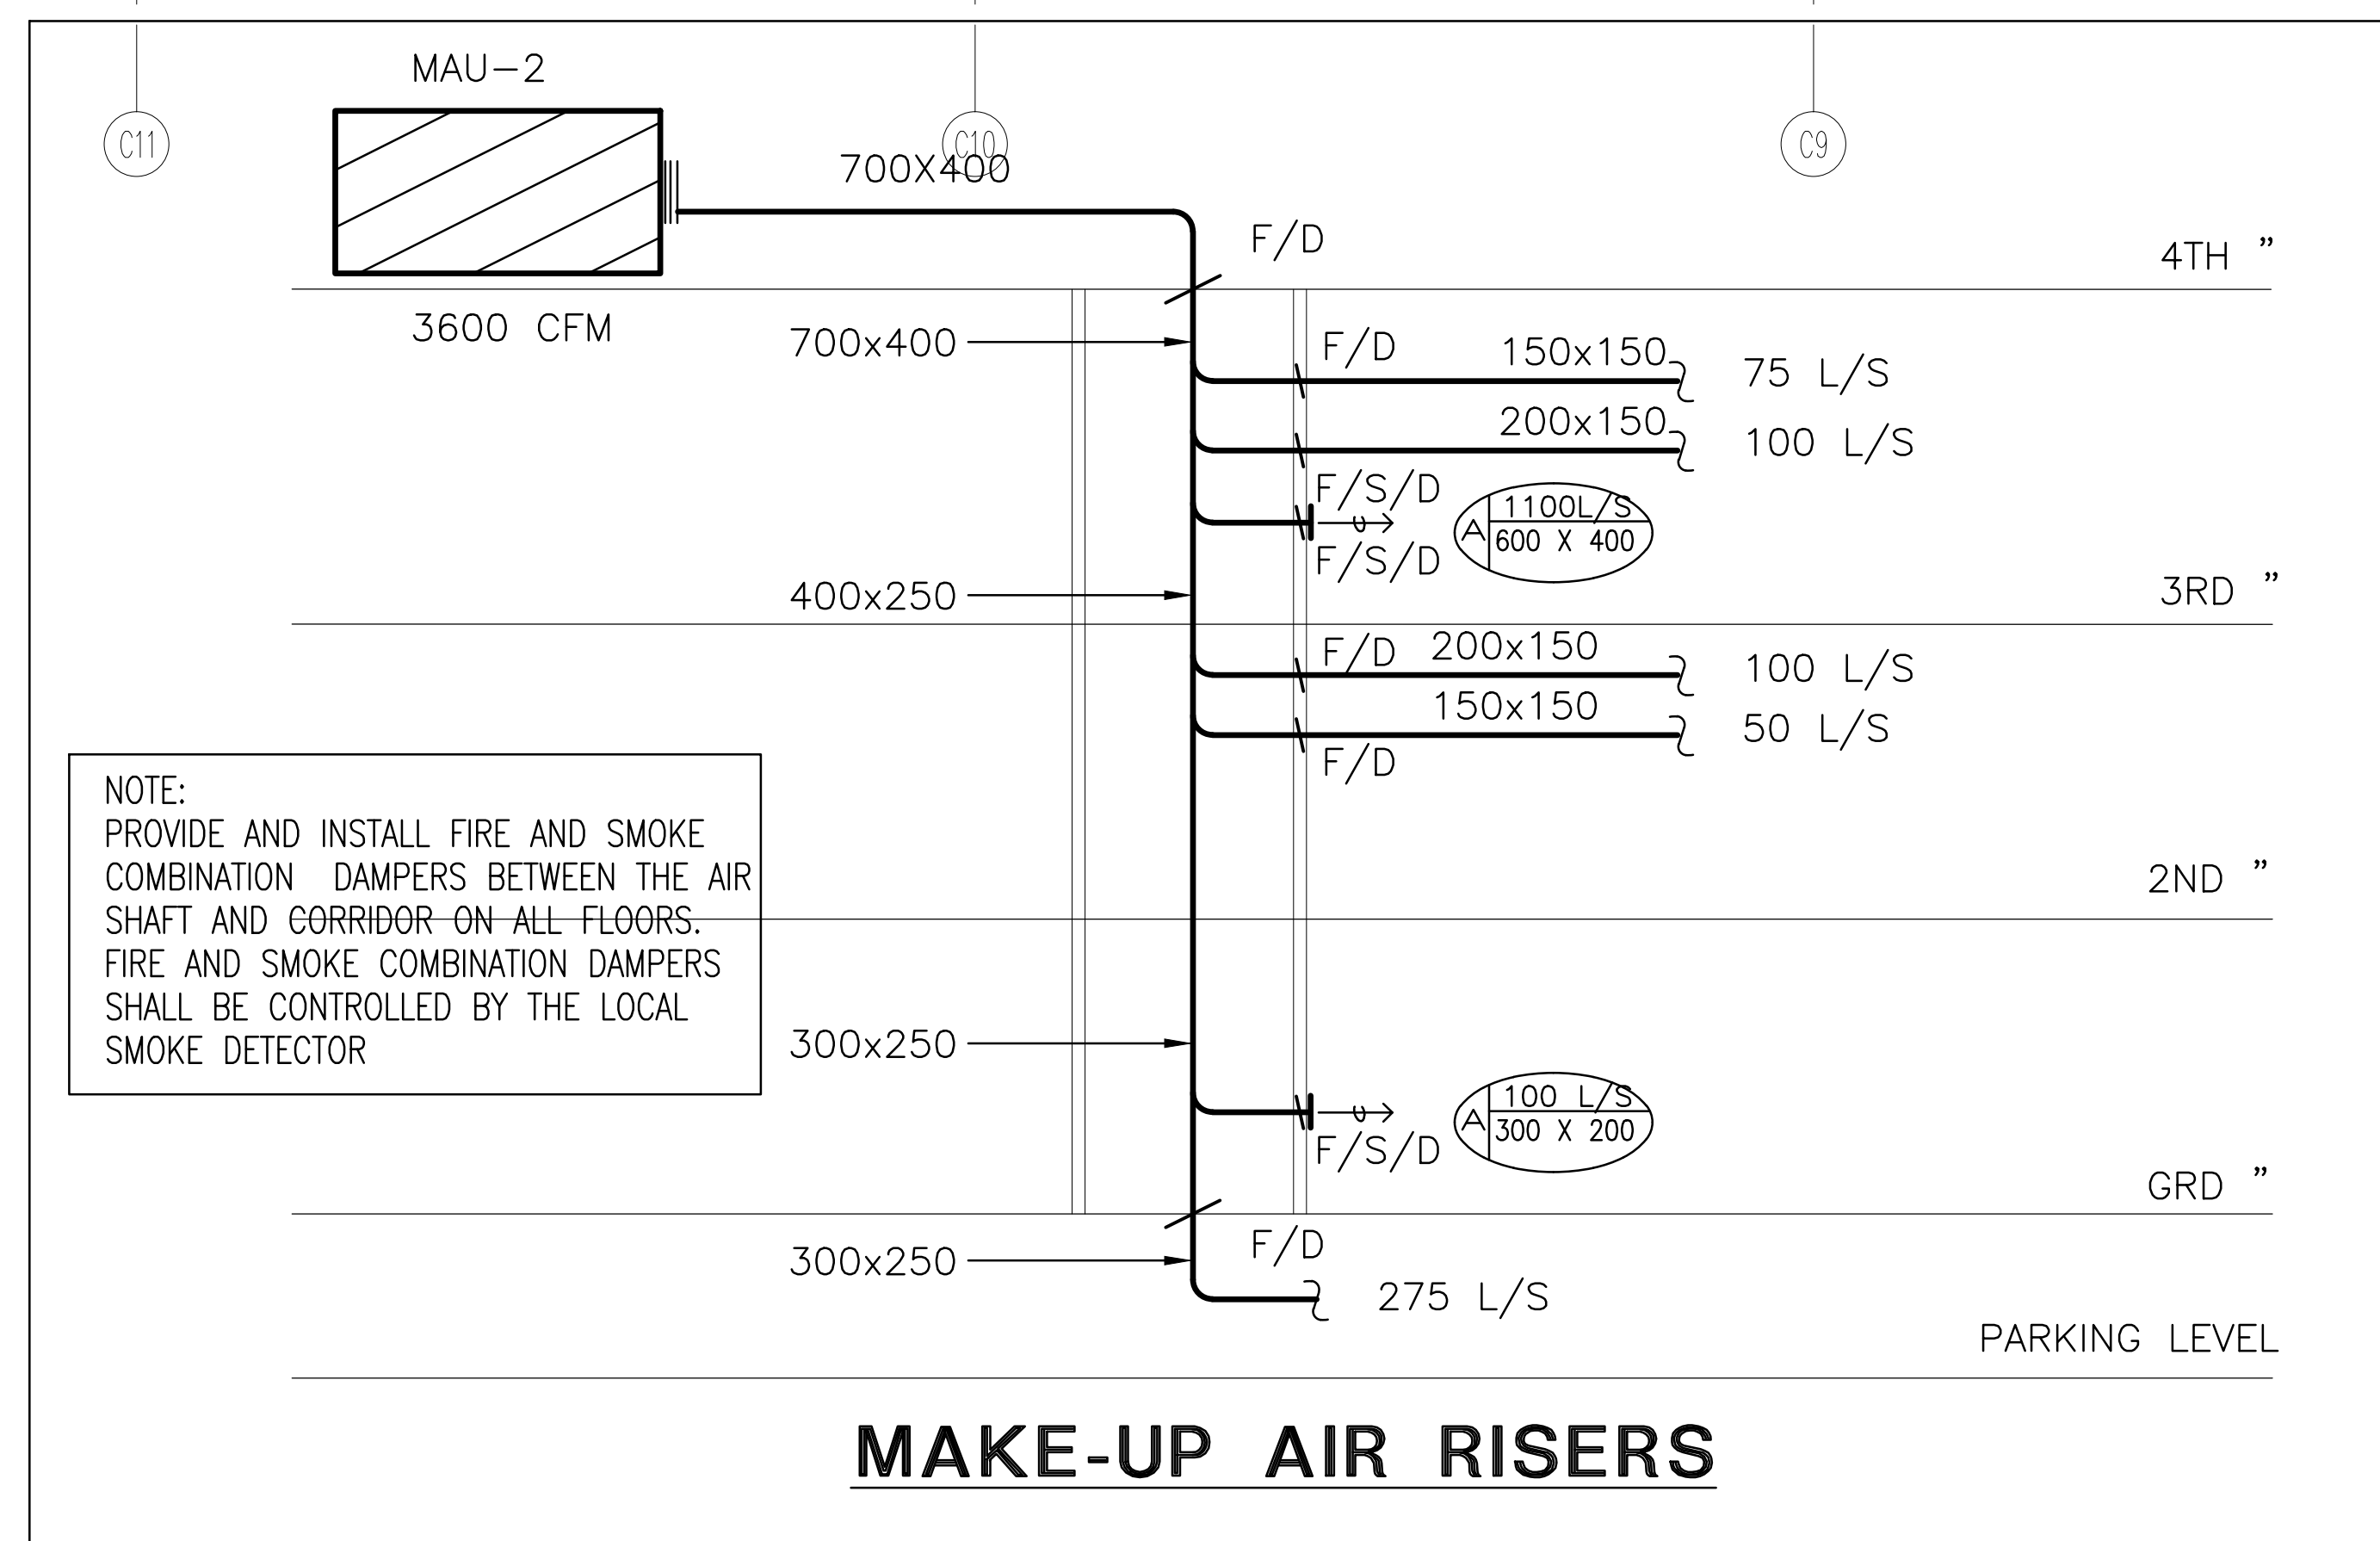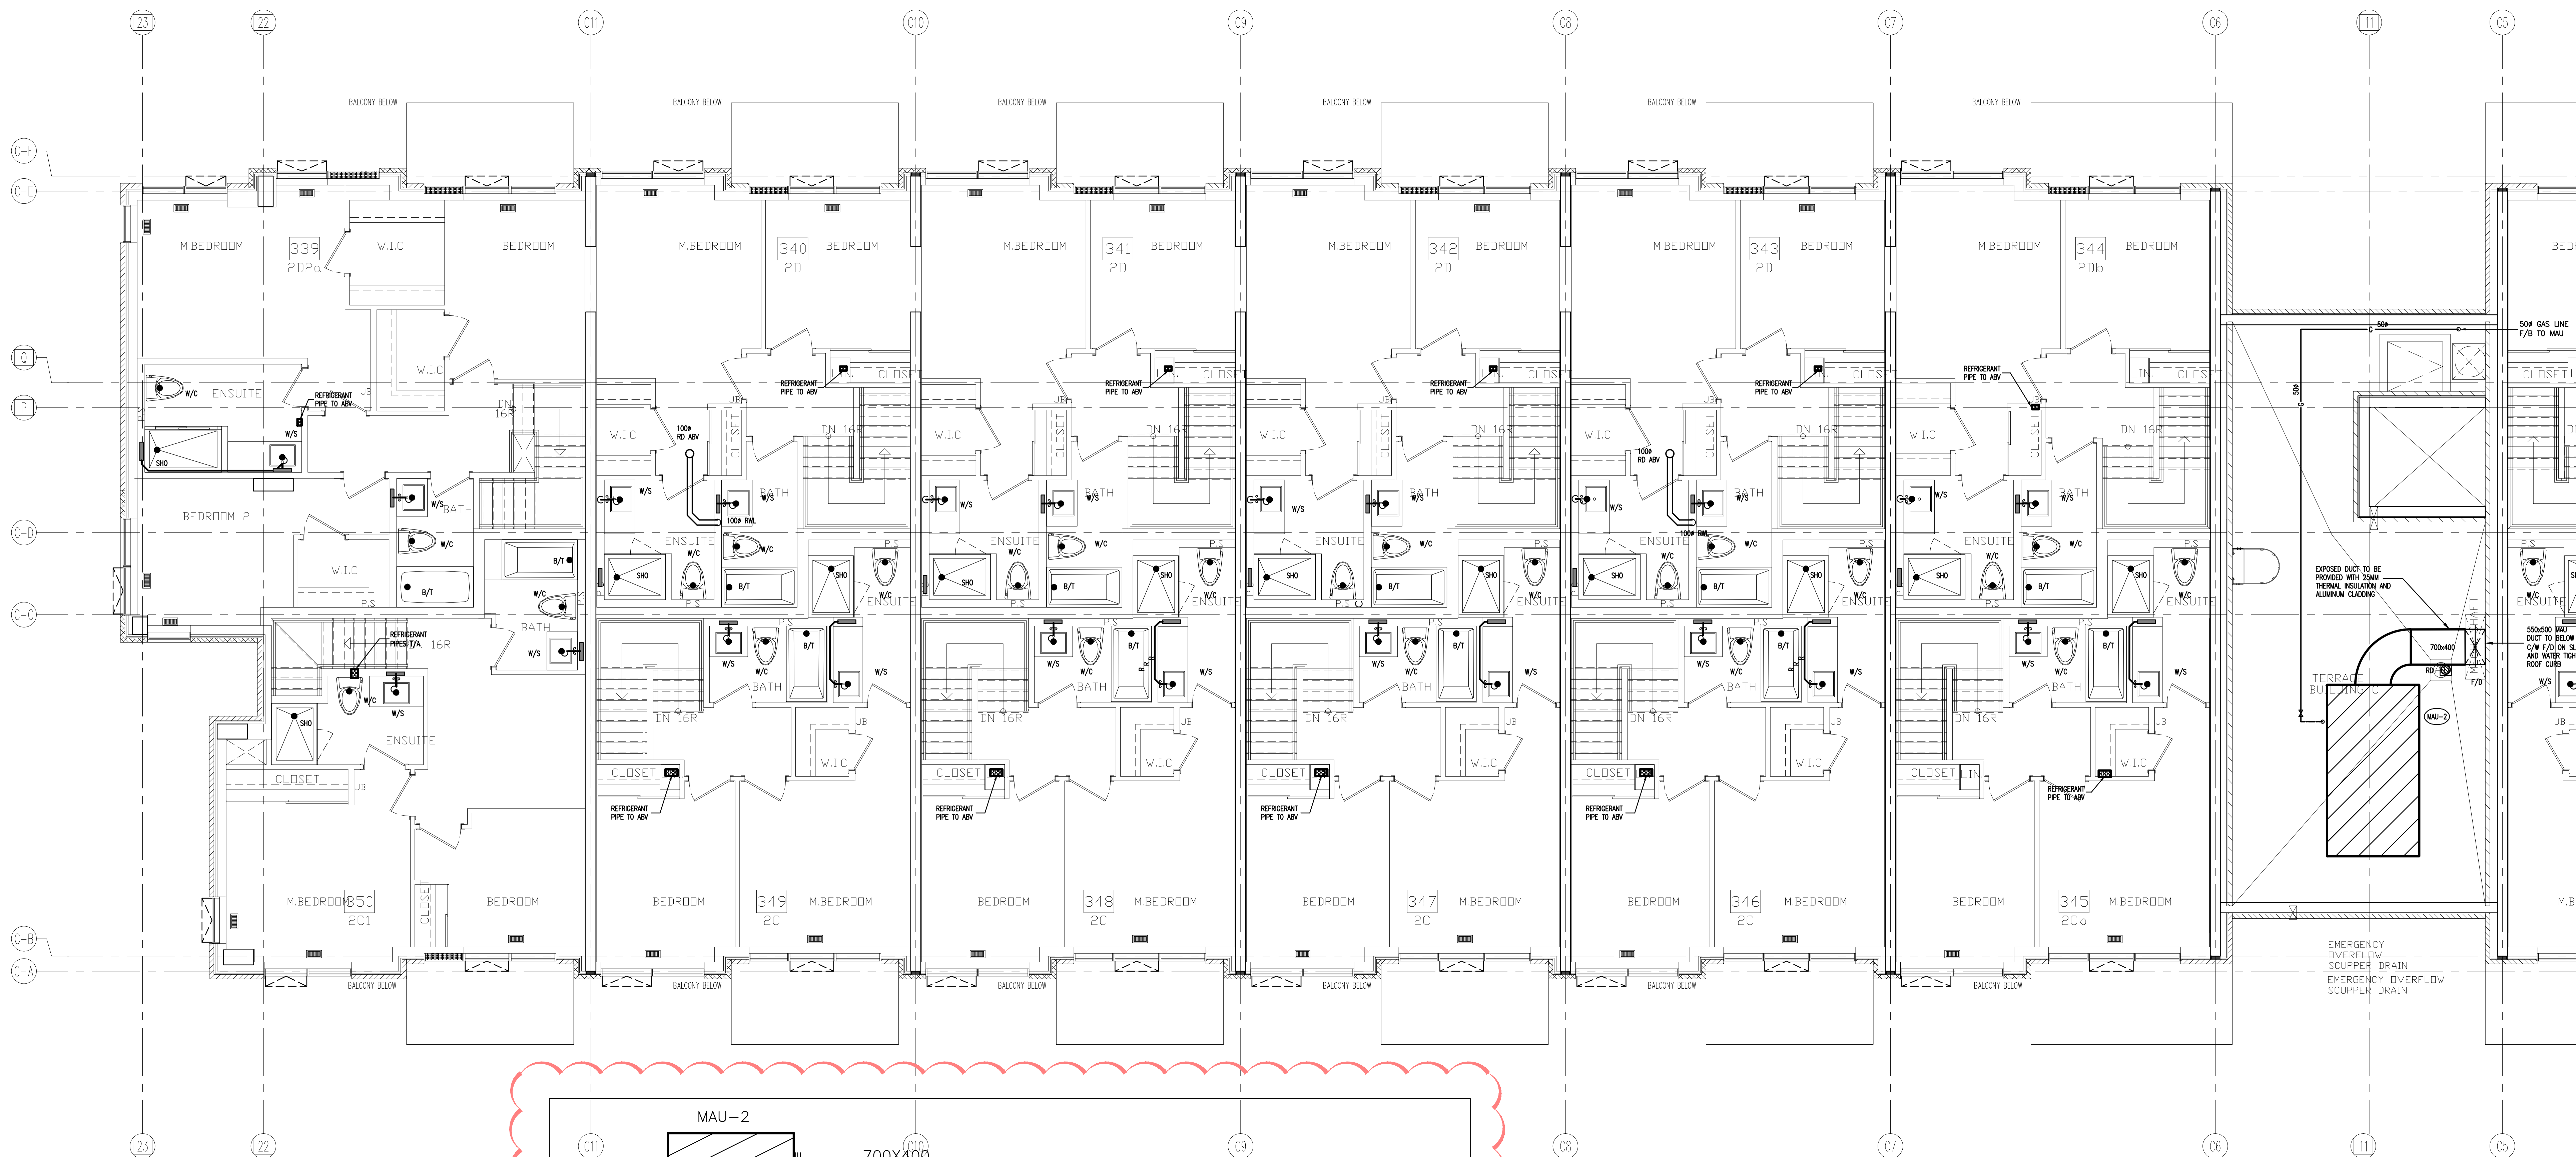

NO.	BY	DESCRIPTION	DATE
09	LB	ISSUED AS PER SITE INSTRUCTION M-02	JUN. 04, 2021
08	LB	ISSUED AS PER SITE INSTRUCTION M-01	APR. 28, 2021
07	LB	ISSUED FOR PROGRESSIVE CONSTRUCTION	MAR. 26, 2021
06	LB	ISSUED AS PER ADDENDUM M-06	MAR. 25, 2021
05	LB	ISSUED FOR PERMIT BUILDING A.B.C.D.	MAR. 03, 2021
04	LB	ISSUED AS PER ADDENDUM M-05	JAN. 20, 2021
03	LB	ISSUED FOR PERMIT	SEP. 28, 2020
02	RC	ADDENDUM #04	JUN. 12, 2020
01	RC	ISSUED FOR TENDER	AUG. 02, 2019


REVISIONS

This drawing is an instrument of service, is provided by and is the property of United Engineering Inc. The contractor must verify and accept responsibility for all dimensions and conditions on site and must notify United Engineering Inc. of any discrepancy before proceeding.

United Engineering Inc. is not responsible for the accuracy of Architectural, structural, interior design, etc., on this drawing.


Refer to the appropriate trade drawings before proceeding with any work. Installation must conform to all applicable codes and requirements of the authorities having jurisdiction.

This drawing is not to be scaled, all symbols are graphic representations only.

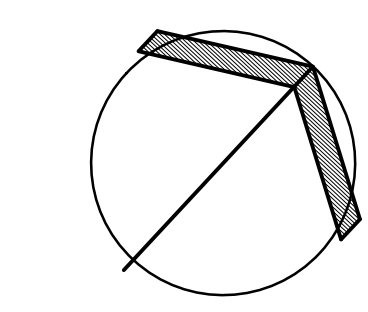

UNITED ENGINEERING INC.
Mechanical Electrical Consulting Engineers
3645 Keele Street, Suite 105,
Toronto, Ontario, M3J 1M6
Tel: (416) 398 1999, Fax: (416) 398 1933

TITLE	BLOCK 'C'
PROJECT	4TH FLOOR - PLUMBING/SANITARY
PROJECT	BRAMPTON STACKED FORESTSIDE ESTATES
ATTN	ATTMAR + PALLESCI DRIVE
LOCATION	BRAMPTON, ONTARIO
DRAWN	MC
CHECKED	LM
DATE	MAY, 2019
PROJECT	18-017
SCALE	1:50
DRAWING	M-21
OF	

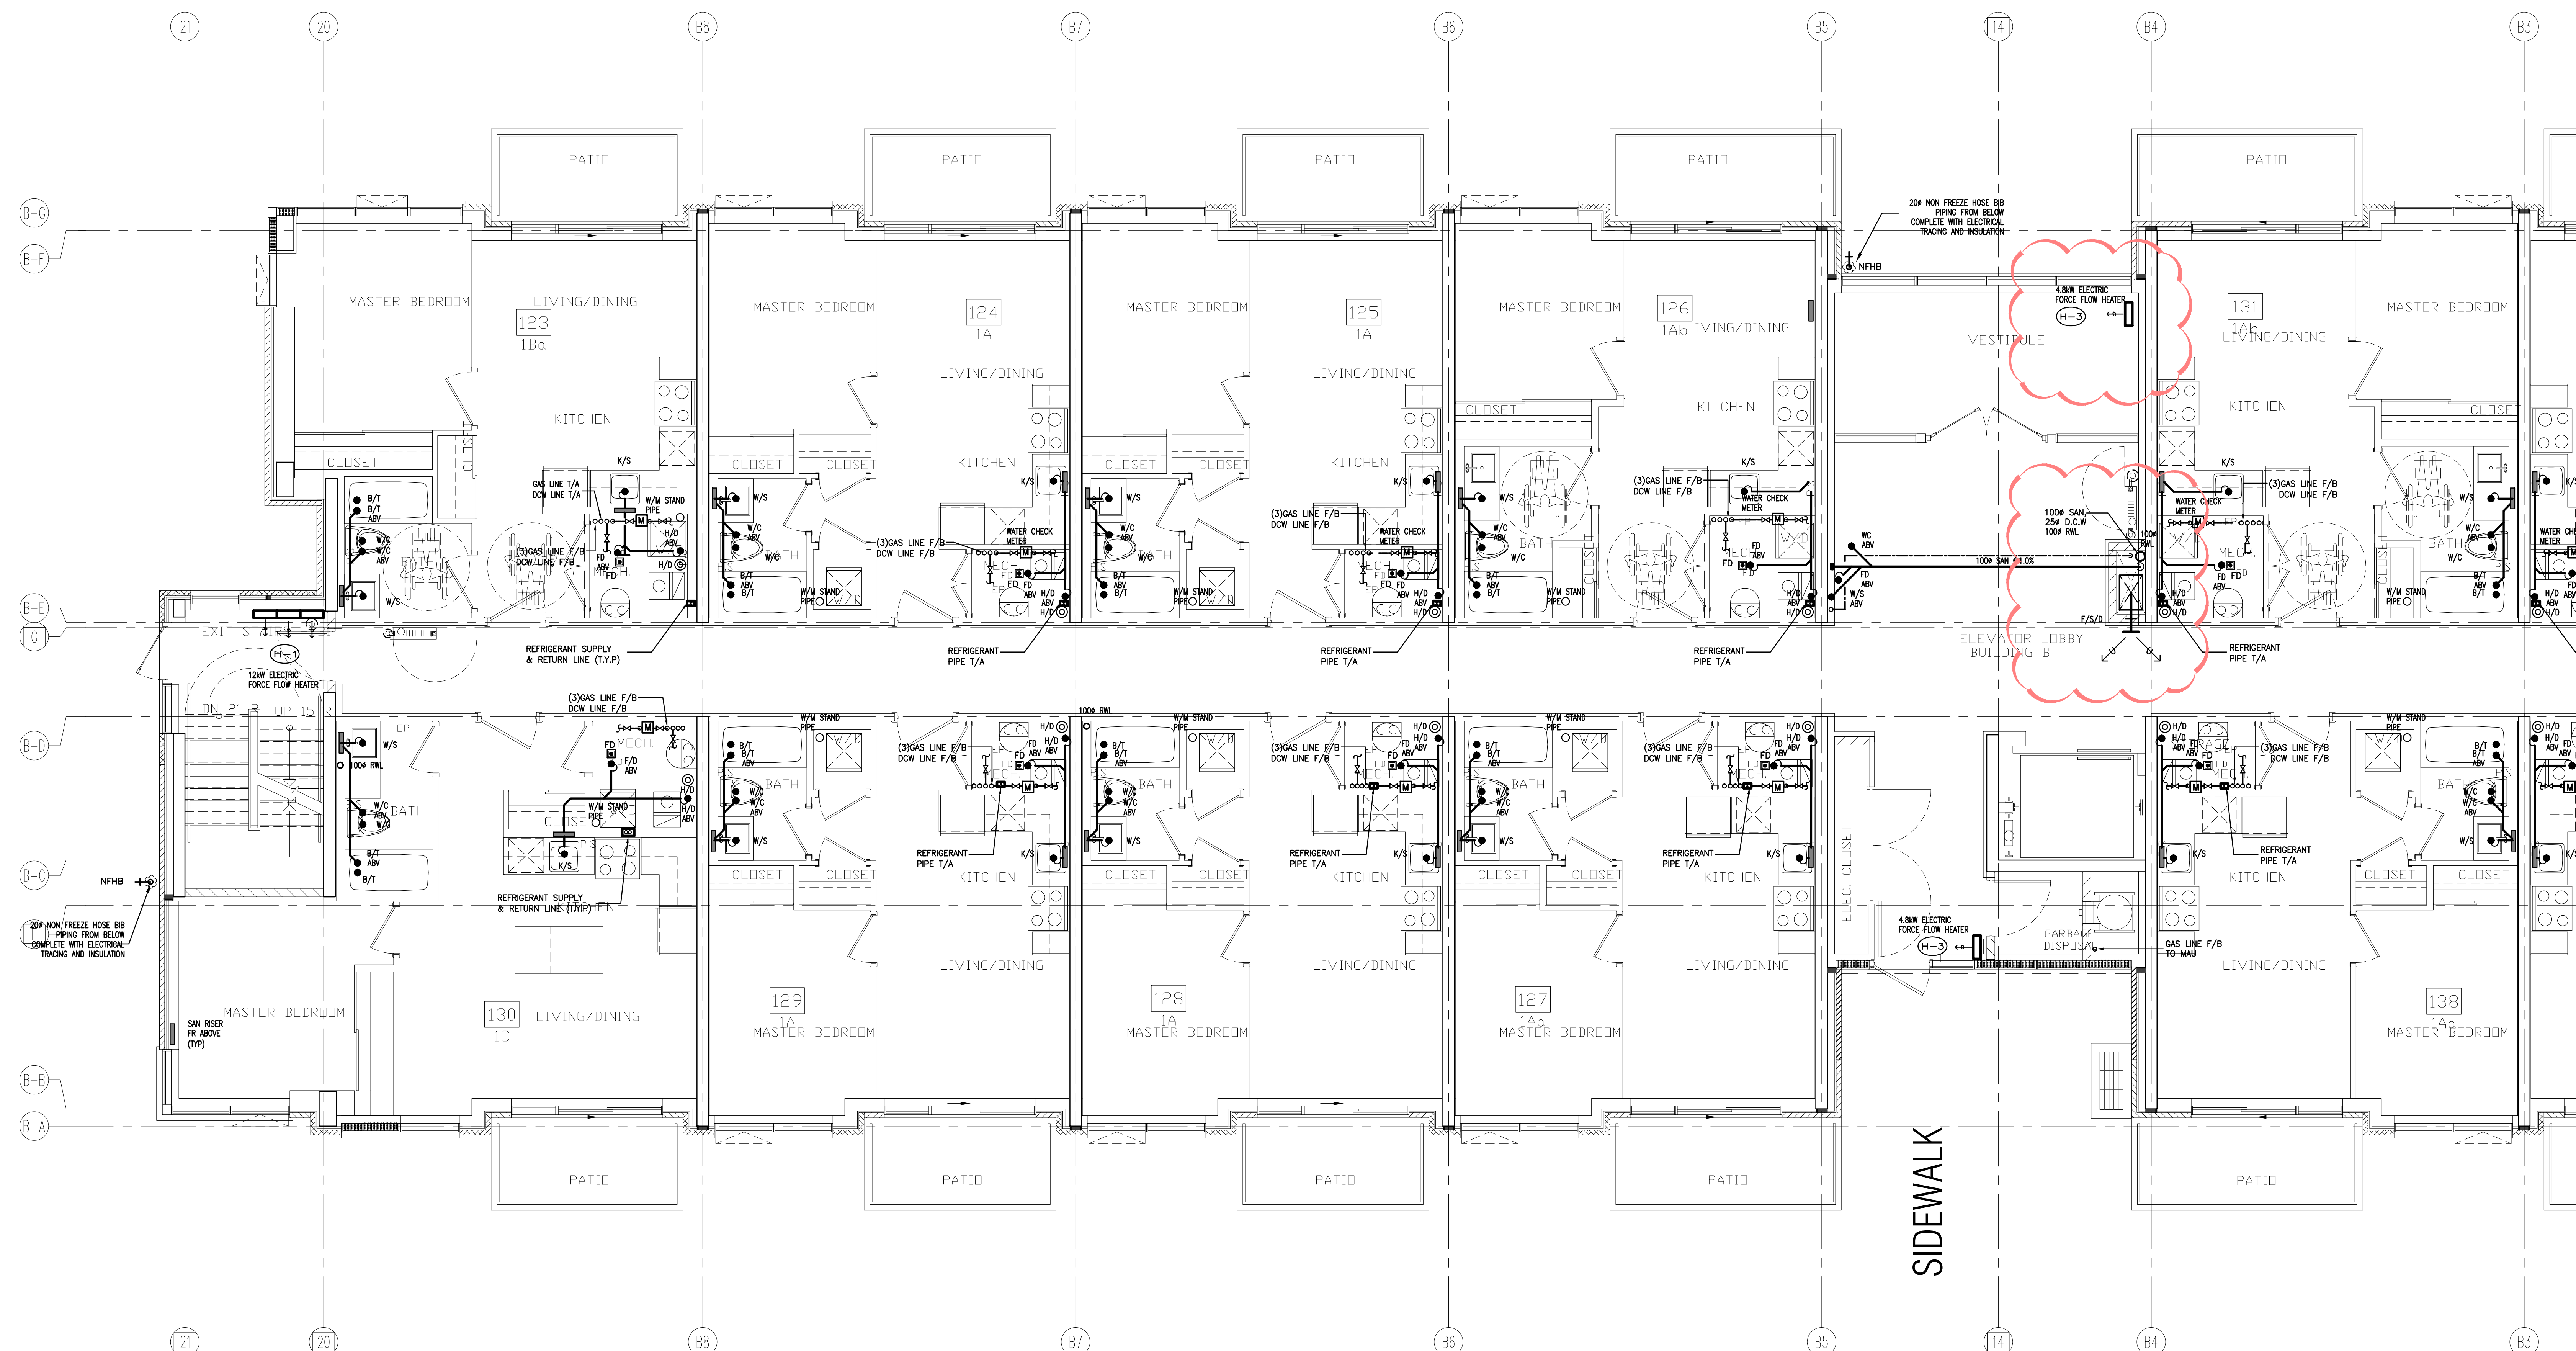

07	LB	ISSUED AS PER SITE INSTRUCTION M-02	JUN. 04, 2021
06	LB	ISSUED FOR PROGRESSIVE CONSTRUCTION	MAR. 26, 2021
05	LB	ISSUED FOR PERMIT BUILDING A,B,C,D	MAR. 03, 2021
04	LB	ISSUED AS PER ADDENDUM M-05	JAN. 20, 2021
03	LB	ISSUED FOR PERMIT	SEP. 28, 2020
02	RC	ADDENDUM #04	JUN. 12, 2020
01	RC	ISSUED FOR TENDER	AUG. 02, 2019
NO.	BY	DESCRIPTION	DATE


REVISIONS


This drawing, is an instrument of service, is provided by and is the property of United Engineering Inc. The contractor must verify and accept responsibility for all dimensions and conditions on site and must notify United Engineering Inc. of any discrepancy before proceeding.

United Engineering Inc. is not responsible for the accuracy of Architectural, structural, interior design, etc. on this drawing.

Refer to the appropriate trade drawings before proceeding with any work. Installation must conform to all applicable codes and requirements of the authorities having jurisdiction.

This drawing is not to be scaled, all symbols are graphic representations only.

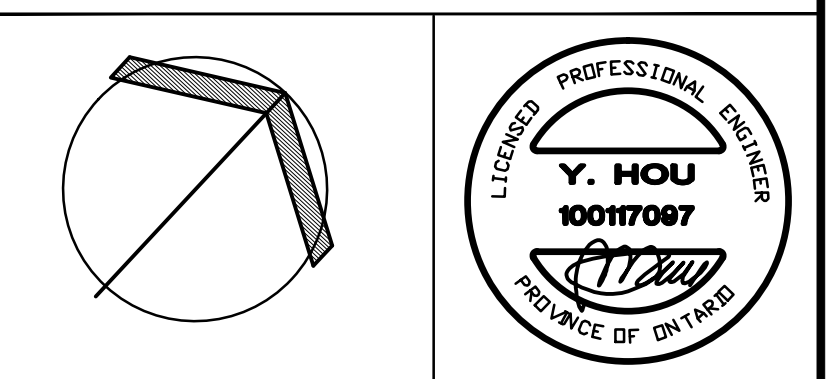


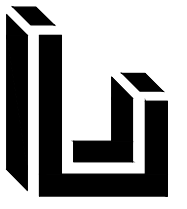**UNITED ENGINEERING INC.**
Mechanical Electrical Consulting Engineers
3645 Keele Street, Suite 105,
Toronto, Ontario, M3J 1M6
Tel: (416) 398 1999, Fax: (416) 398 1933

TITLE
BLOCK 'B'
GROUND FLOOR - PLUMBING/SANITARY

PROJECT
BRAMPTON STACKED
FORESTSIDE ESTATES
ATTMAR + PALLESCHI DRIVE
BRAMPTON, ONTARIO

DRAWN	CHECKED	SCALE
MC	LM	1:50
DATE	PROJECT	DRAWING
MAY, 2019	18-017	M-25
		OF

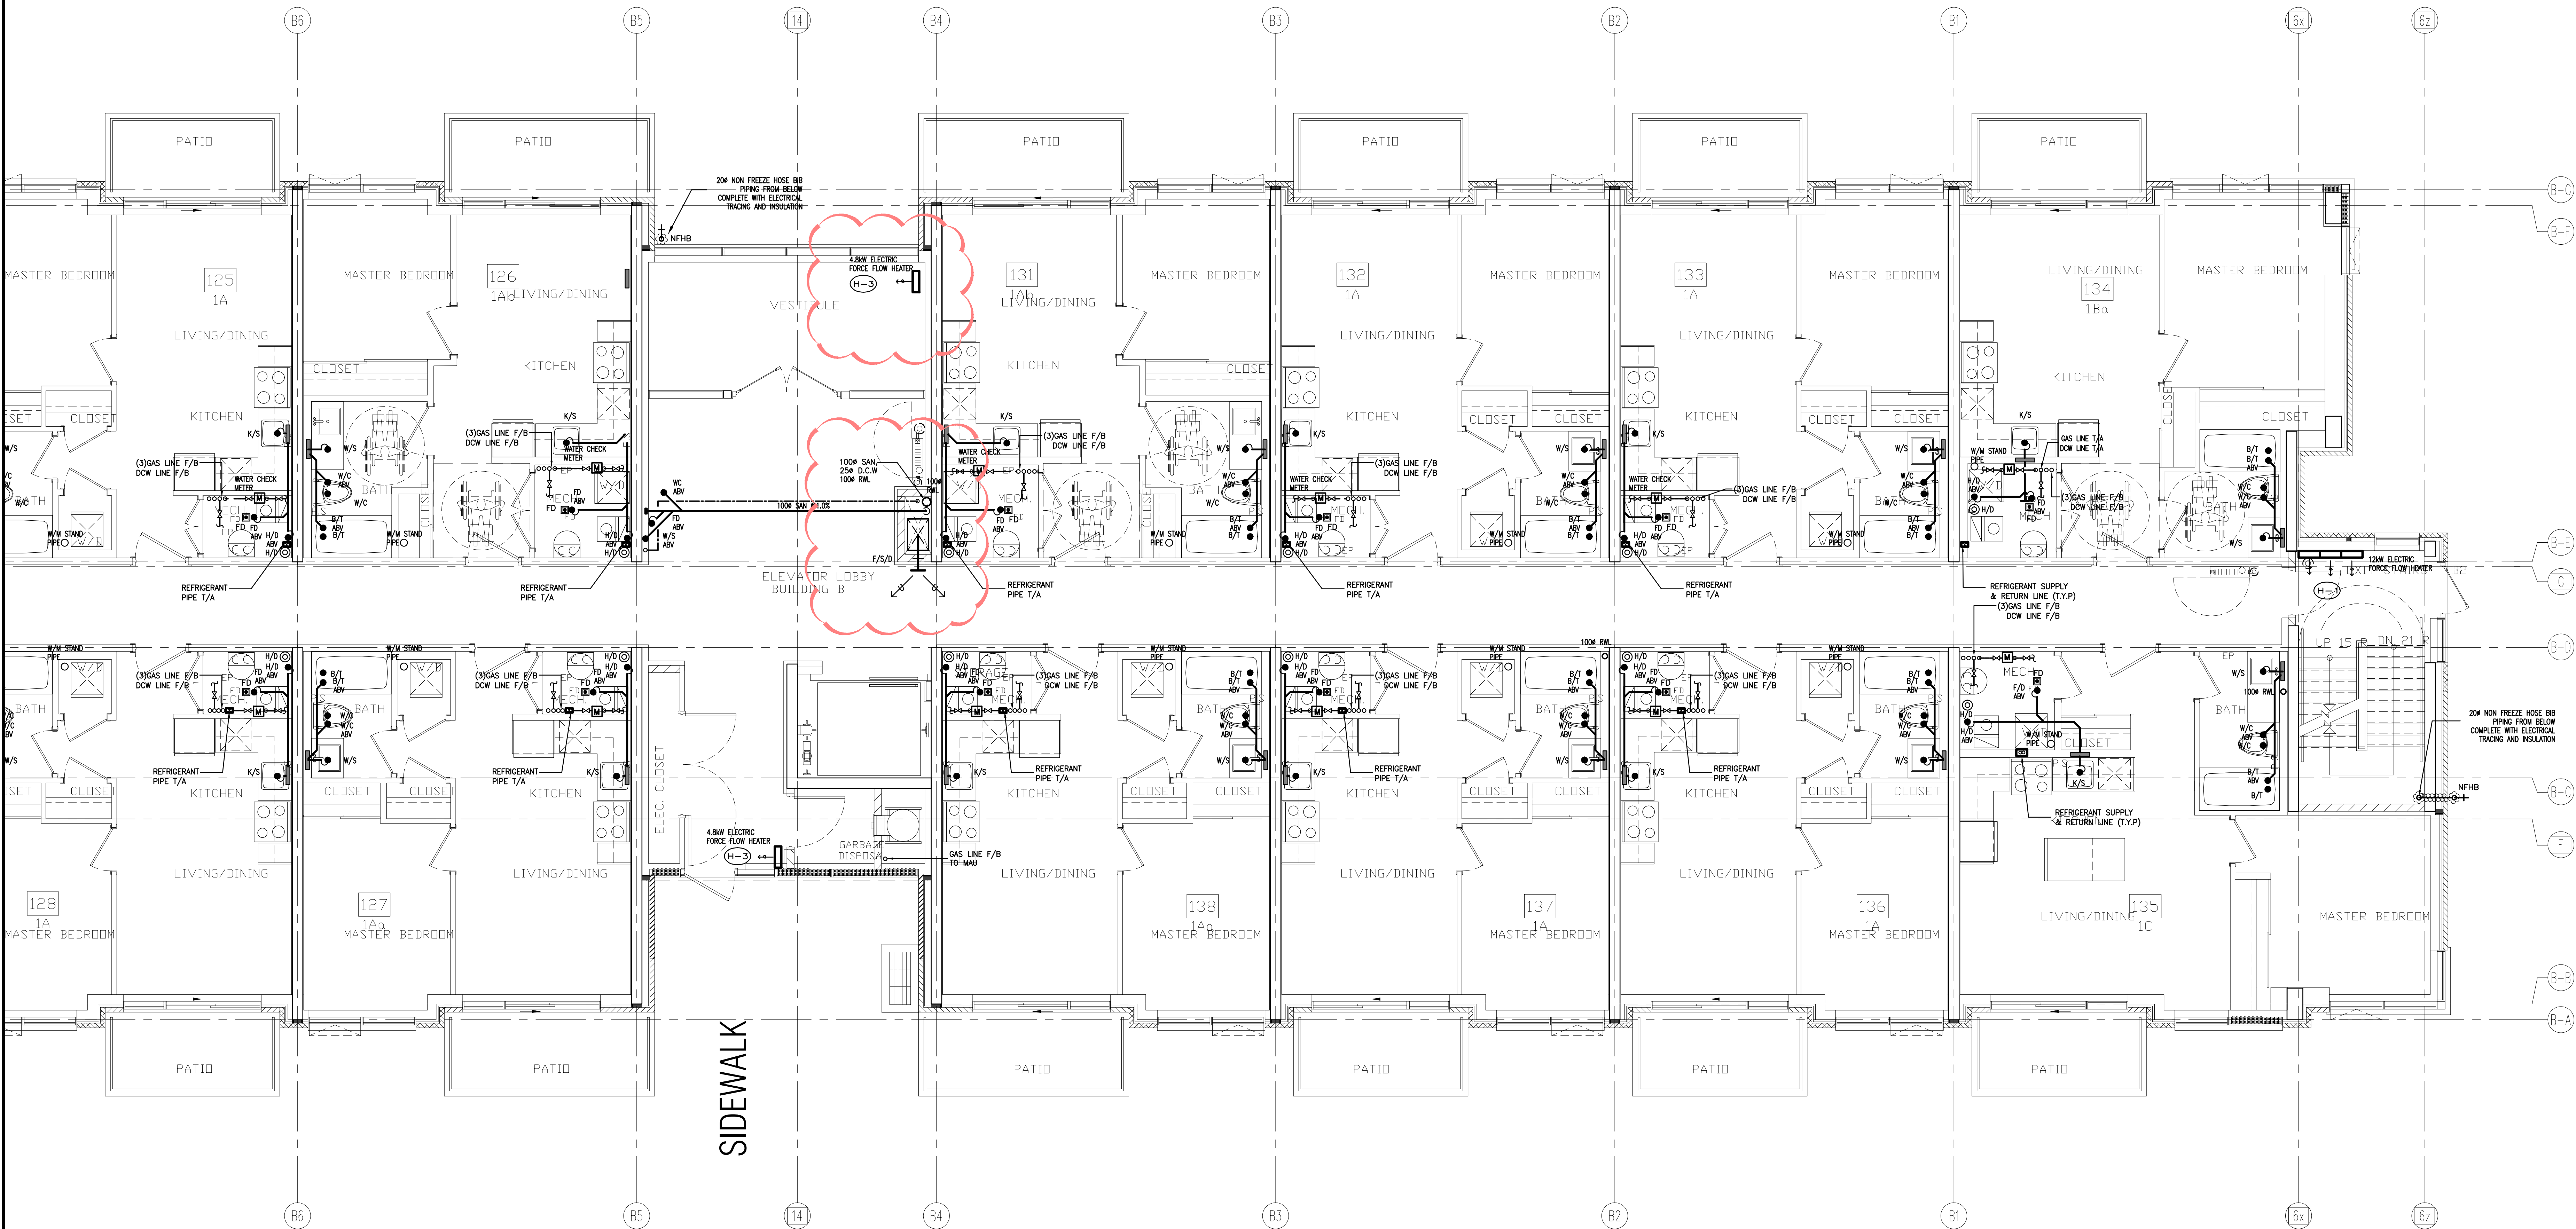

NO.	BY	DESCRIPTION	DATE
08	LB	ISSUED AS PER SITE INSTRUCTION M-02	JUN. 04, 2021
07	LB	ISSUED FOR PROGRESSIVE CONSTRUCTION	MAR. 26, 2021
06	LB	ISSUED AS PER ADDENDUM M-06	MAR. 25, 2021
05	LB	ISSUED FOR PERMIT BUILDING A,B,C,D	MAR. 03, 2021
04	LB	ISSUED AS PER ADDENDUM M-05	JAN. 20, 2021
03	LB	ISSUED FOR PERMIT	SEP. 28, 2020
02	RC	ADDENDUM #04	JUN. 12, 2020
01	RC	ISSUED FOR TENDER	AUG. 02, 2019



REVISIONS

This drawing is an instrument of service, is provided by and is the property of United Engineering Inc. The contractor must verify and accept responsibility for all dimensions and conditions on site and must notify United Engineering Inc. of any discrepancy before proceeding.

United Engineering Inc. is not responsible for the accuracy of Architectural, structural, interior design, etc., on this drawing.

Refer to the appropriate trade drawings before proceeding with any work. Installation must conform to all applicable codes and requirements of the authorities having jurisdiction.

This drawing is not to be scaled, all symbols are graphic representations only.

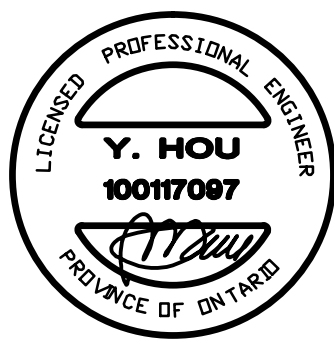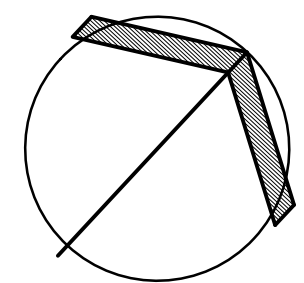

UNITED ENGINEERING INC.
Mechanical Electrical Consulting Engineers
3645 Keele Street, Suite 105,
Toronto, Ontario, M3J 1M6
Tel: (416) 398 1999, Fax: (416) 398 1933


TITLE
**BLOCK 'B'
GROUND FLOOR - PLUMBING/SANITARY**

PROJECT

**BRAMPTON STACKED
FORESTSIDE ESTATES**

**ATTMAR + PALLESCHI DRIVE
BRAMPTON, ONTARIO**

DRAWN	CHECKED	SCALE
MC	LM	1:50
DATE	PROJECT	DRAWING
MAY, 2019	18-017	M-26
		OF

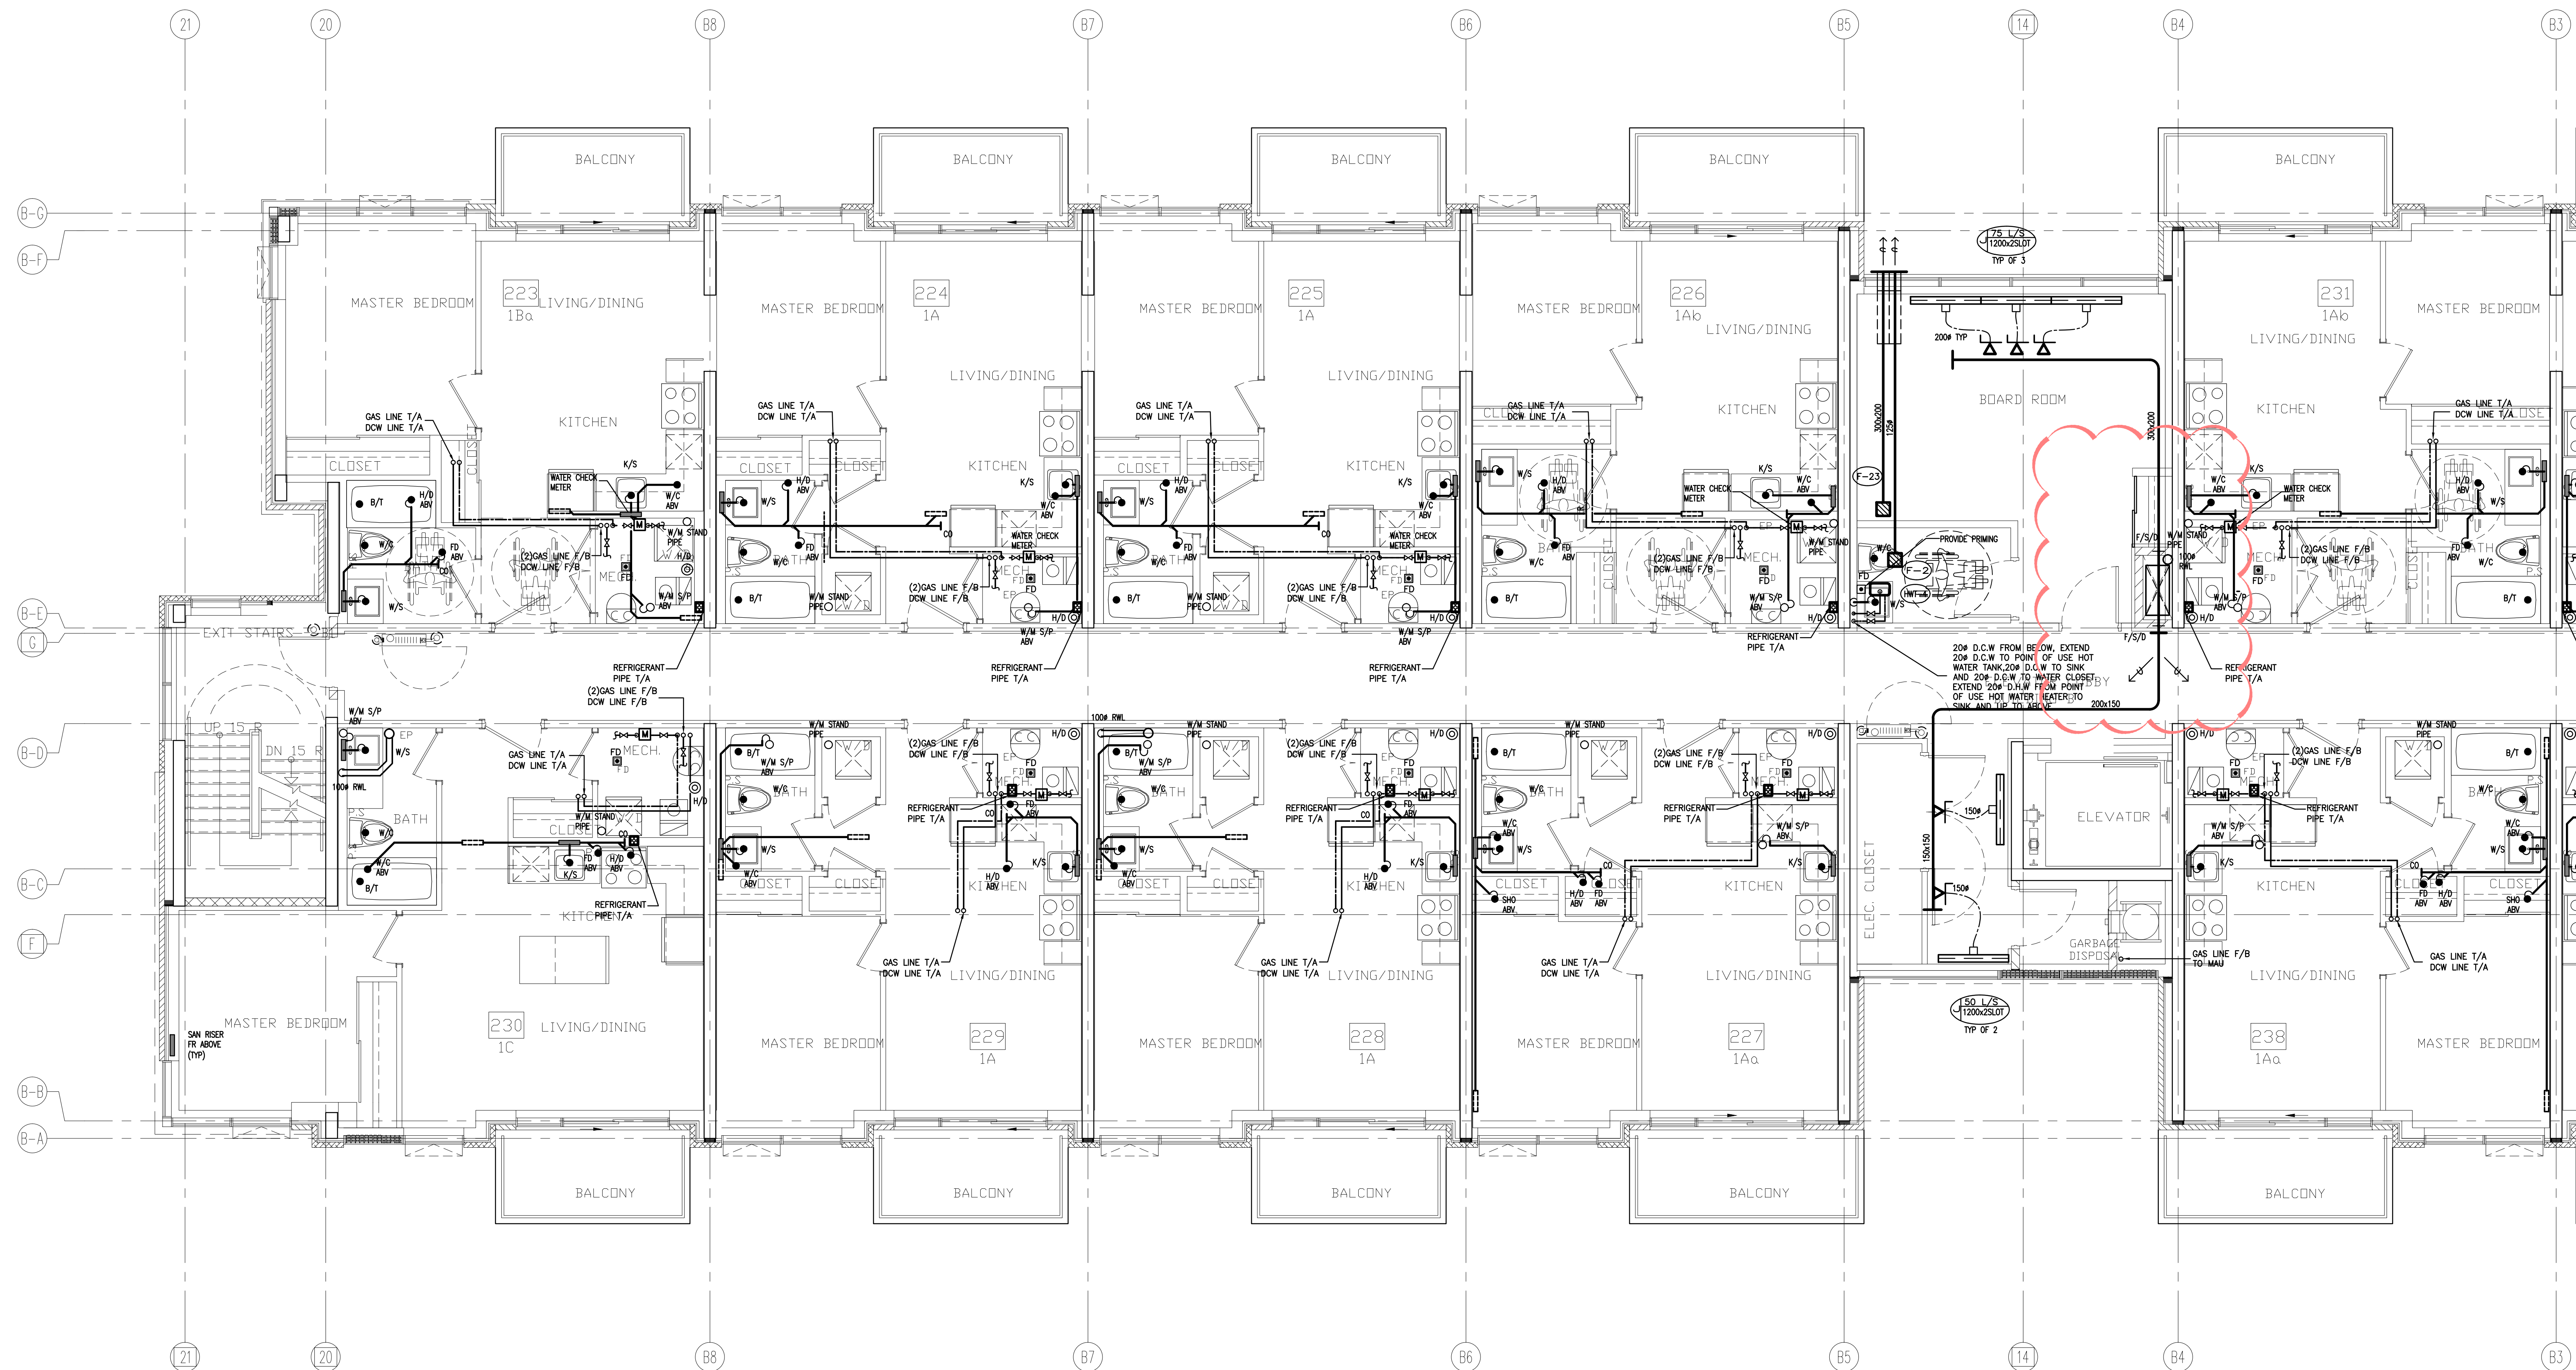

NO.	BY	DESCRIPTION	DATE
07	LB	ISSUED AS PER SITE INSTRUCTION M-02	JUN. 04, 2021
06	LB	ISSUED FOR PROGRESSIVE CONSTRUCTION	MAR. 26, 2021
05	LB	ISSUED FOR PERMIT BUILDING A,B,C,D	MAR. 03, 2021
04	LB	ISSUED AS PER ADDENDUM M-05	JAN. 20, 2021
03	LB	ISSUED FOR PERMIT	SEP. 28, 2020
02	RC	ADDENDUM #04	JUN. 12, 2020
01	RC	ISSUED FOR TENDER	AUG. 02, 2019


REVISIONS

This drawing is an instrument of service, is provided by and is the property of United Engineering Inc. The contractor must verify and accept responsibility for all dimensions and conditions on site and must notify United Engineering Inc. of any discrepancy before proceeding.

United Engineering Inc. is not responsible for the accuracy of Architectural, structural, interior design, etc. on this drawing.


Refer to the appropriate trade drawings before proceeding with any work. Installation must conform to all applicable codes and requirements of the authorities having jurisdiction.

This drawing is not to be scaled, all symbols are graphic representations only.

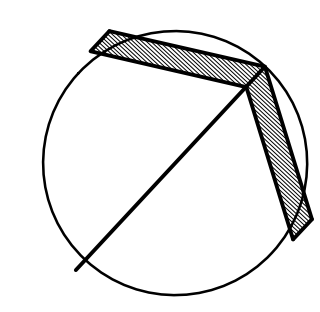

UNITED ENGINEERING INC.
Mechanical Electrical Consulting Engineers
3645 Keele Street, Suite 105,
Toronto, Ontario, M3J 1M6
Tel: (416) 398 1599, Fax: (416) 398 1933

TITLE BLOCK 'B' 2ND FLOOR - PLUMBING/SANITARY		
PROJECT BRAMPTON STACKED FORESTSIDE ESTATES		
ATTMAR + PALLESCHI DRIVE BRAMPTON, ONTARIO		
DRAWN MC	CHECKED LM	SCALE 1:50
DATE MAY, 2019	PROJECT 18-017	DRAWING M-27 OF -

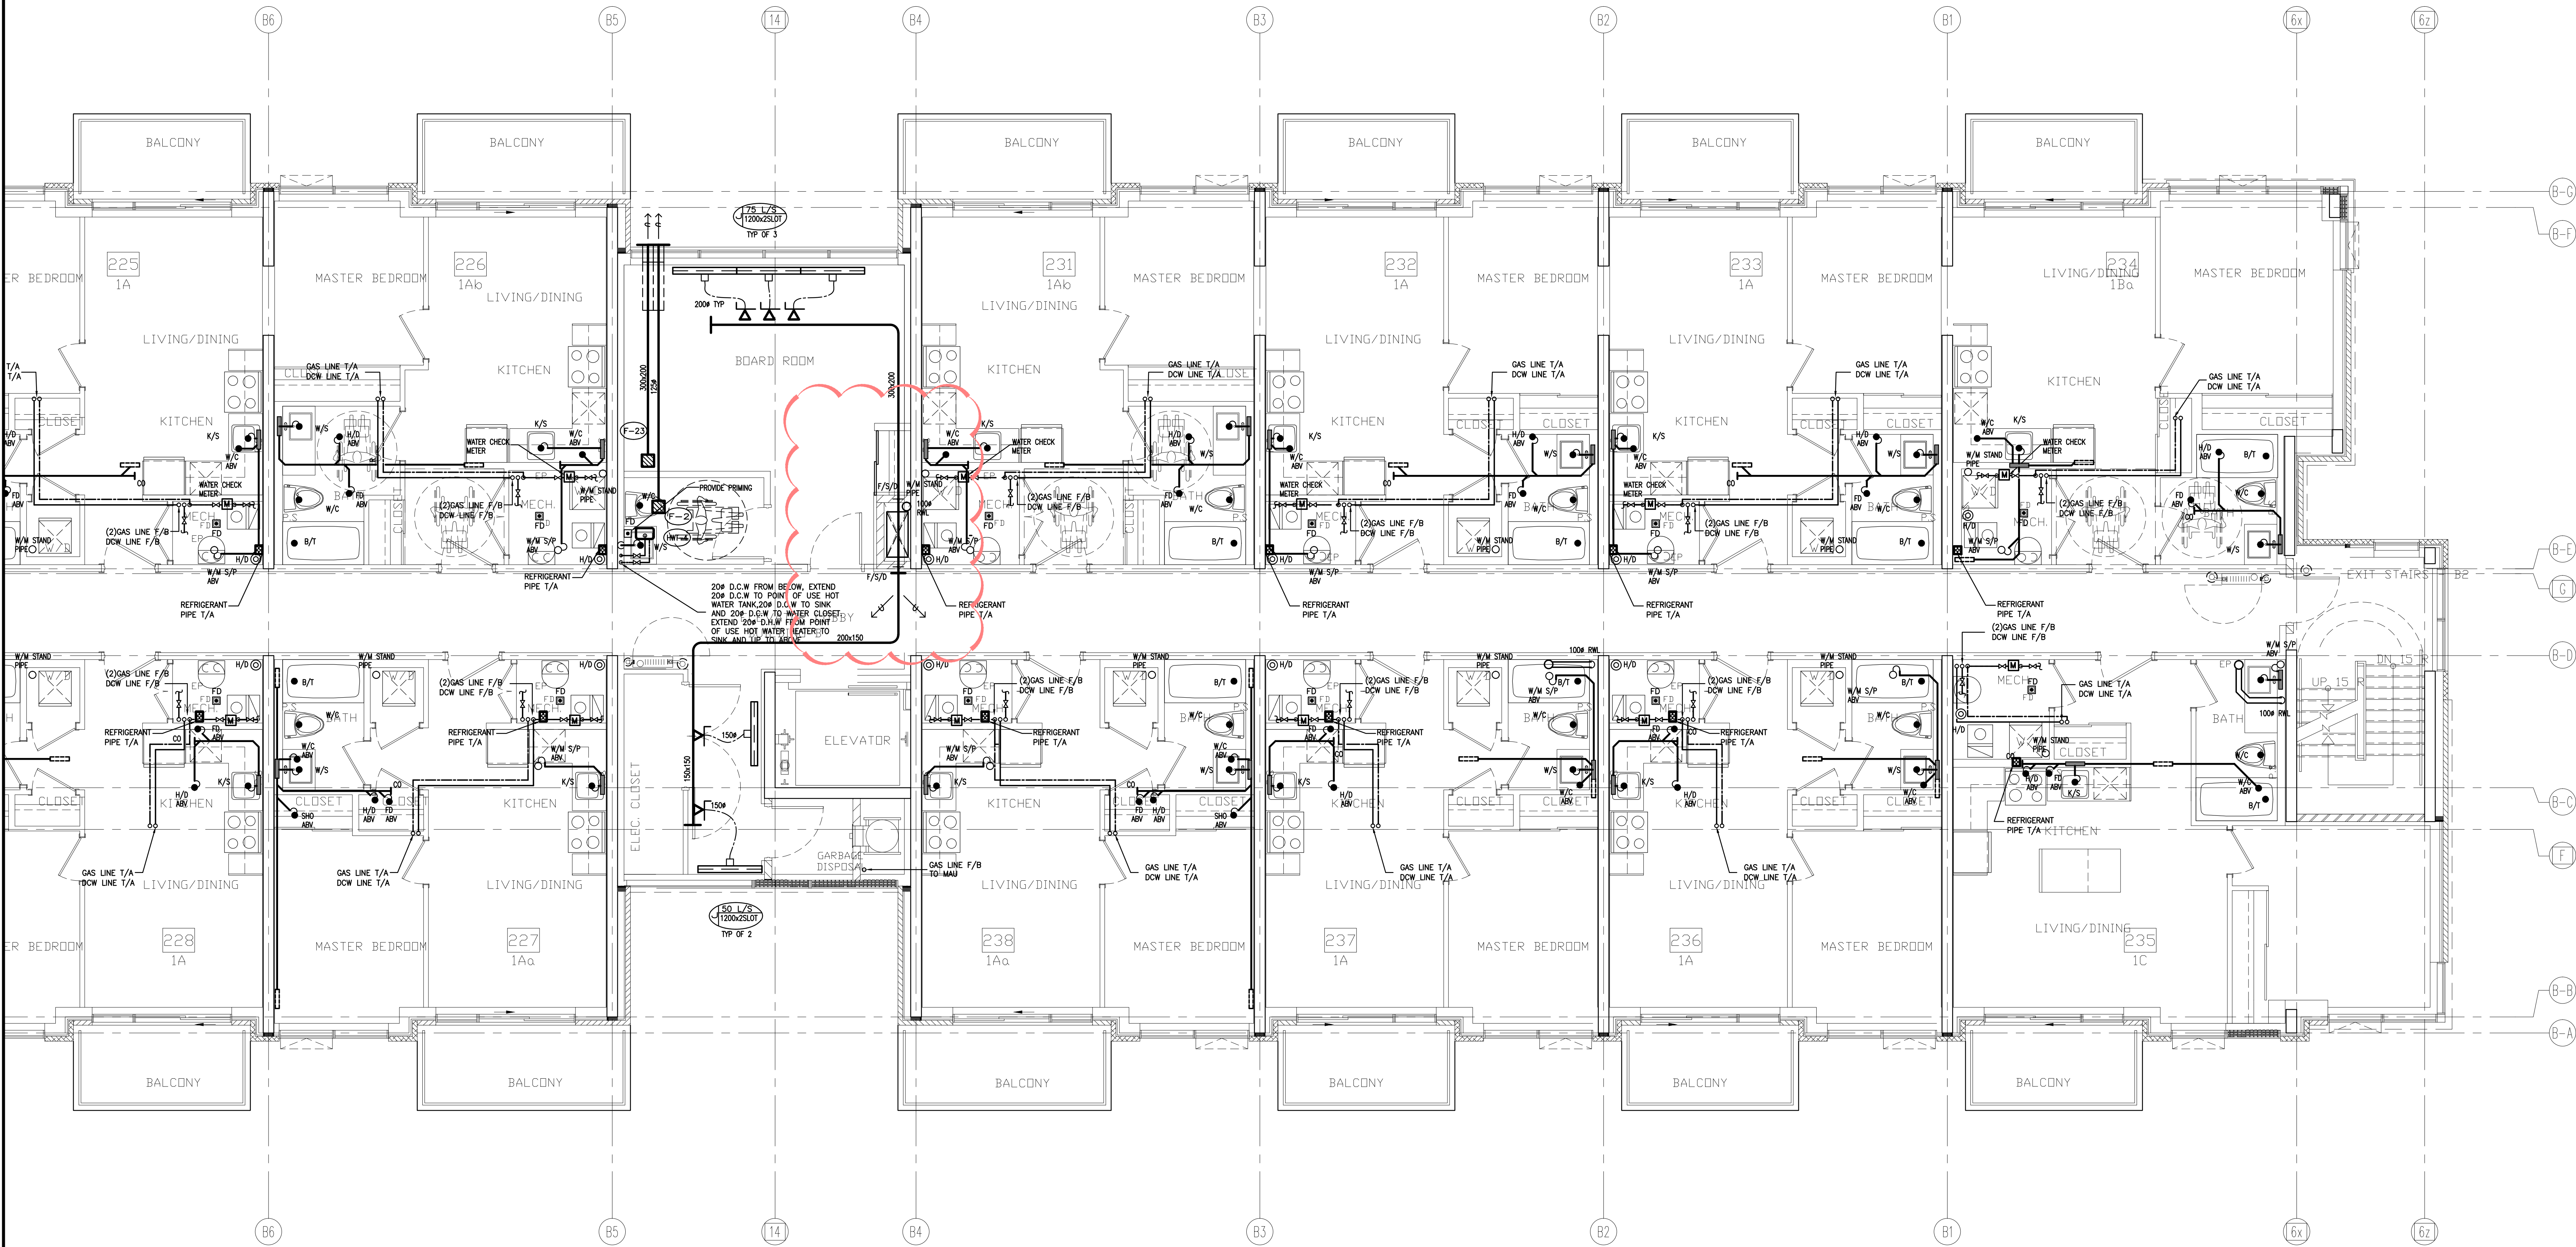

NO.	BY	DESCRIPTION	DATE
08	LB	ISSUED AS PER SITE INSTRUCTION M-02	JUN. 04, 2021
07	LB	ISSUED FOR PROGRESSIVE CONSTRUCTION	MAR. 26, 2021
06	LB	ISSUED AS PER ADDENDUM M-06	MAR. 25, 2021
05	LB	ISSUED FOR PERMIT BUILDING A.B.C.D	MAR. 03, 2021
04	LB	ISSUED AS PER ADDENDUM M-05	JAN. 20, 2021
03	LB	ISSUED FOR PERMIT	SEP. 28, 2020
02	RC	ADDENDUM #04	JUN. 12, 2020
01	RC	ISSUED FOR TENDER	AUG. 02, 2019


REVISIONS

This drawing is an instrument of service, is provided by and is the property of United Engineering Inc. The contractor must verify and accept responsibility for all dimensions and conditions on site and must notify United Engineering Inc. of any discrepancy before proceeding.

United Engineering Inc. is not responsible for the accuracy of Architectural, structural, interior design, etc., on this drawing.

Refer to the appropriate trade drawings before proceeding with any work. Installation must conform to all applicable codes and requirements of the authorities having jurisdiction.

This drawing is not to be scaled, all symbols are graphic representations only.

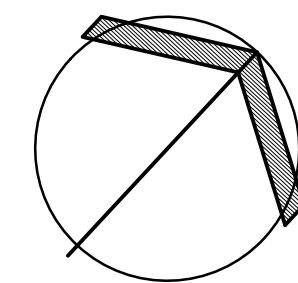

UNITED ENGINEERING INC.
Mechanical Electrical Consulting Engineers
3645 Keele Street, Suite 105,
Toronto, Ontario, M3J 1M6
Tel: (416) 398 1999, Fax: (416) 398 1933

TITLE
BLOCK 'B'
2ND FLOOR - PLUMBING/SANITARY

PROJECT

**BRAMPTON STACKED
FORESTSIDE ESTATES**

**ATTMAR + PALLESCI DRIVE
BRAMPTON, ONTARIO**

DRAWN	CHECKED	SCALE
MC	LM	1:50
DATE	PROJECT	DRAWING
MAY, 2019	18-017	M-28
		OF -



NO.	BY	DESCRIPTION	DATE
07	LB	ISSUED AS PER SITE INSTRUCTION M-02	JUN. 04, 2021
06	LB	ISSUED FOR PROGRESSIVE CONSTRUCTION	MAR. 26, 2021
05	LB	ISSUED FOR PERMIT BUILDING A,B,C,D	MAR. 03, 2021
04	LB	ISSUED AS PER ADDENDUM M-05	JAN. 20, 2021
03	LB	ISSUED FOR PERMIT	SEP. 28, 2020
02	RC	ADDENDUM #04	JUN. 12, 2020
01	RC	ISSUED FOR TENDER	AUG. 02, 2019


REVISIONS

This drawing, is an instrument of service, is provided by and is the property of United Engineering Inc. The contractor must verify and accept responsibility for all dimensions and conditions on site and must notify United Engineering Inc. of any discrepancy before proceeding.

United Engineering Inc. is not responsible for the accuracy of Architectural, structural, interior design, etc., on this drawing.

Refer to the appropriate trade drawings before proceeding with any work. Installation must conform to all applicable codes and requirements of the authorities having jurisdiction.

This drawing is not to be scaled, all symbols are graphic representations only.

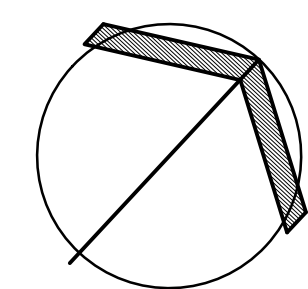

UNITED ENGINEERING INC.
Mechanical Electrical Consulting Engineers
3645 Keele Street, Suite 105,
Toronto, Ontario, M3J 1M6
Tel: (416) 398 1999, Fax: (416) 398 1933


TITLE
BLOCK 'B'
3RD FLOOR - PLUMBING/SANITARY

PROJECT

**BRAMPTON STACKED
FORESTSIDE ESTATES**

**ATTMAR + PALLESCHI DRIVE
BRAMPTON, ONTARIO**

DRAWN MC	CHECKED LM	SCALE 1:50
DATE MAY, 2019	PROJECT 18-017	DRAWING M-29 OF -

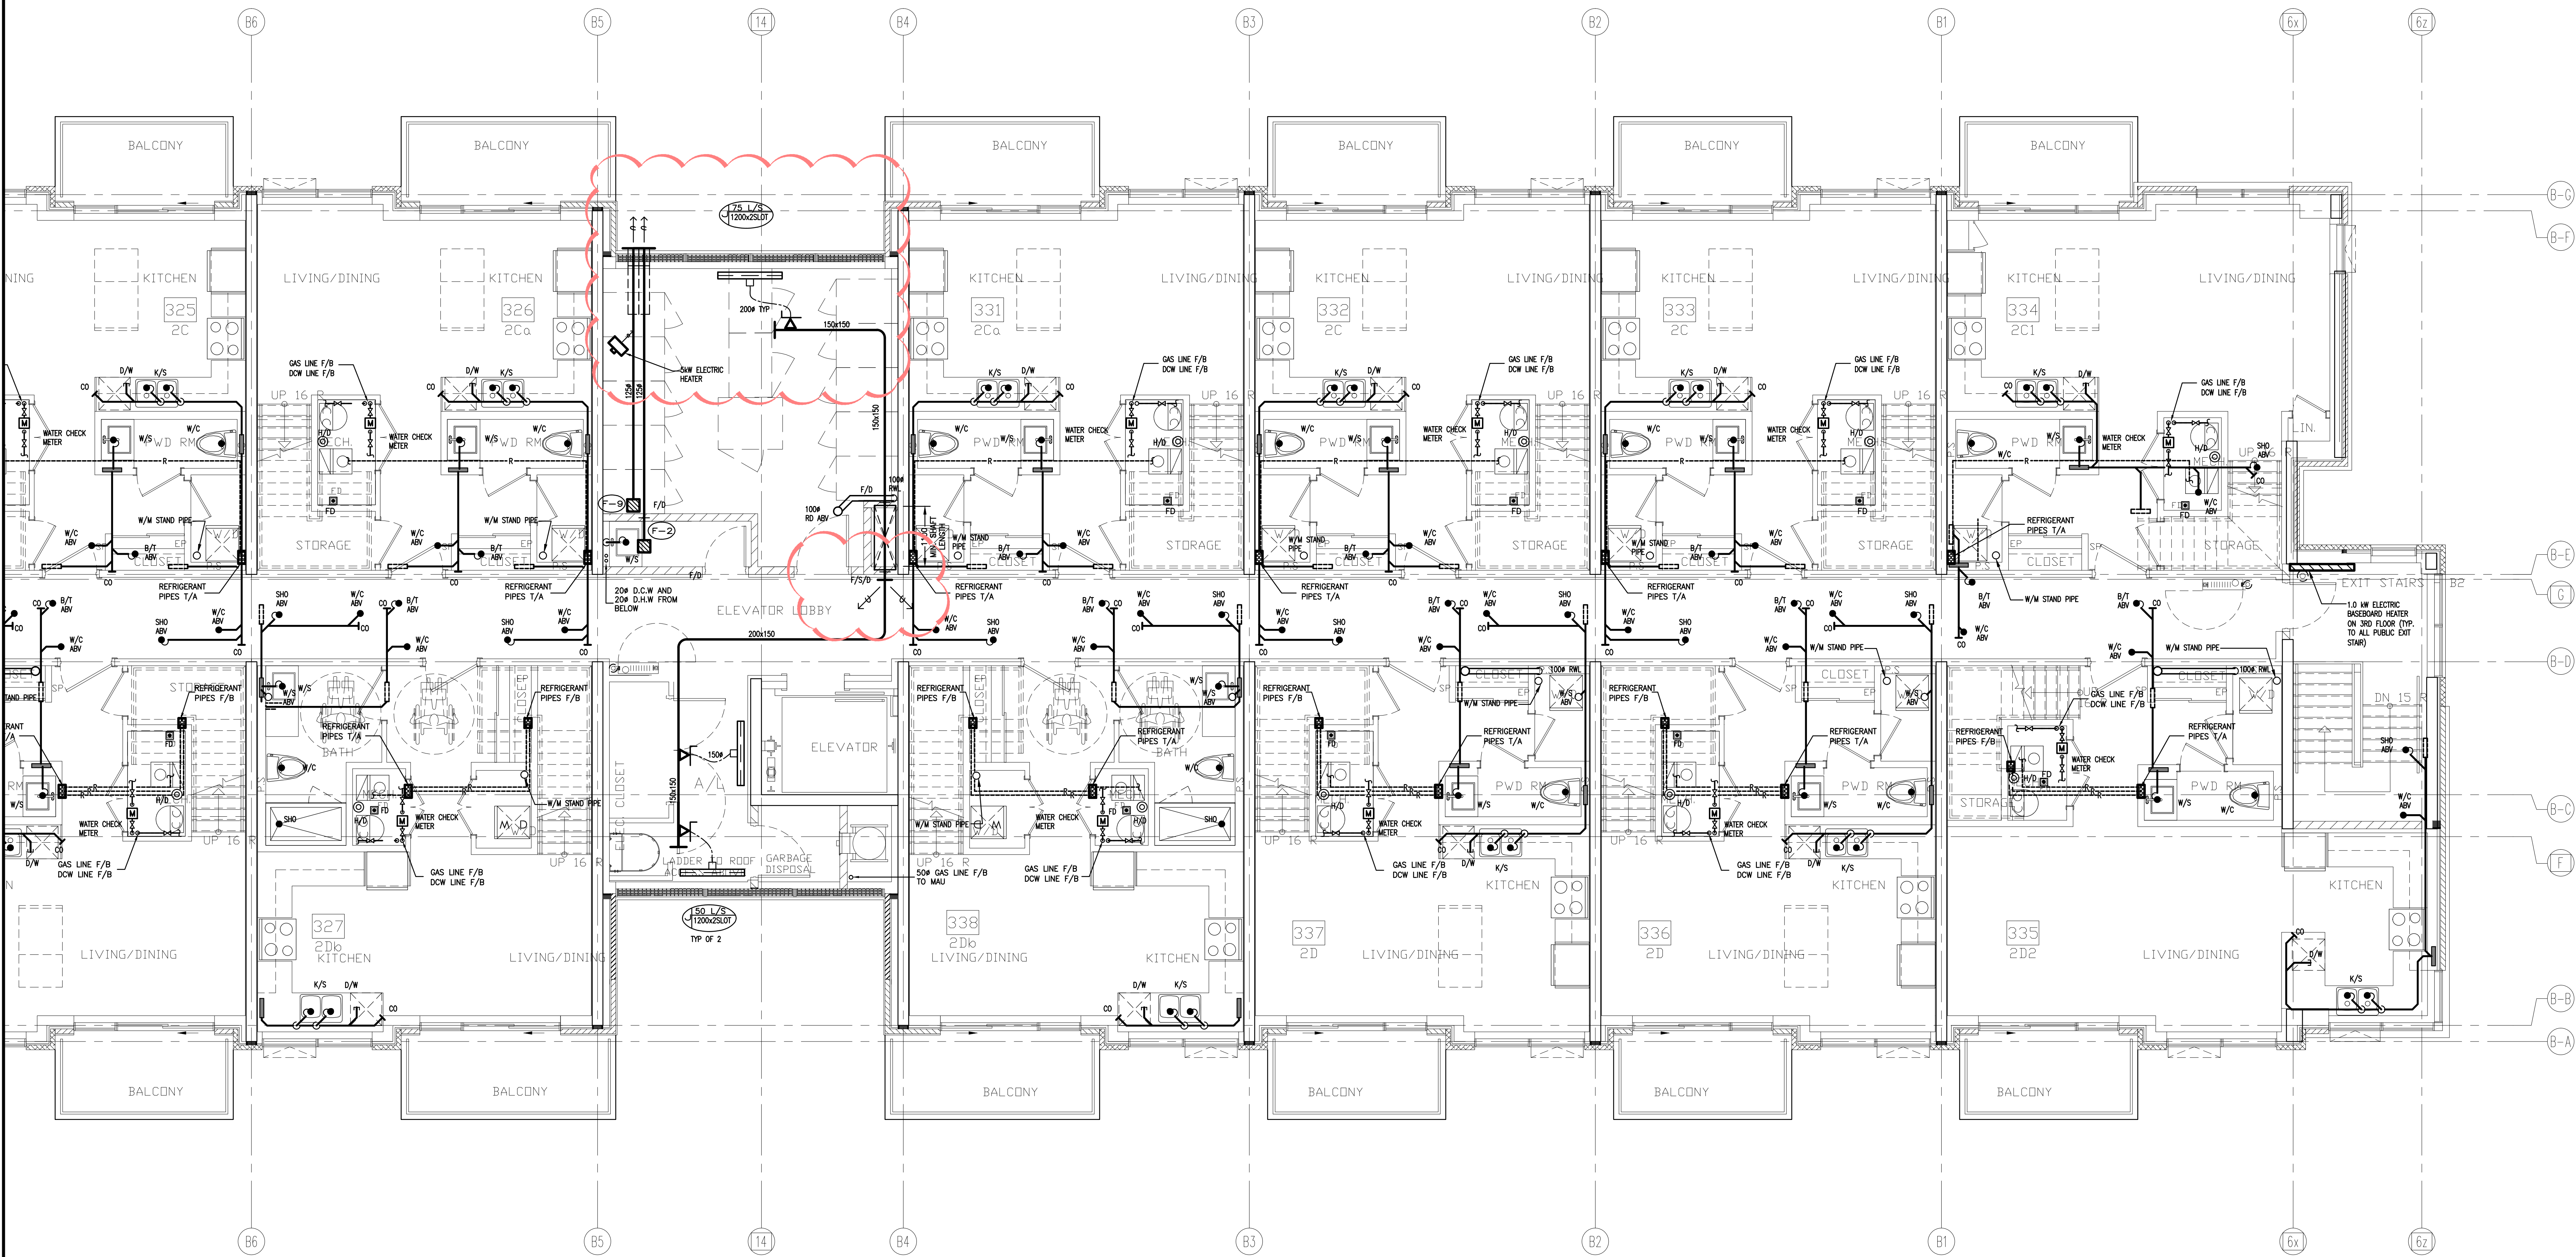

NO.	BY	DESCRIPTION	DATE
09	LB	ISSUED AS PER SITE INSTRUCTION M-02	JUN. 04, 2021
08	LB	ISSUED AS PER SITE INSTRUCTION M-01	APR. 28, 2021
07	LB	ISSUED FOR PROGRESSIVE CONSTRUCTION	MAR. 26, 2021
06	LB	ISSUED AS PER ADDENDUM M-06	MAR. 25, 2021
05	LB	ISSUED FOR PERMIT BUILDING A,B,C,D	MAR. 03, 2021
04	LB	ISSUED AS PER ADDENDUM M-05	JAN. 20, 2021
03	LB	ISSUED FOR PERMIT	SEP. 28, 2020
02	RC	ADDENDUM #04	JUN. 12, 2020
01	RC	ISSUED FOR TENDER	AUG. 02, 2019


REVISIONS

This drawing is an instrument of service, is provided by and is the property of United Engineering Inc. The contractor must verify and accept responsibility for all dimensions and conditions on site and must notify United Engineering Inc. of any discrepancy before proceeding.

United Engineering Inc. is not responsible for the accuracy of Architectural, structural, interior design, etc., on this drawing.

Refer to the appropriate trade drawings before proceeding with any work. Installation must conform to all applicable codes and requirements of the authorities having jurisdiction.

This drawing is not to be scaled, and symbols are graphic representations only.

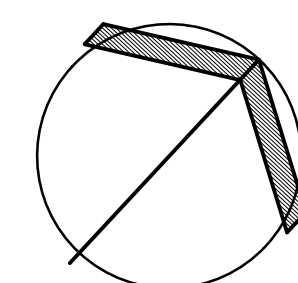

UNITED ENGINEERING INC.
Mechanical Electrical Consulting Engineers
3645 Keele Street, Suite 105,
Toronto, Ontario, M3J 1M6
Tel: (416) 398 1999, Fax: (416) 398 1933



TITLE
BLOCK 'B'
3RD FLOOR - PLUMBING/SANITARY

PROJECT

**BRAMPTON STACKED
FORESTSIDE ESTATES**

**ATTMAR + PALLESCHI DRIVE
BRAMPTON, ONTARIO**

DRAWN	CHECKED	SCALE
MC	LM	1:50
DATE	PROJECT	DRAWING
MAY, 2019	18-017	M-30
		OF

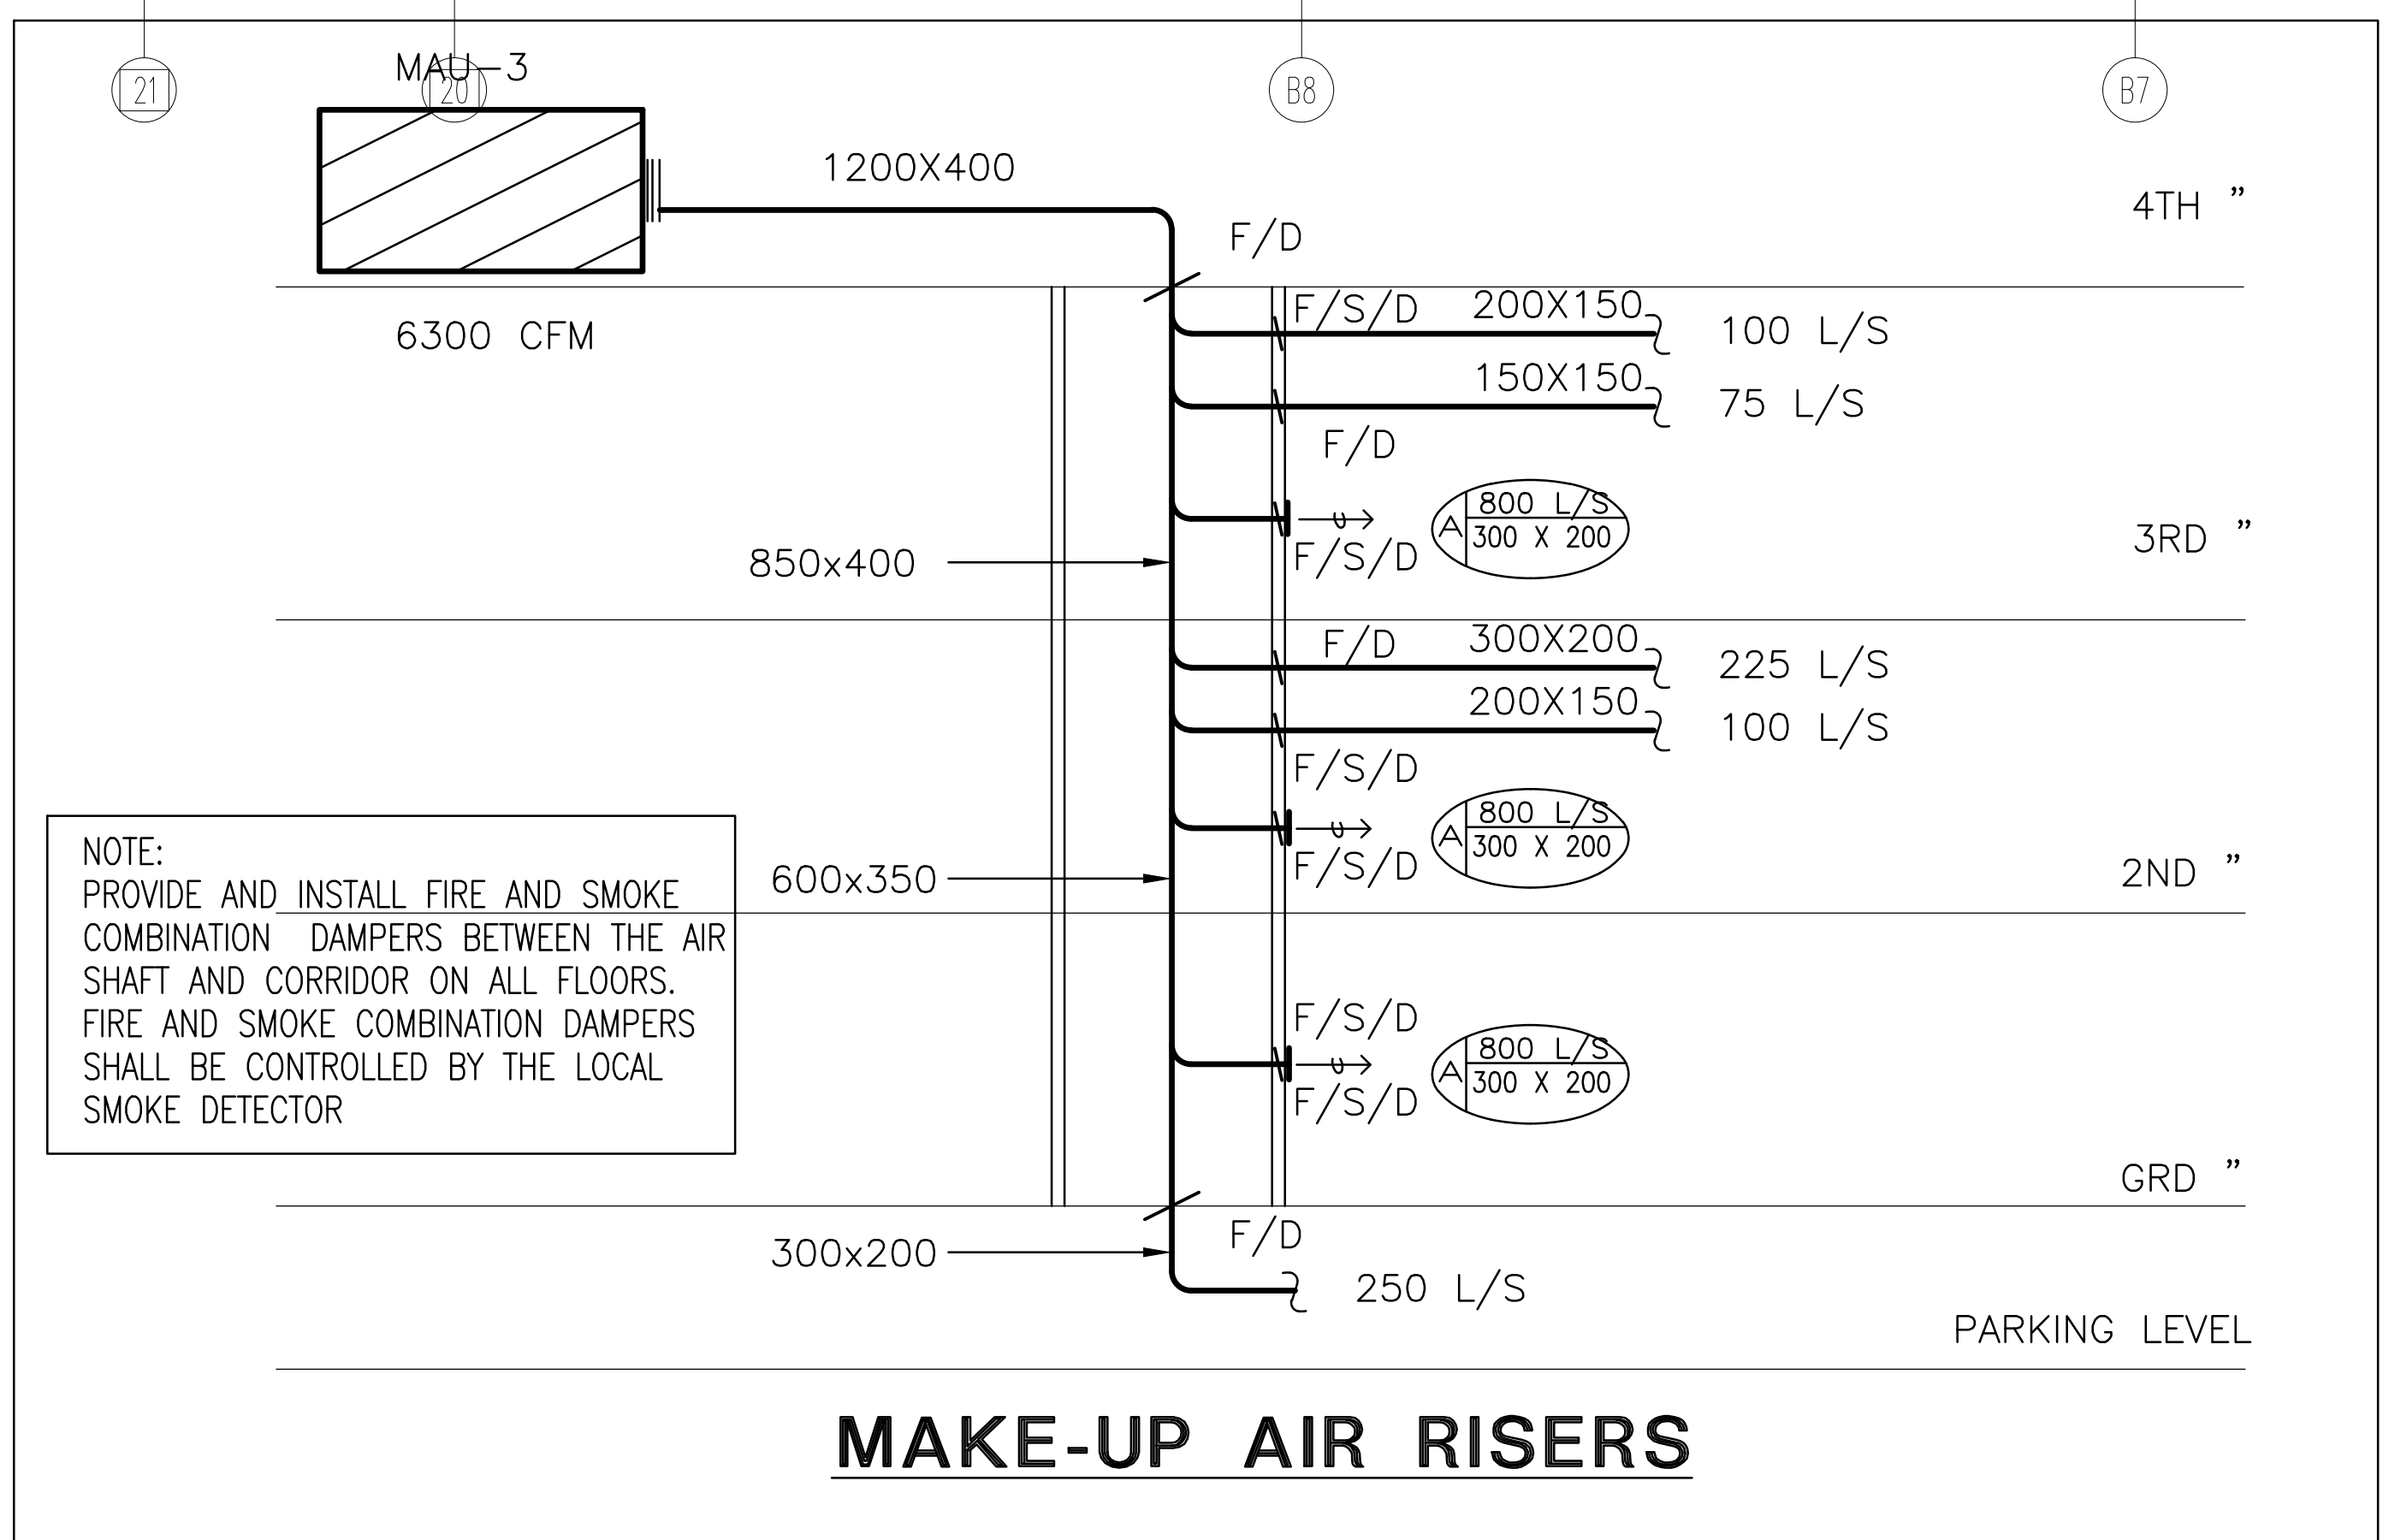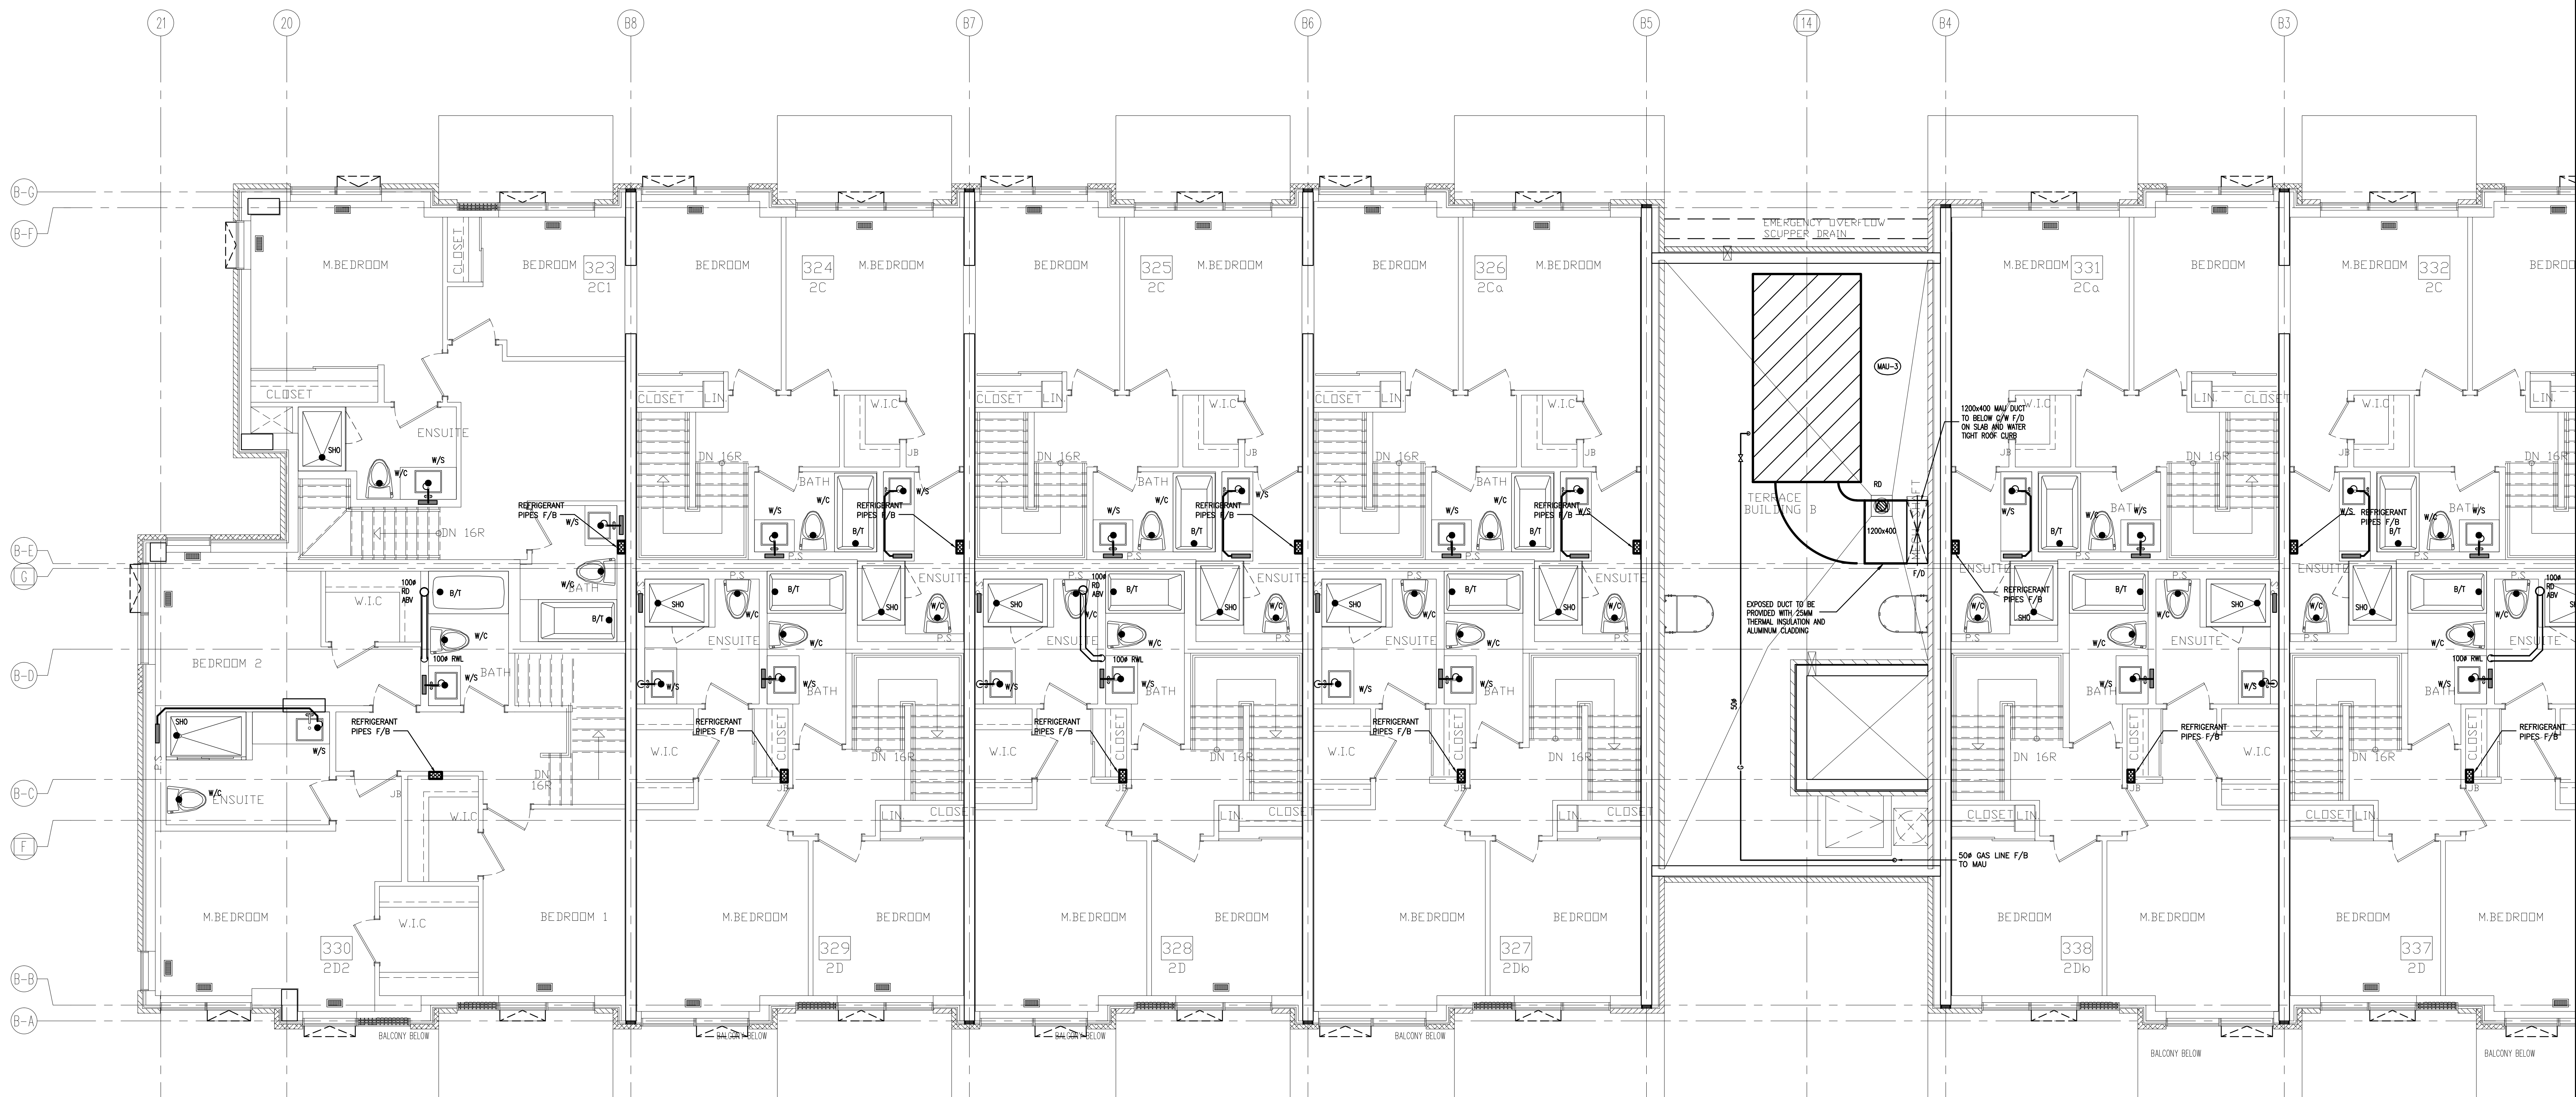

NO.	BY	DESCRIPTION	DATE
09	LB	ISSUED AS PER SITE INSTRUCTION M-02	JUN. 04, 2021
08	LB	ISSUED AS PER SITE INSTRUCTION M-01	APR. 28, 2021
07	LB	ISSUED FOR PROGRESSIVE CONSTRUCTION	MAR. 26, 2021
06	LB	ISSUED AS PER ADDENDUM M-06	MAR. 25, 2021
05	LB	ISSUED FOR PERMIT BUILDING A,B,C,D	MAR. 03, 2021
04	LB	ISSUED AS PER ADDENDUM M-05	JAN. 20, 2021
03	LB	ISSUED FOR PERMIT	SEP. 28, 2020
02	RC	ADDENDUM #04	JUN. 12, 2020
01	RC	ISSUED FOR TENDER	AUG. 02, 2019


REVISIONS

This drawing, is an instrument of service, is provided by and is the property of United Engineering Inc. The contractor must verify and accept responsibility for all dimensions and conditions on site and must notify United Engineering Inc. of any discrepancy before proceeding.

United Engineering Inc. is not responsible for the accuracy of Architectural, structural, interior design, etc., on this drawing.

Refer to the appropriate trade drawings before proceeding with any work. Installation must conform to all applicable codes and requirements of the authorities having jurisdiction.

This drawing is not to be scaled, all symbols are graphic representations only.

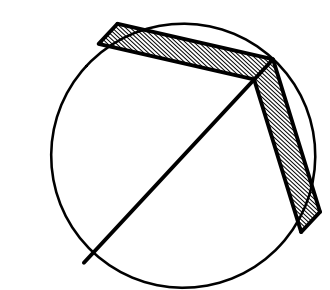

UNITED ENGINEERING INC.
Mechanical Electrical Consulting Engineers
3645 Keele Street, Suite 105,
Toronto, Ontario, M3J 1M6
Tel: (416) 398 1999, Fax: (416) 398 1933


TITLE
BLOCK 'B'
4TH FLOOR - PLUMBING/SANITARY

PROJECT

BRAMPTON STACKED FORESTSIDE ESTATES

**ATTMAR + PALLESCHI DRIVE
BRAMPTON, ONTARIO**

DRAWN	CHECKED	SCALE
MC	LM	1:50
DATE	PROJECT	DRAWING
MAY, 2019	18-017	M-31
		OF

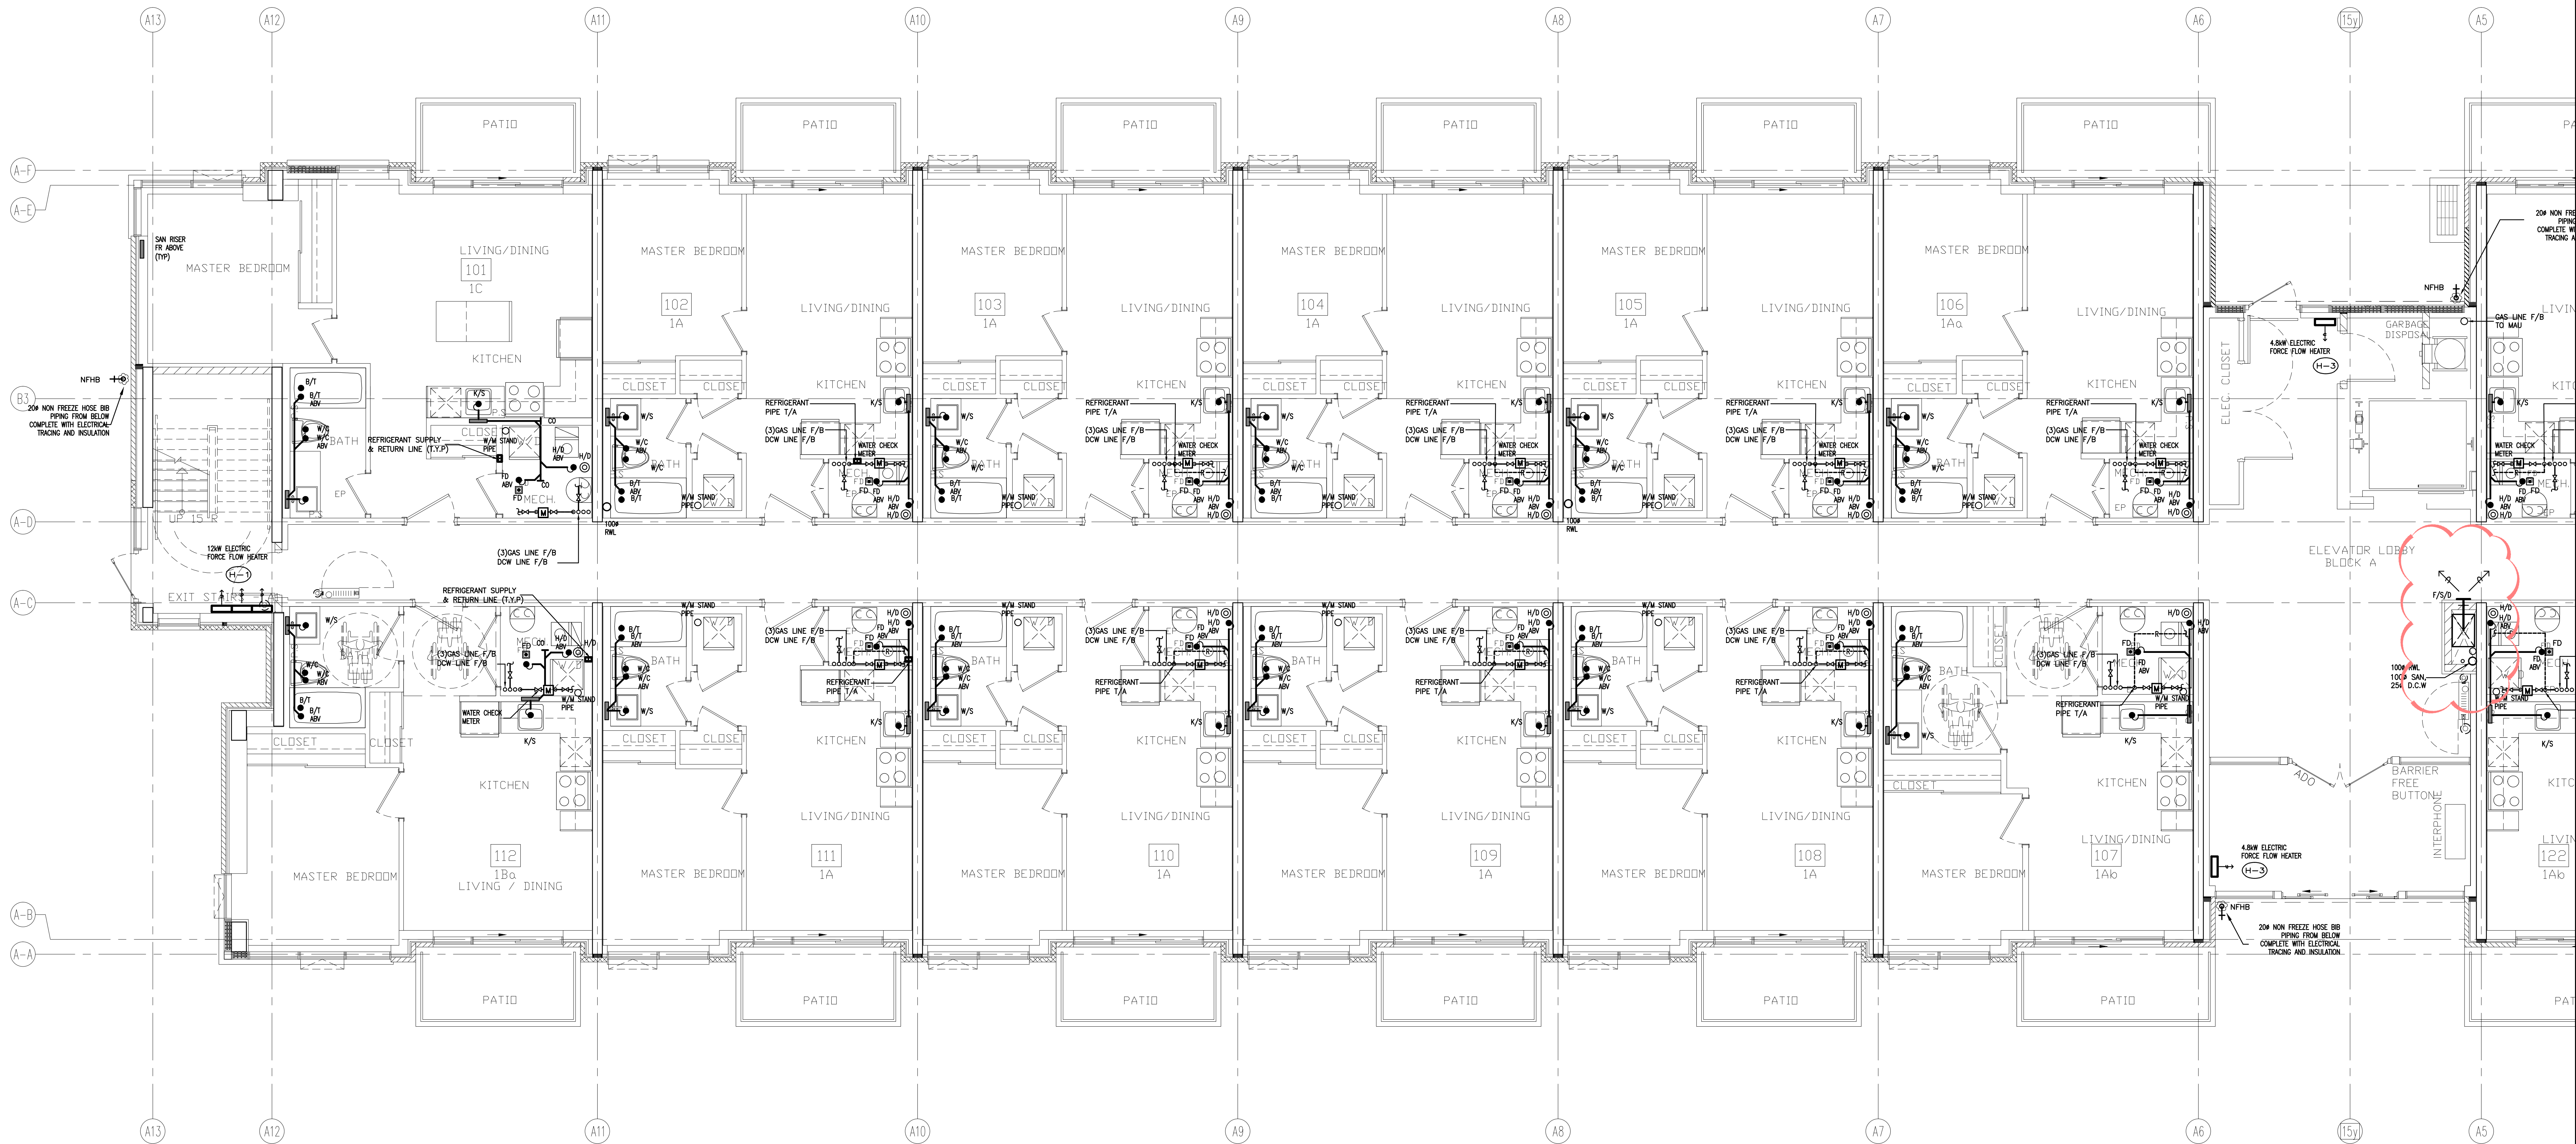

NO.	BY	DESCRIPTION	DATE
01	RC	ISSUED FOR TENDER	AUG. 02, 2019
02	RC	ADDENDUM #04	JUN. 12, 2020
03	LB	ISSUED FOR PERMIT	SEP. 28, 2020
04	LB	ISSUED AS PER ADDENDUM M-05	JAN. 20, 2021
05	LB	ISSUED FOR PERMIT BUILDING A.B.C.D	MAR. 03, 2021
06	LB	ISSUED FOR PROGRESSIVE CONSTRUCTION	MAR. 26, 2021
07	LB	ISSUED AS PER SITE INSTRUCTION M-02	JUN. 04, 2021


REVISIONS

This drawing is an instrument of service, is provided by and is the property of United Engineering Inc. The contractor must verify and accept responsibility for all dimensions and conditions on site and must notify United Engineering Inc. of any discrepancy before proceeding.

United Engineering Inc. is not responsible for the accuracy of Architectural, structural, interior design, etc., on this drawing.

Refer to the appropriate trade drawings before proceeding with any work. Installation must conform to all applicable codes and requirements of the authorities having jurisdiction.

This drawing is not to be scaled, all symbols are graphic representations only.

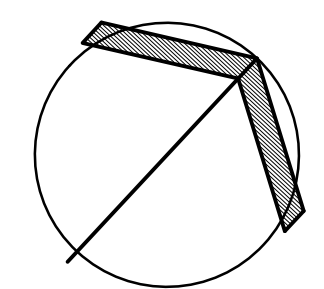

UNITED ENGINEERING INC.
Mechanical Electrical Consulting Engineers
3645 Keele Street, Suite 105,
Toronto, Ontario, M3J 1M6
Tel: (416) 398 1599, Fax: (416) 398 1933

TITLE
**BLOCK 'A'
GROUND FLOOR - PLUMBING/SANITARY**

PROJECT

**BRAMPTON STACKED
FORESTSIDE ESTATES**

**ATTMAR + PALLESCHI DRIVE
BRAMPTON, ONTARIO**

DRAWN	CHECKED	SCALE
MC	LM	1:50
DATE	PROJECT	DRAWING
MAY, 2019	18-017	M-35
		OF -



NO.	BY	DESCRIPTION	DATE
08	LB	ISSUED AS PER SITE INSTRUCTION M-02	JUN. 04, 2021
07	LB	ISSUED FOR PROGRESSIVE CONSTRUCTION	MAR. 26, 2021
06	LB	ISSUED AS PER ADDENDUM M-06	MAR. 25, 2021
05	LB	ISSUED FOR PERMIT BUILDING A,B,C,D	MAR. 03, 2021
04	LB	ISSUED AS PER ADDENDUM M-05	JAN. 20, 2021
03	LB	ISSUED FOR PERMIT	SEP. 28, 2020
02	RC	ADDENDUM #04	JUN. 12, 2020
01	RC	ISSUED FOR TENDER	AUG. 02, 2019


REVISIONS

This drawing, is an instrument of service, is provided by and is the property of United Engineering Inc. The contractor must verify and accept responsibility for all dimensions and conditions on site and must notify United Engineering Inc. of any discrepancy before proceeding.

United Engineering Inc. is not responsible for the accuracy of Architectural, structural, interior design, etc., on this drawing.

Refer to the appropriate trade drawings before proceeding with any work. Installation must conform to all applicable codes and requirements of the authorities having jurisdiction.

This drawing is not to be scaled, all symbols are graphic representations only.

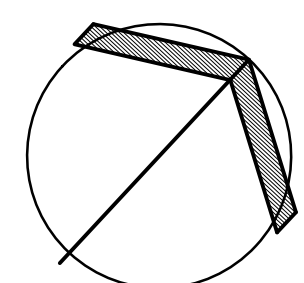

UNITED ENGINEERING INC.
Mechanical Electrical Consulting Engineers
3645 Keele Street, Suite 105,
Toronto, Ontario, M3J 1M6
Tel: (416) 398 1999, Fax: (416) 398 1933


TITLE
**BLOCK 'A'
GROUND FLOOR - PLUMBING/SANITARY**

PROJECT


**BRAMPTON STACKED
FORESTSIDE ESTATES**

**ATTMAR + PALLESCI DRIVE
BRAMPTON, ONTARIO**

DRAWN	CHECKED	SCALE
MC	LM	1:50
DATE	PROJECT	DRAWING
MAY, 2019	18-017	M-36
		OF

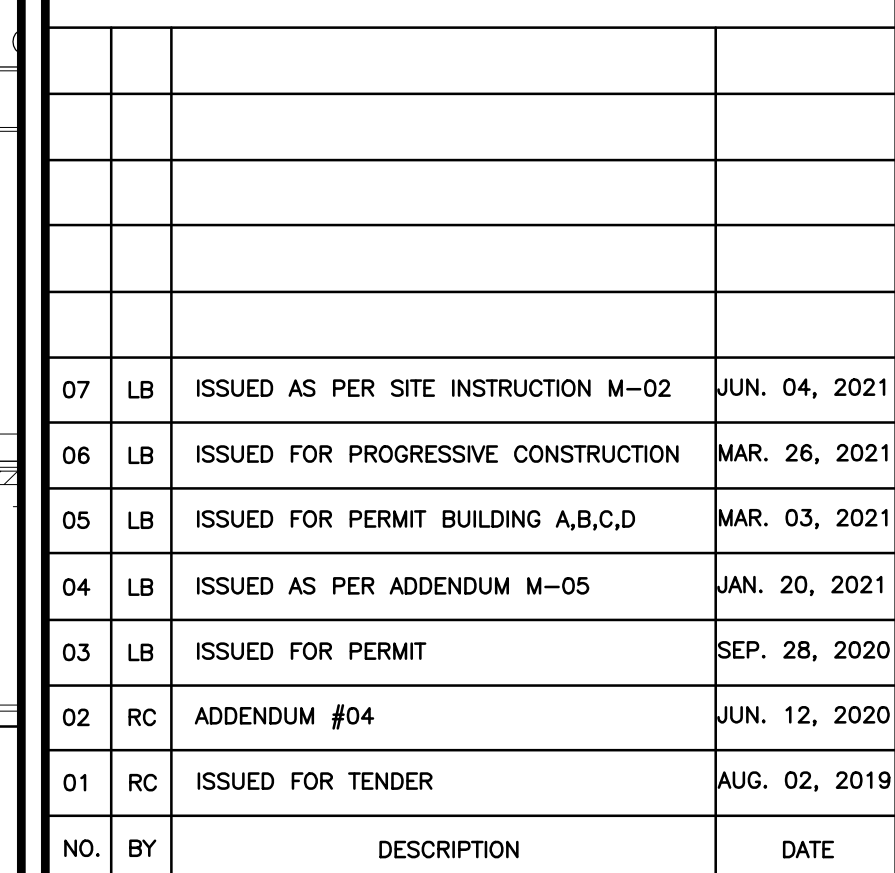

This drawing, is an instrument of service, is provided by and is the property of United Engineering Inc. The contractor must verify and accept responsibility for all dimensions and conditions on site and must notify United Engineering Inc. of any discrepancy before proceeding. United Engineering Inc. is not responsible for the accuracy of Architectural, structural, interior design, etc. on this drawing. The contractor is responsible to the appropriate trade drawings before proceeding with any work. Installation must conform to all applicable codes and requirements of all authorities having jurisdiction. This drawing is not to be scaled, all symbols are graphic representations only.

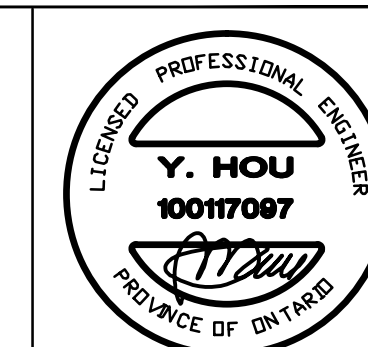

DRAWN MC	CHECKED LM	SCALE 1:50
DATE MAY, 2019	PROJECT 18-017	DRAWING M-37
		OF -

DRAWN MC	CHECKED LM	SCALE 1:50
DATE MAY, 2019	PROJECT 18-017	DRAWING M-37
		OF -



NO.	BY	DESCRIPTION	DATE
08	LB	ISSUED AS PER SITE INSTRUCTION M-02	JUN. 04, 2021
07	LB	ISSUED FOR PROGRESSIVE CONSTRUCTION	MAR. 26, 2021
06	LB	ISSUED AS PER ADDENDUM M-06	MAR. 25, 2021
05	LB	ISSUED FOR PERMIT BUILDING A,B,C,D	MAR. 03, 2021
04	LB	ISSUED AS PER ADDENDUM M-05	JAN. 20, 2021
03	LB	ISSUED FOR PERMIT	SEP. 28, 2020
02	RC	ADDENDUM #04	JUN. 12, 2020
01	RC	ISSUED FOR TENDER	AUG. 02, 2019


REVISIONS

This drawing is an instrument of service, is provided by and is the property of United Engineering Inc. The contractor must verify and accept responsibility for all dimensions and conditions on site and must notify United Engineering Inc. of any discrepancy before proceeding.

United Engineering Inc. is not responsible for the accuracy of Architectural, structural, interior design, etc. on this drawing.

Refer to the appropriate trade drawings before proceeding with any work. Installation must conform to all applicable codes and requirements of the authorities having jurisdiction.

This drawing is not to be scaled, all symbols are graphic representations only.

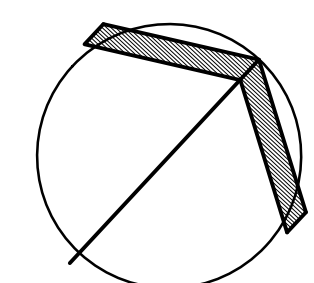

UNITED ENGINEERING INC.
Mechanical Electrical Consulting Engineers
3645 Keele Street, Suite 105,
Toronto, Ontario, M3J 1M6
Tel: (416) 398 1999, Fax: (416) 398 1933

TITLE
**BLOCK 'A'
2ND FLOOR - PLUMBING/SANITARY**

PROJECT

**BRAMPTON STACKED
FORESTSIDE ESTATES**

**ATTMAR + PALLESCI DRIVE
BRAMPTON, ONTARIO**

DRAWN	CHECKED	SCALE
MC	LM	1:50
DATE	PROJECT	DRAWING
MAY, 2019	18-017	M-38
		OF



NO.	BY	DESCRIPTION	DATE
07	LB	ISSUED AS PER SITE INSTRUCTION M-02	JUN. 04, 2021
06	LB	ISSUED FOR PROGRESSIVE CONSTRUCTION	MAR. 26, 2021
05	LB	ISSUED FOR PERMIT BUILDING A,B,C,D	MAR. 03, 2021
04	LB	ISSUED AS PER ADDENDUM M-05	JAN. 20, 2021
03	LB	ISSUED FOR PERMIT	SEP. 28, 2020
02	RC	ADDENDUM #04	JUN. 12, 2020
01	RC	ISSUED FOR TENDER	AUG. 02, 2019


REVISIONS

This drawing is an instrument of service, is provided by and is the property of United Engineering Inc. The contractor must verify and accept responsibility for all dimensions and conditions on site and must notify United Engineering Inc. of any discrepancy before proceeding.

United Engineering Inc. is not responsible for the accuracy of Architectural, structural, interior design, etc., on this drawing.

Refer to the appropriate trade drawings before proceeding with any work. Installation must conform to all applicable codes and requirements of the authorities having jurisdiction.

This drawing is not to be scaled, all symbols are graphic representations only.

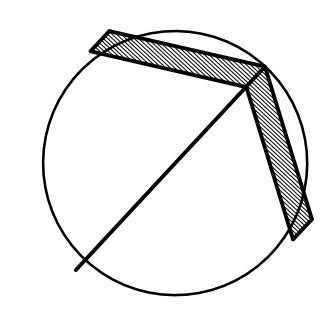

UNITED ENGINEERING INC.
Mechanical Electrical Consulting Engineers
3645 Keele Street, Suite 105,
Toronto, Ontario, M3J 1M6
Tel: (416) 398 1999, Fax: (416) 398 1933


TITLE
BLOCK 'A'
3RD FLOOR - PLUMBING/SANITARY

PROJECT

**BRAMPTON STACKED
FORESTSIDE ESTATES**

**ATTMAR + PALLESCI DRIVE
BRAMPTON, ONTARIO**

DRAWN	CHECKED	SCALE
MC	LM	1:50
DATE	PROJECT	DRAWING
MAY, 2019	18-017	M-39
		OF

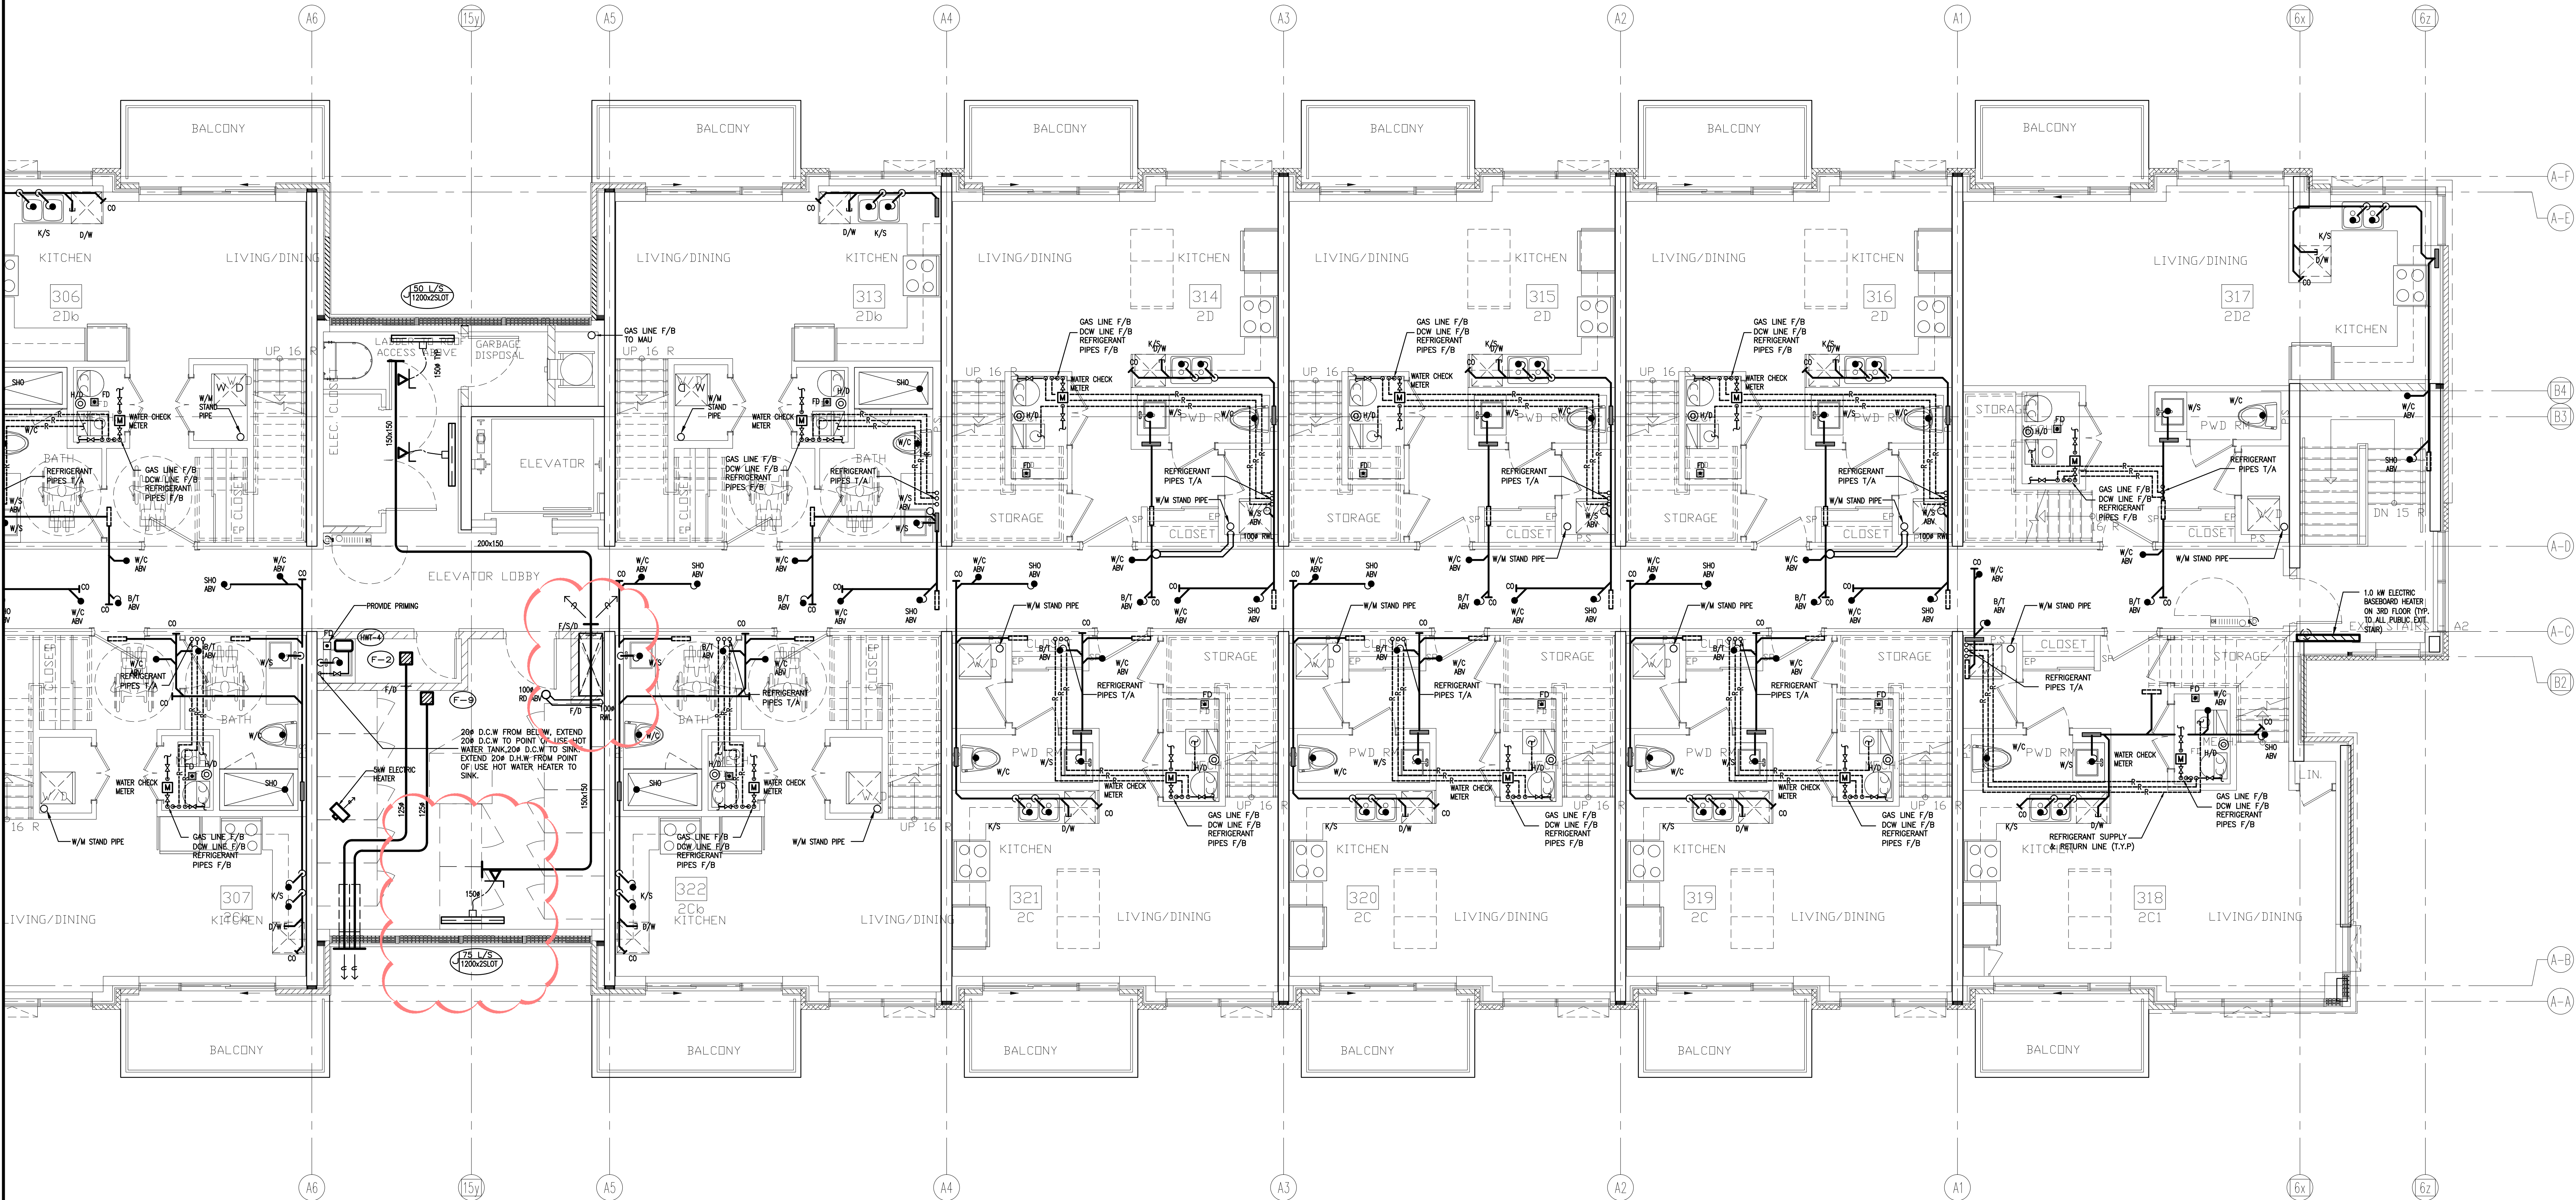

NO.	BY	DESCRIPTION	DATE
08	LB	ISSUED AS PER SITE INSTRUCTION M-02	JUN. 04, 2021
07	LB	ISSUED FOR PROGRESSIVE CONSTRUCTION	MAR. 26, 2021
06	LB	ISSUED AS PER ADDENDUM M-06	MAR. 25, 2021
05	LB	ISSUED FOR PERMIT BUILDING A,B,C,D	MAR. 03, 2021
04	LB	ISSUED AS PER ADDENDUM M-05	JAN. 20, 2021
03	LB	ISSUED FOR PERMIT	SEP. 28, 2020
02	RC	ADDENDUM #04	JUN. 12, 2020
01	RC	ISSUED FOR TENDER	AUG. 02, 2019


REVISIONS

This drawing is an instrument of service, is provided by and is the property of United Engineering Inc. The contractor must verify and accept responsibility for all dimensions and conditions on site and must notify United Engineering Inc. of any discrepancy before proceeding.

United Engineering Inc. is not responsible for the accuracy of Architectural, structural, interior design, etc., on this drawing.

Refer to the appropriate trade drawings before proceeding with any work. Installation must conform to all applicable codes and requirements of the authorities having jurisdiction.

This drawing is not to be scaled, all symbols are graphic representations only.

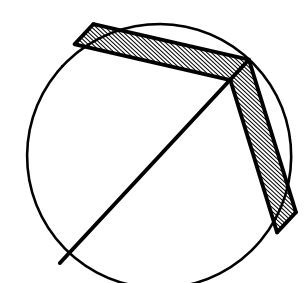

UNITED ENGINEERING INC.
Mechanical Electrical Consulting Engineers
3645 Keele Street, Suite 105,
Toronto, Ontario, M3J 1M6
Tel: (416) 398 1599, Fax: (416) 398 1933



TITLE
**BLOCK 'A'
3RD FLOOR - PLUMBING/SANITARY**

PROJECT

**BRAMPTON STACKED
FORESTSIDE ESTATES**

**ATTMAR + PALLESCHI DRIVE
BRAMPTON, ONTARIO**

DRAWN	CHECKED	SCALE
MC	LM	1:50
DATE	PROJECT	DRAWING
MAY, 2019	18-017	M-40
		OF

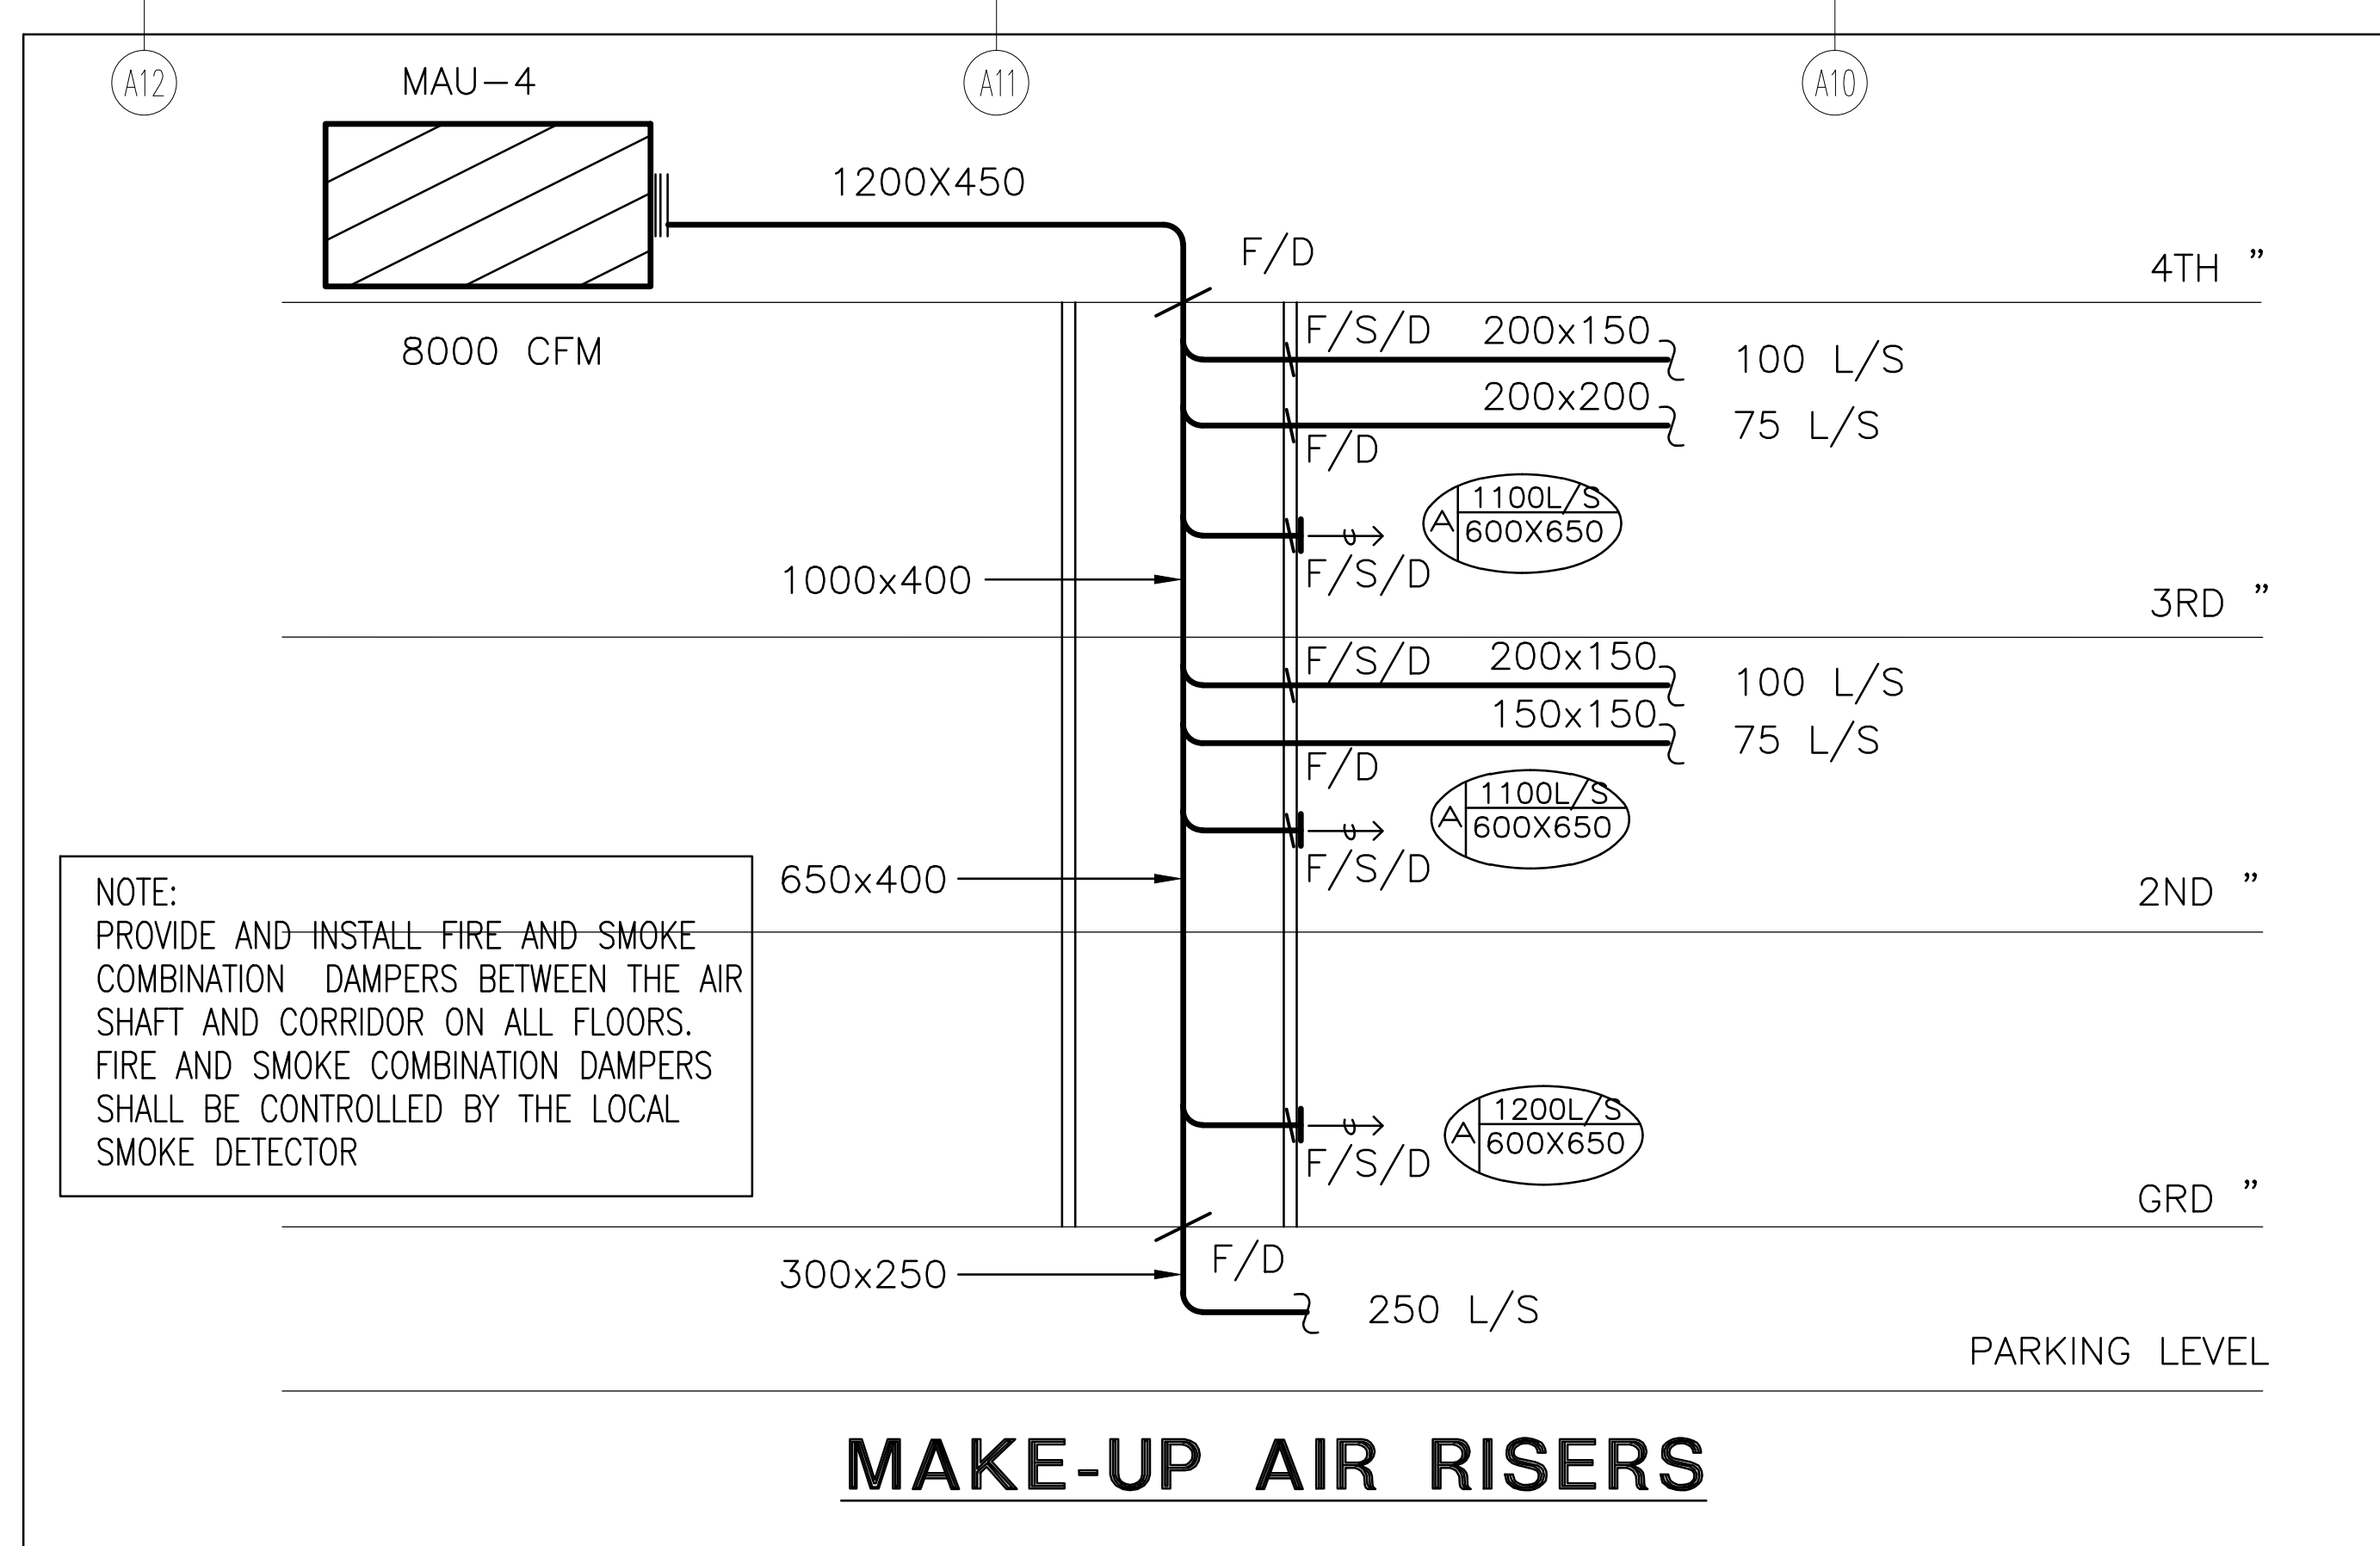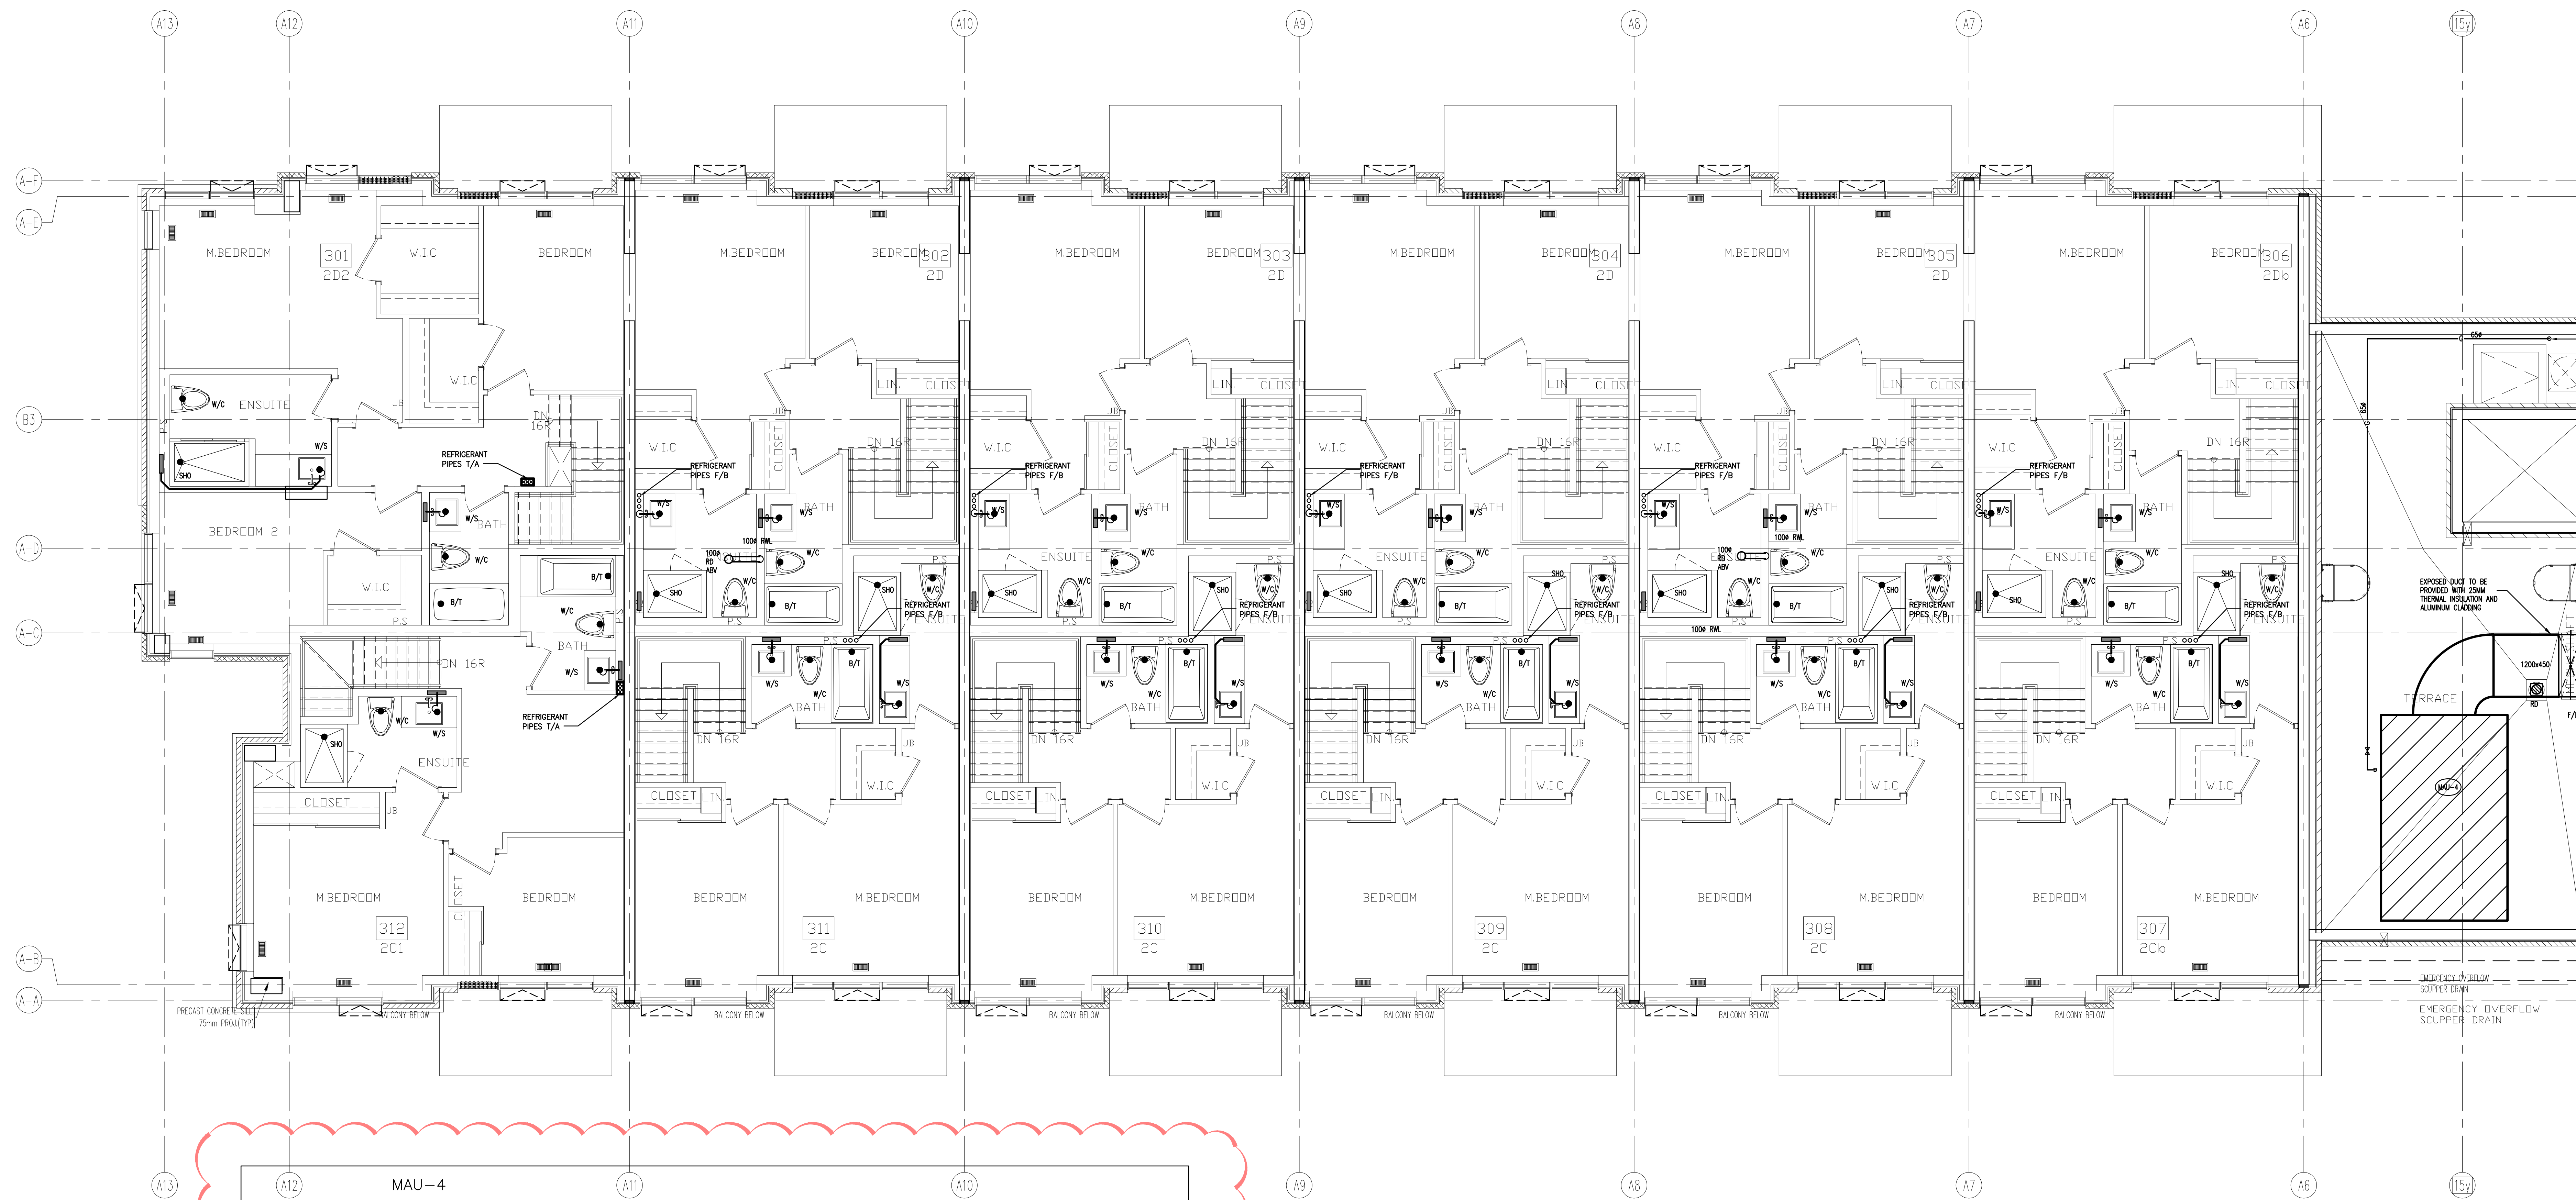

NO.	BY	DESCRIPTION	DATE
09	LB	ISSUED AS PER SITE INSTRUCTION M-02	JUN. 04, 2021
08	LB	ISSUED AS PER SITE INSTRUCTION M-01	APR. 28, 2021
07	LB	ISSUED FOR PROGRESSIVE CONSTRUCTION	MAR. 26, 2021
06	LB	ISSUED AS PER ADDENDUM M-06	MAR. 25, 2021
05	LB	ISSUED FOR PERMIT BUILDING A,B,C,D	MAR. 03, 2021
04	LB	ISSUED AS PER ADDENDUM M-05	JAN. 20, 2021
03	LB	ISSUED FOR PERMIT	SEP. 28, 2020
02	RC	ADDENDUM #04	JUN. 12, 2020
01	RC	ISSUED FOR TENDER	AUG. 02, 2019


REVISIONS

This drawing is an instrument of service, is provided by and is the property of United Engineering Inc. The contractor must verify and accept responsibility for all dimensions and conditions on site and must notify United Engineering Inc. of any discrepancy before proceeding.

United Engineering Inc. is not responsible for the accuracy of Architectural, structural, interior design, etc., on this drawing.

Refer to the appropriate trade drawings before proceeding with any work. Installation must conform to all applicable codes and requirements of the authorities having jurisdiction.

This drawing is not to be scaled, all symbols are graphic representations only.

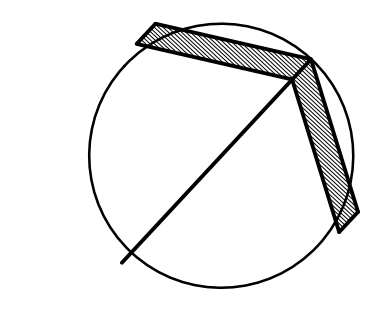

UNITED ENGINEERING INC.
Mechanical Electrical Consulting Engineers
3645 Keele Street, Suite 105,
Toronto, Ontario, M3J 1M6
Tel: (416) 398 1999, Fax: (416) 398 1933


TITLE
**BLOCK 'A'
4TH FLOOR - PLUMBING/SANITARY**

PROJECT


**BRAMPTON STACKED
FORESTSIDE ESTATES**

**ATTMAR + PALLESCI DRIVE
BRAMPTON, ONTARIO**


DRAWN	CHECKED	SCALE
MC	LM	1:50
DATE	PROJECT	DRAWING
MAY, 2019	18-017	M-41
		OF

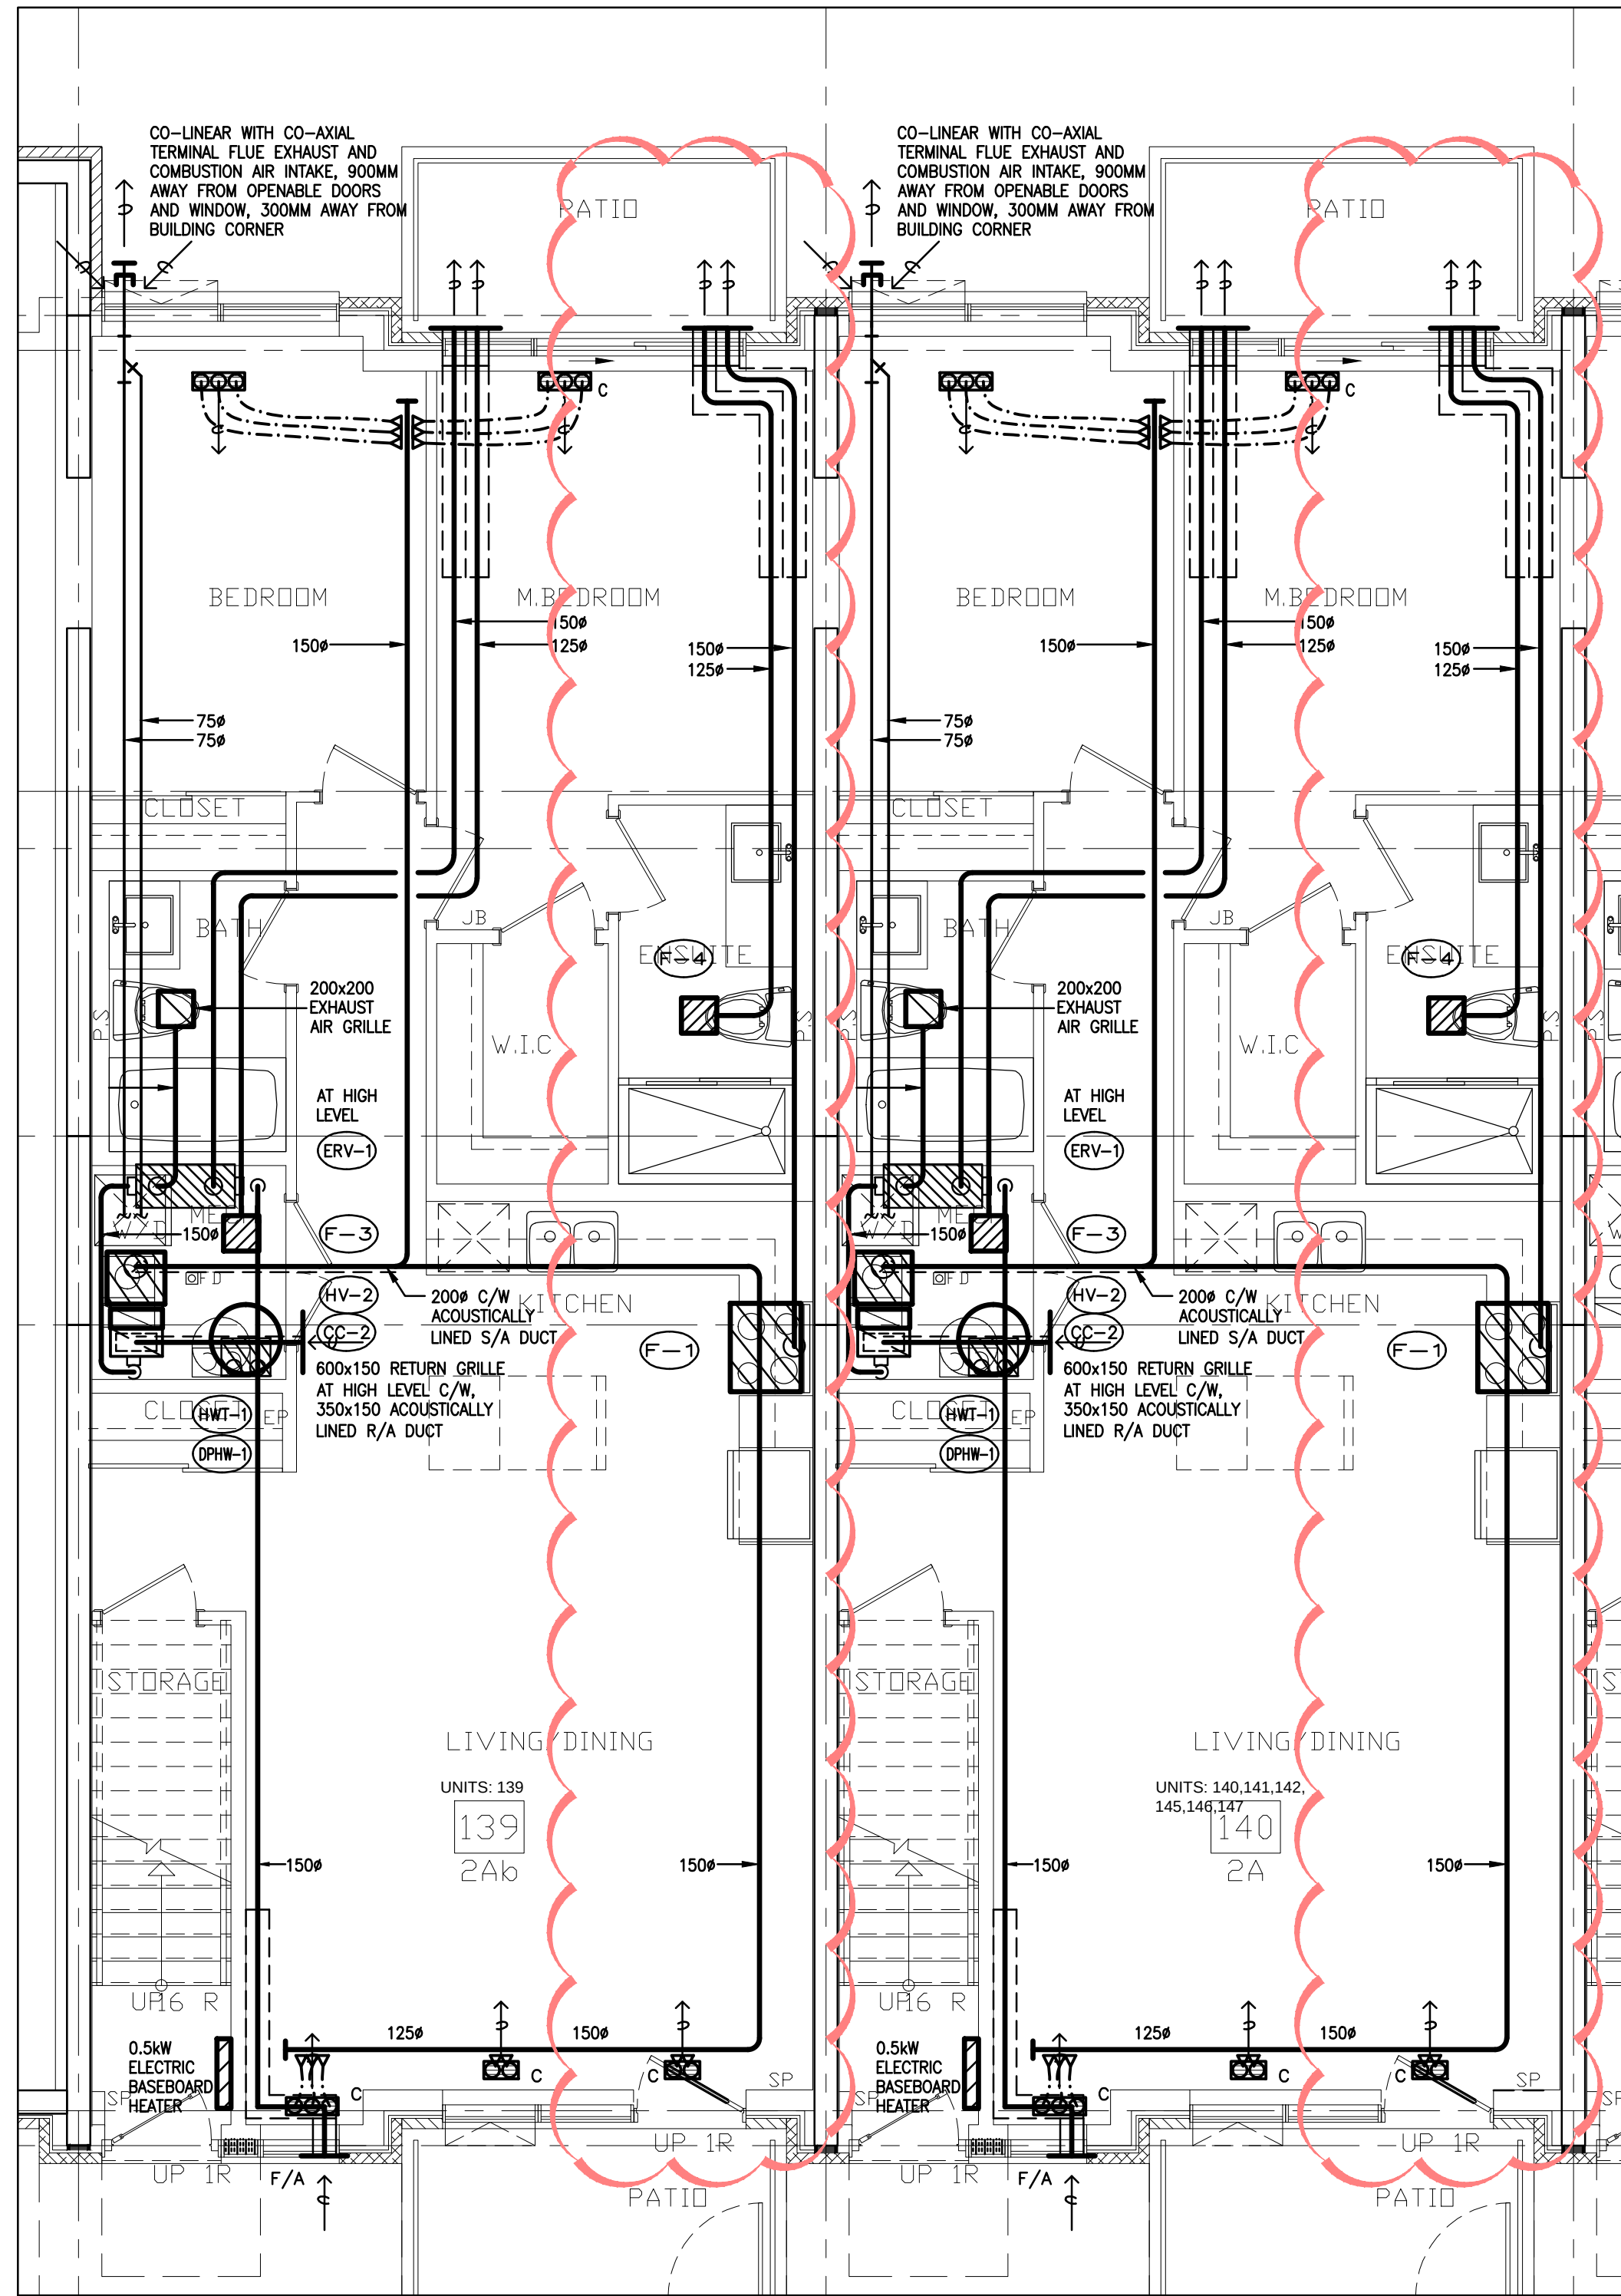


GROUND FLOOR TYPICAL SUITE LAYOUT TYPE 2Ab & 2A

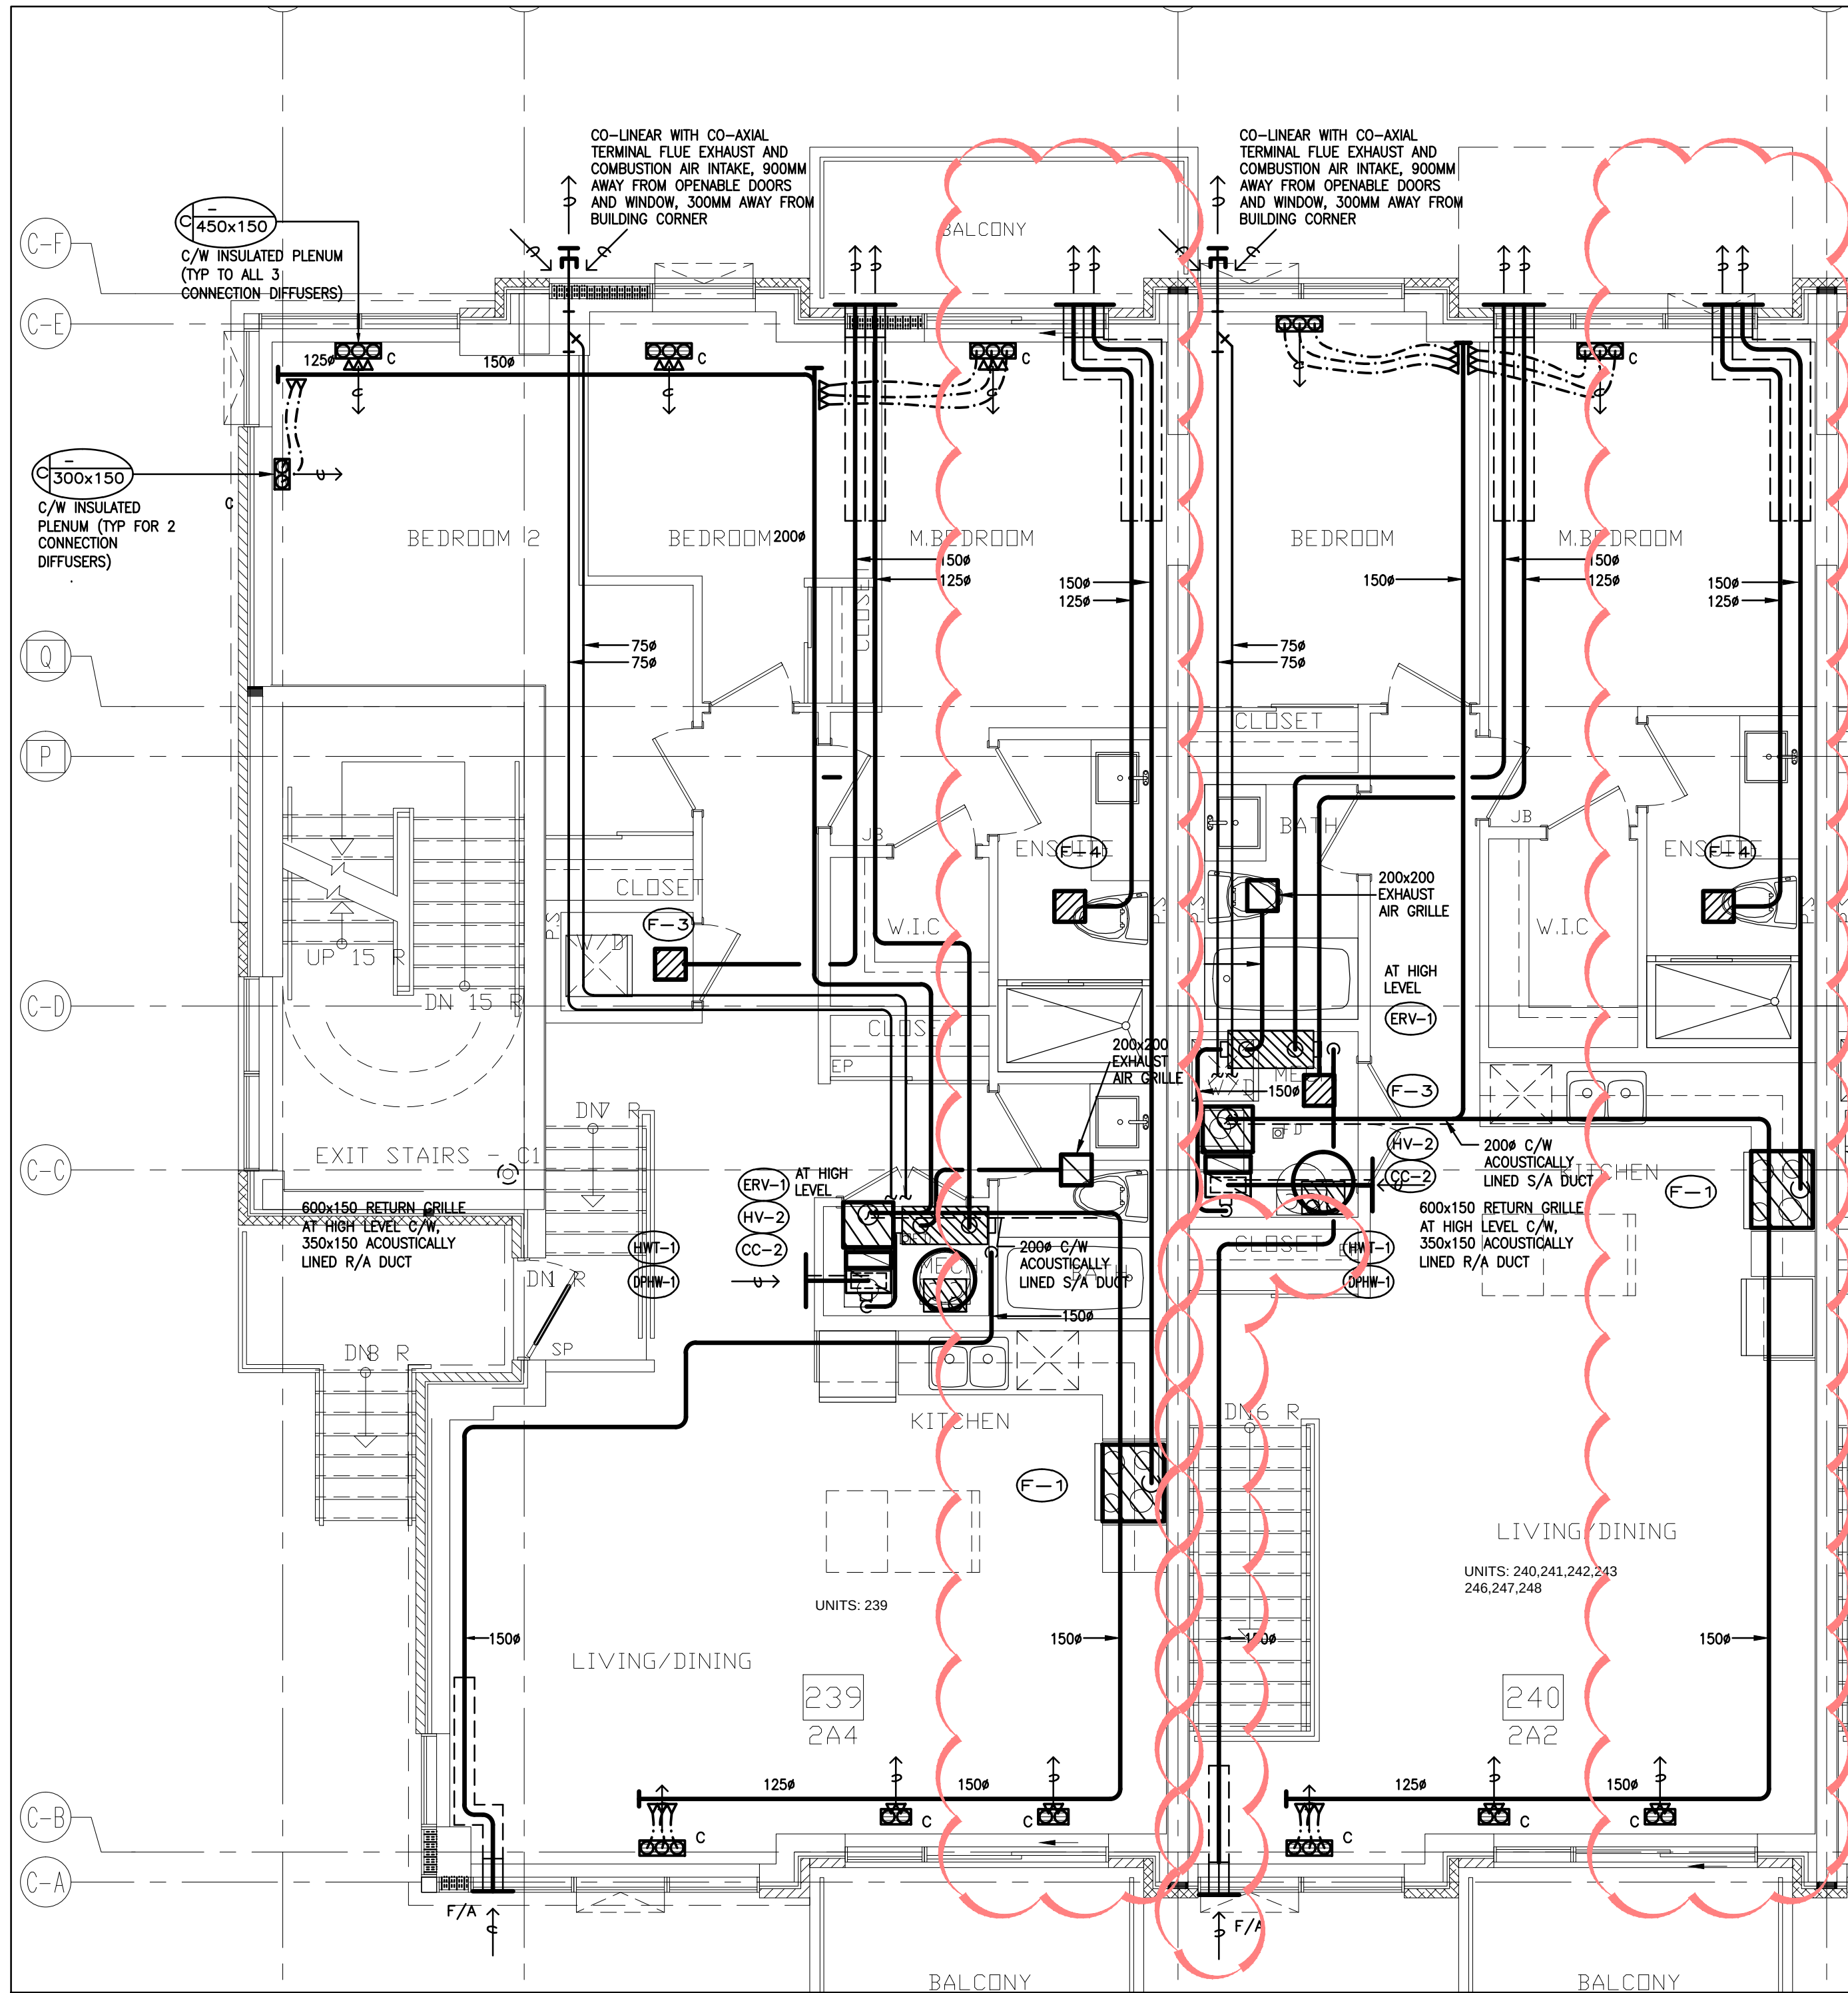

GROUND FLOOR TYPICAL SUITE LAYOUT TYPE 2A4 & 2A2

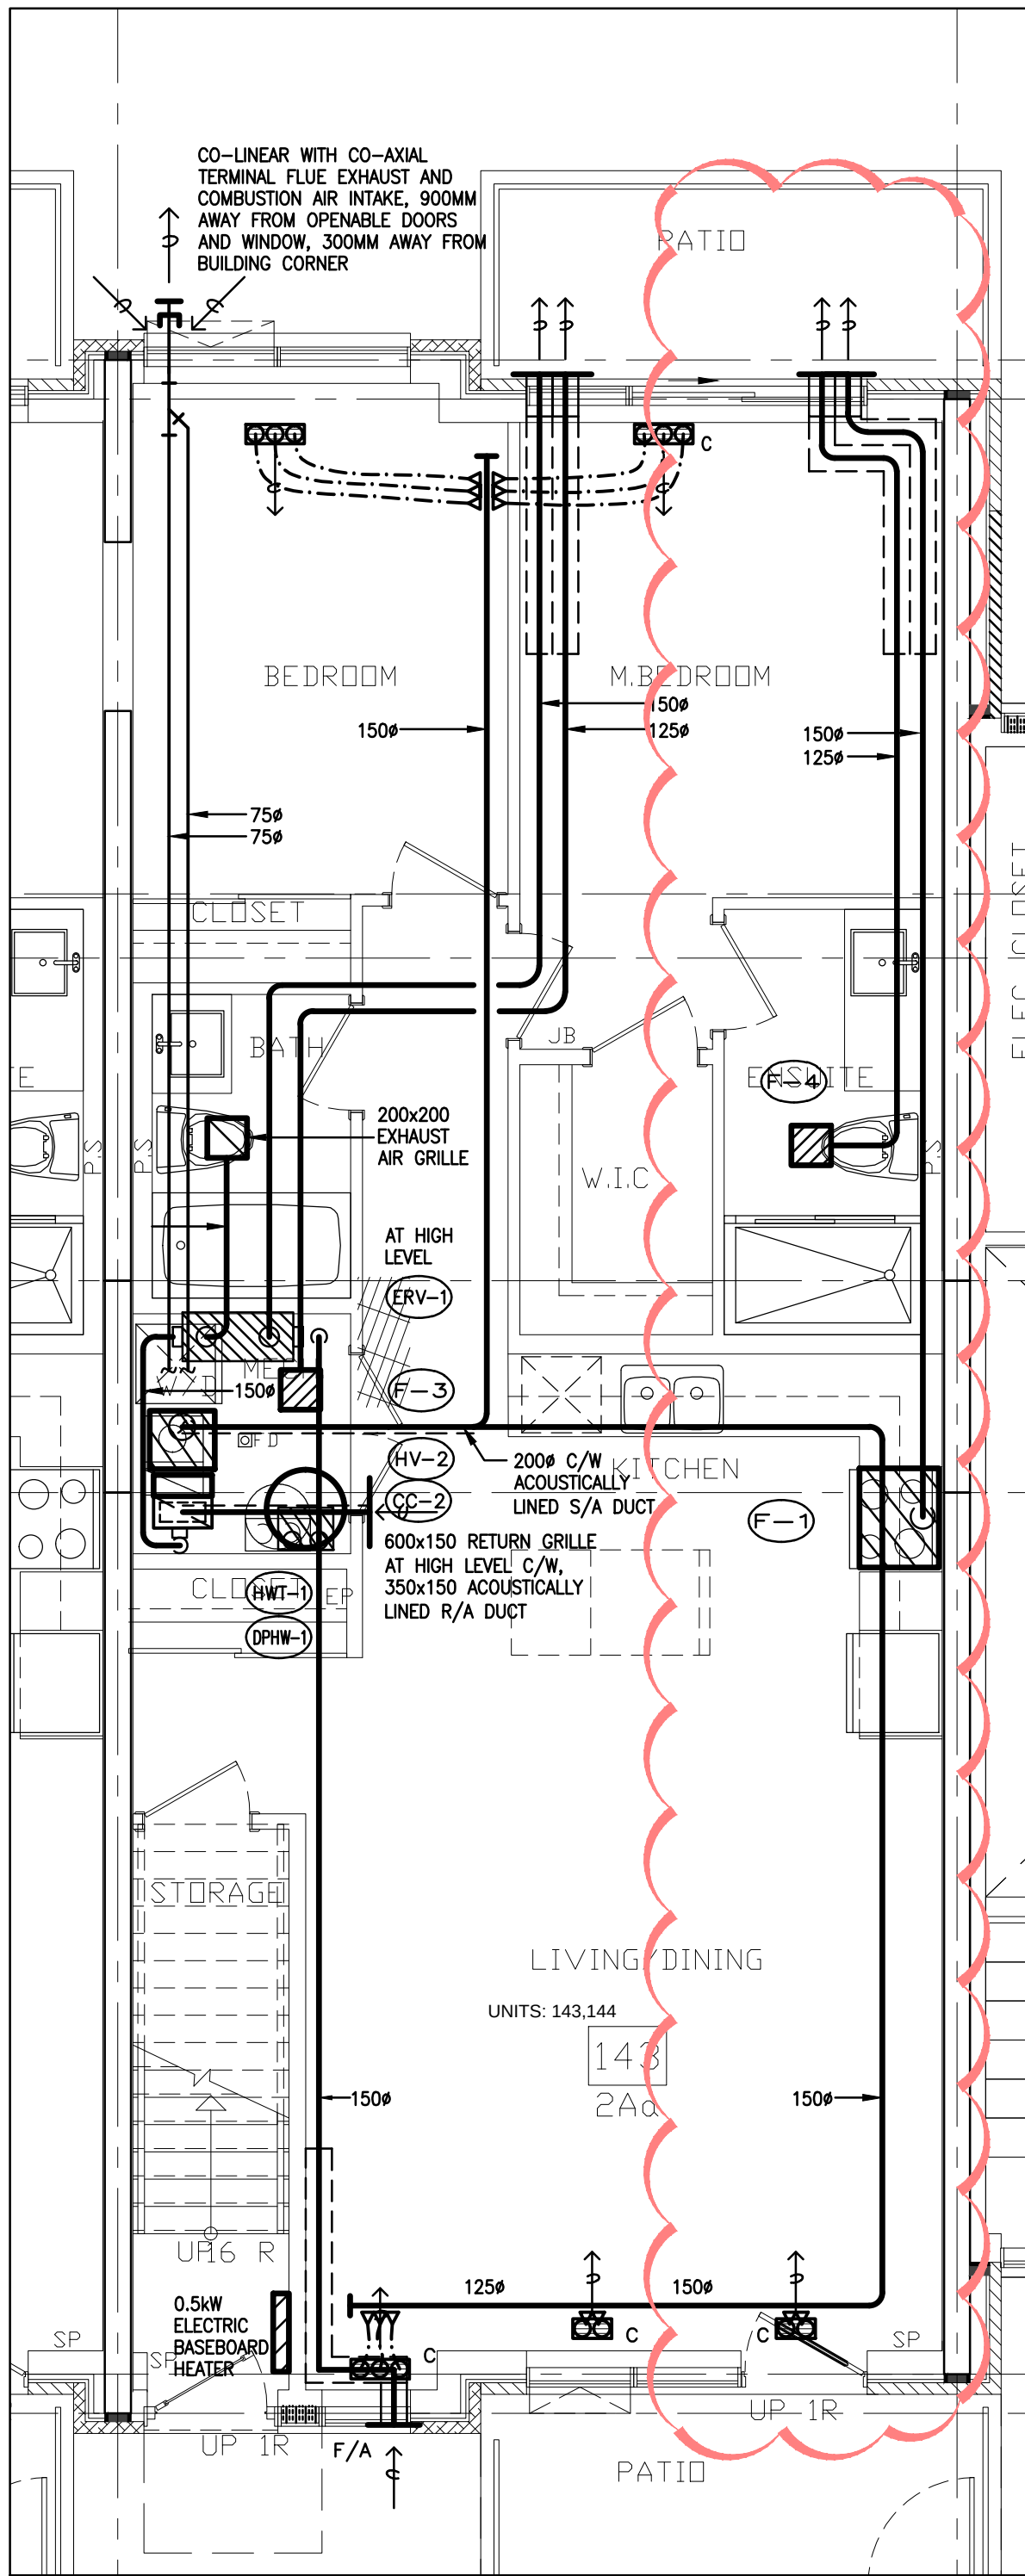

GROUND FLOOR TYPICAL SUITE LAYOUT TYPE 2Aa

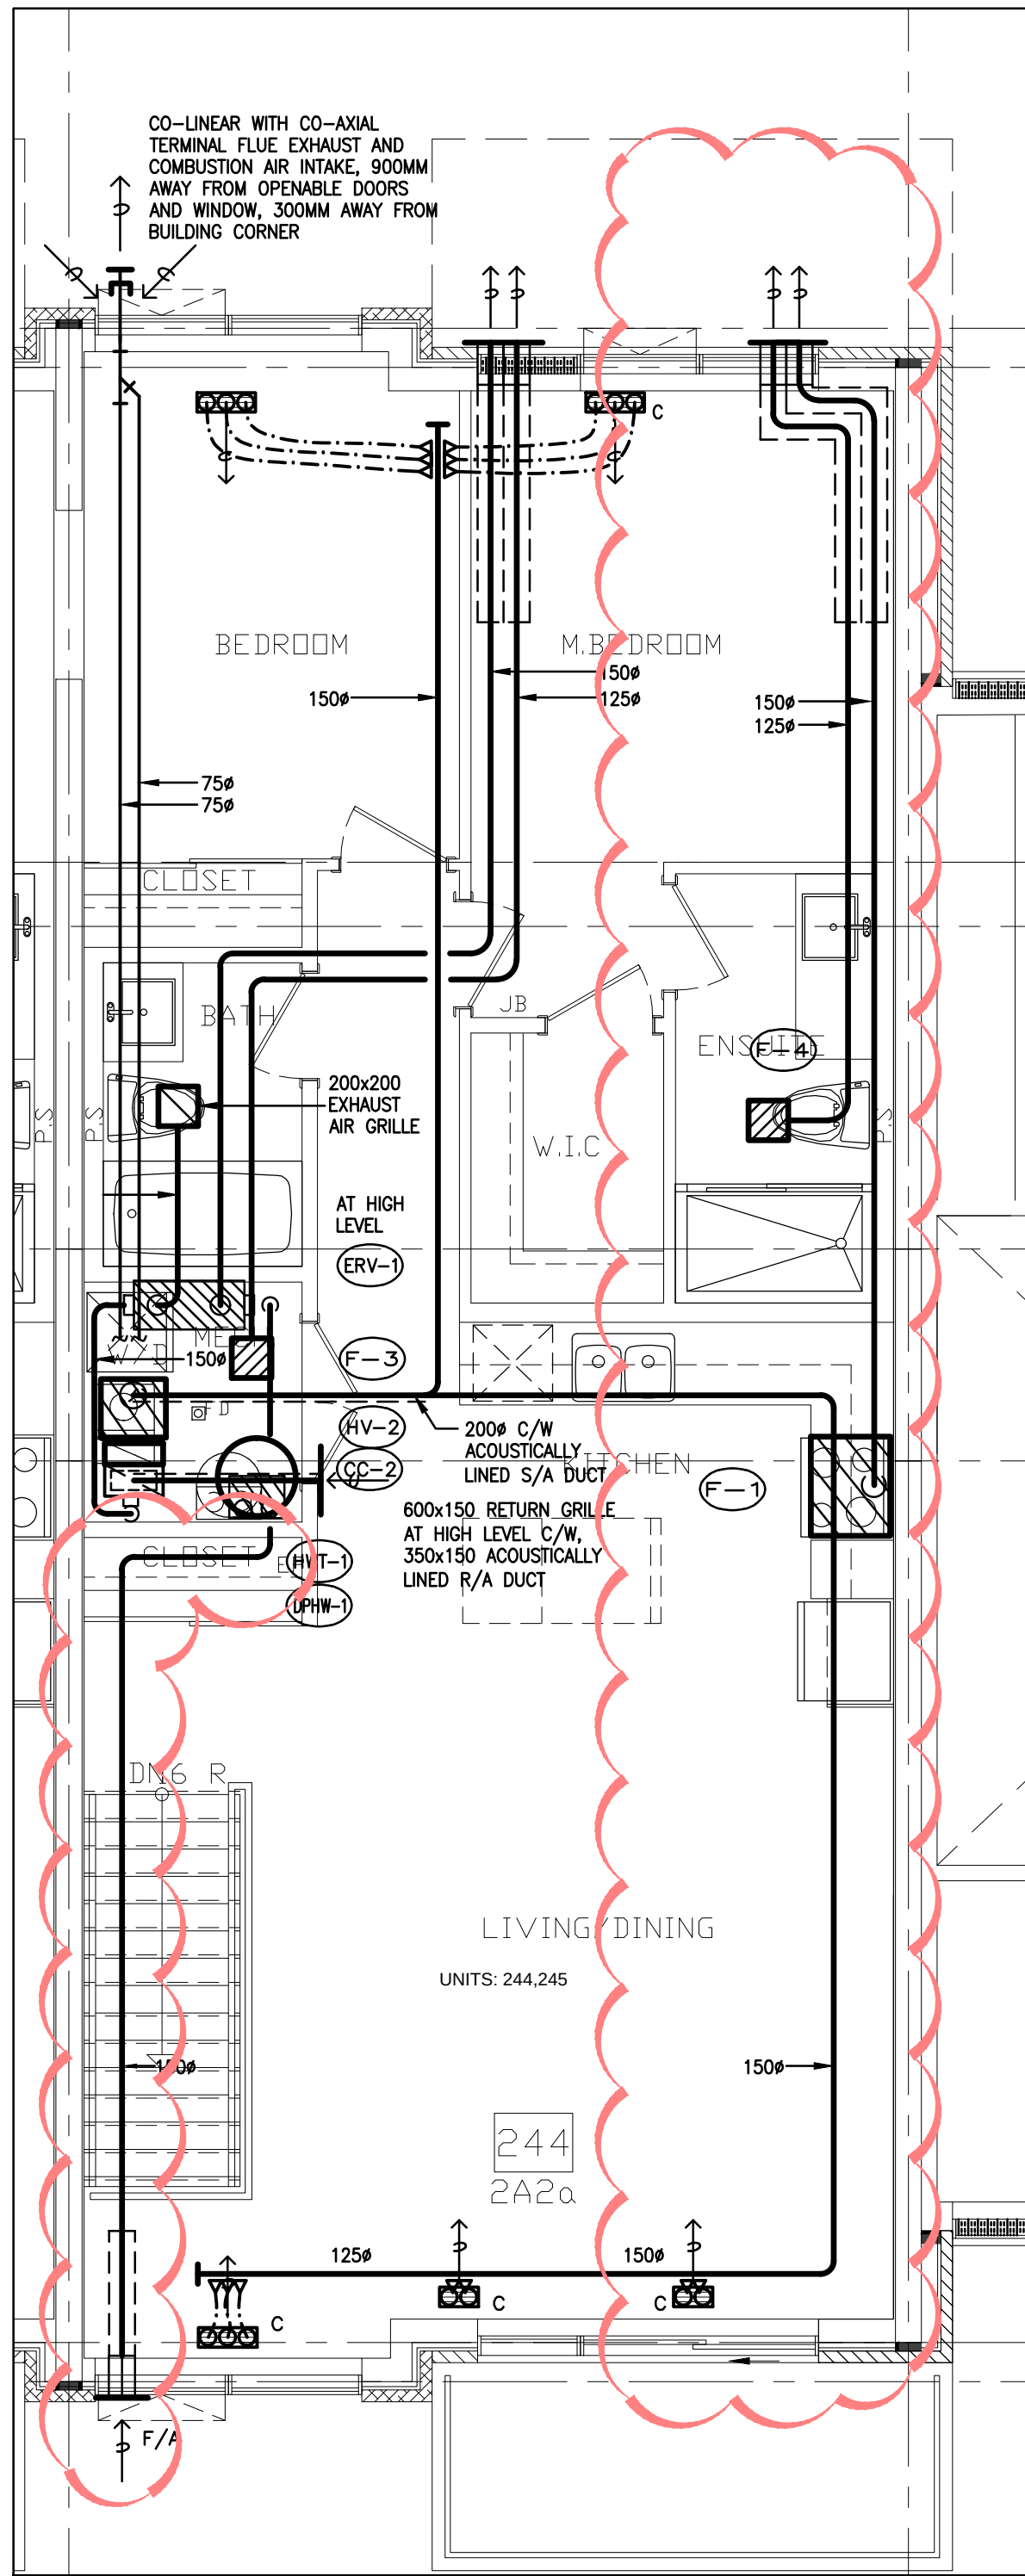


GROUND FLOOR TYPICAL SUITE LAYOUT TYPE 2A2a

07	LB	ISSUED AS PER SITE INSTRUCTION M-02	JUN. 04, 2021
06	LB	ISSUED FOR PROGRESSIVE CONSTRUCTION	MAR. 28, 2021
05	LB	ISSUED FOR PERMIT BUILDING A,B,C,D	MAR. 03, 2021
04	LB	ISSUED AS PER ADD M-05	JAN. 20, 2021
03	LB	ISSUED FOR PERMIT	SEP. 28, 2020
02	RC	ADDENDUM #04	JUN. 12, 2020
01	RC	ISSUED FOR TENDER	AUG. 02, 2019

REVISIONS

This drawing is an instrument of service, is provided by and is the property of United Engineering Inc. The contractor must verify and accept responsibility for all dimensions and conditions on site and must notify United Engineering Inc. of any discrepancy before proceeding. United Engineering Inc. is not responsible for the accuracy of Architectural, structural, interior design, etc. on this drawing. Refer to the appropriate trade drawings before proceeding with any work. Installation must conform to all applicable codes and requirements of the authorities having jurisdiction. This drawing is not to be scaled, all symbols are graphic representations only.

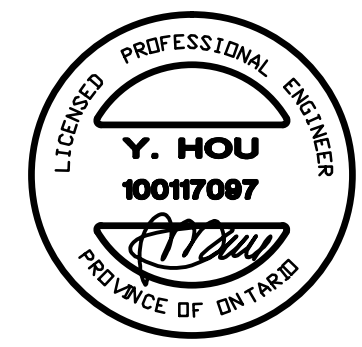


UNITED ENGINEERING INC.
Mechanical Electrical Consulting Engineers
3645 Keele Street, Suite 105,
Toronto, Ontario, M3J 1M6
Tel: (416) 398 1599, Fax: (416) 398 1933

TITLE
**TYPICAL SUITES LAYOUT
MECHANICAL**


PROJECT
**BRAMPTON STACKED
FORESTSIDE ESTATES**

ATTMAR + PALLESCI DRIVE
BRAMPTON, ONTARIO


DRAWN MC	CHECKED LM	SCALE 1:50
DATE MAY, 2019	PROJECT 18-017	DRAWING M-45 OF -

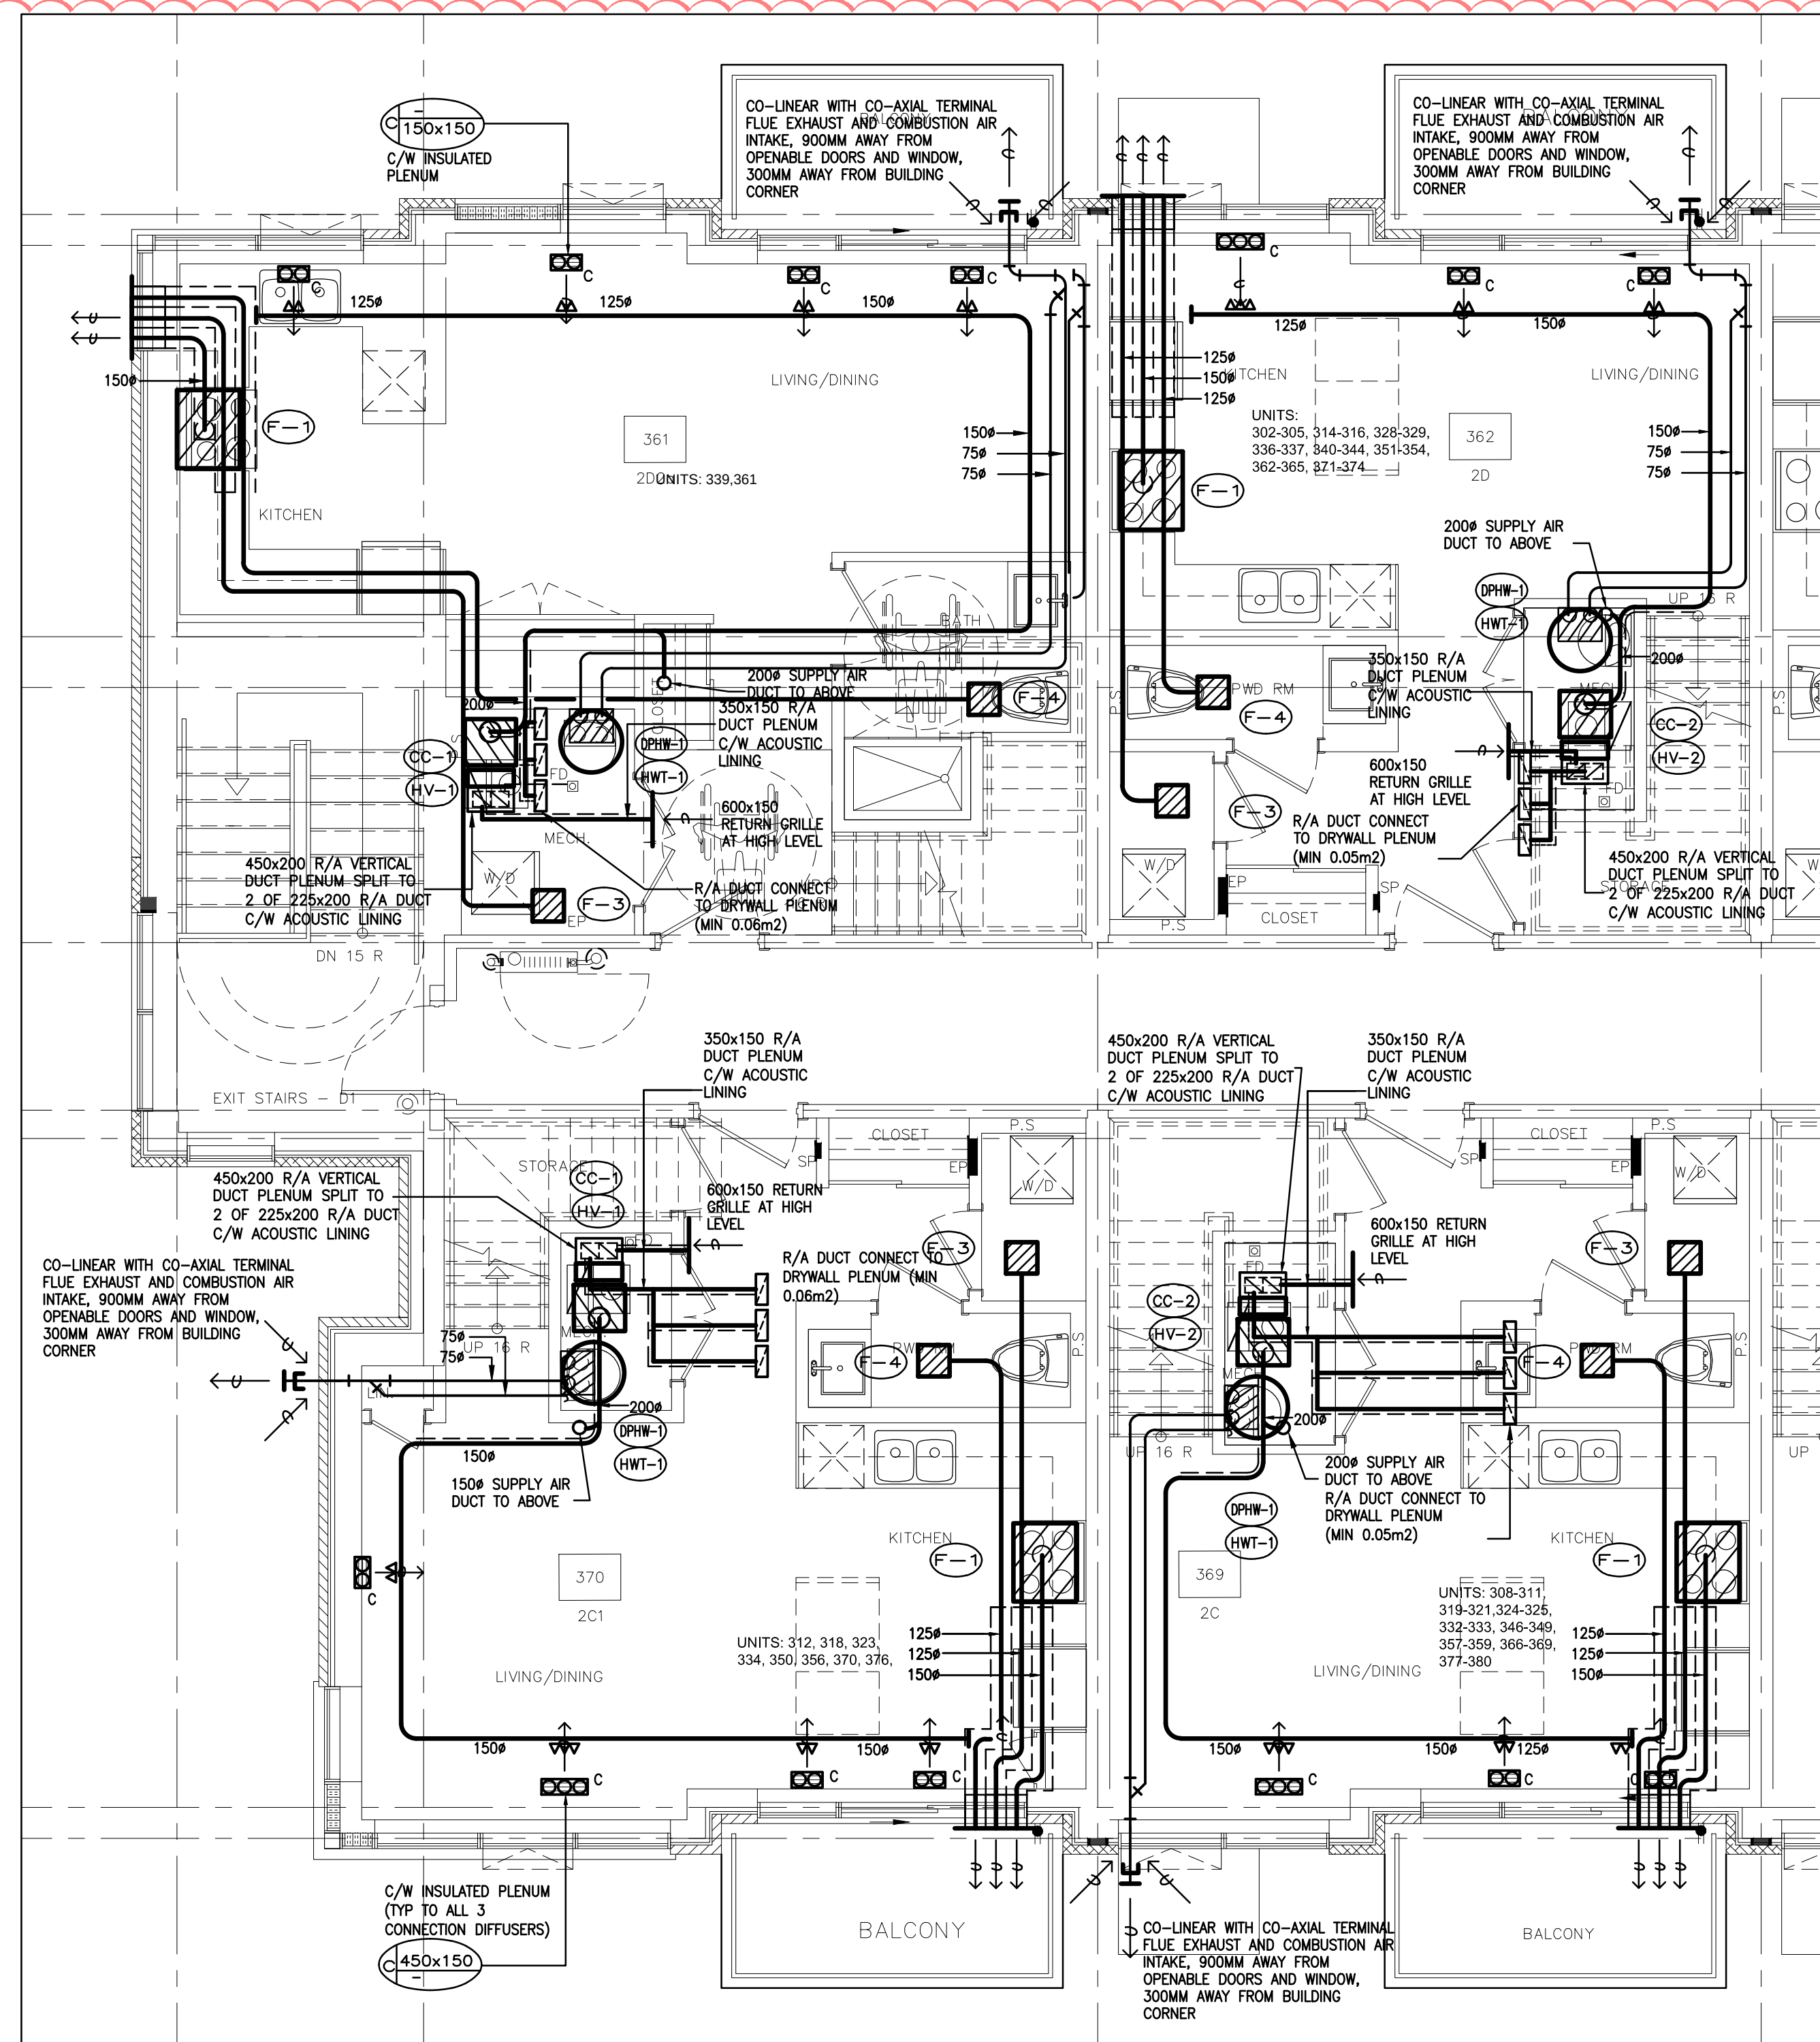


3RD FLOOR TYPICAL SUITE LAYOUT
TYPE 2C1, 2C, 2D2a & 2D

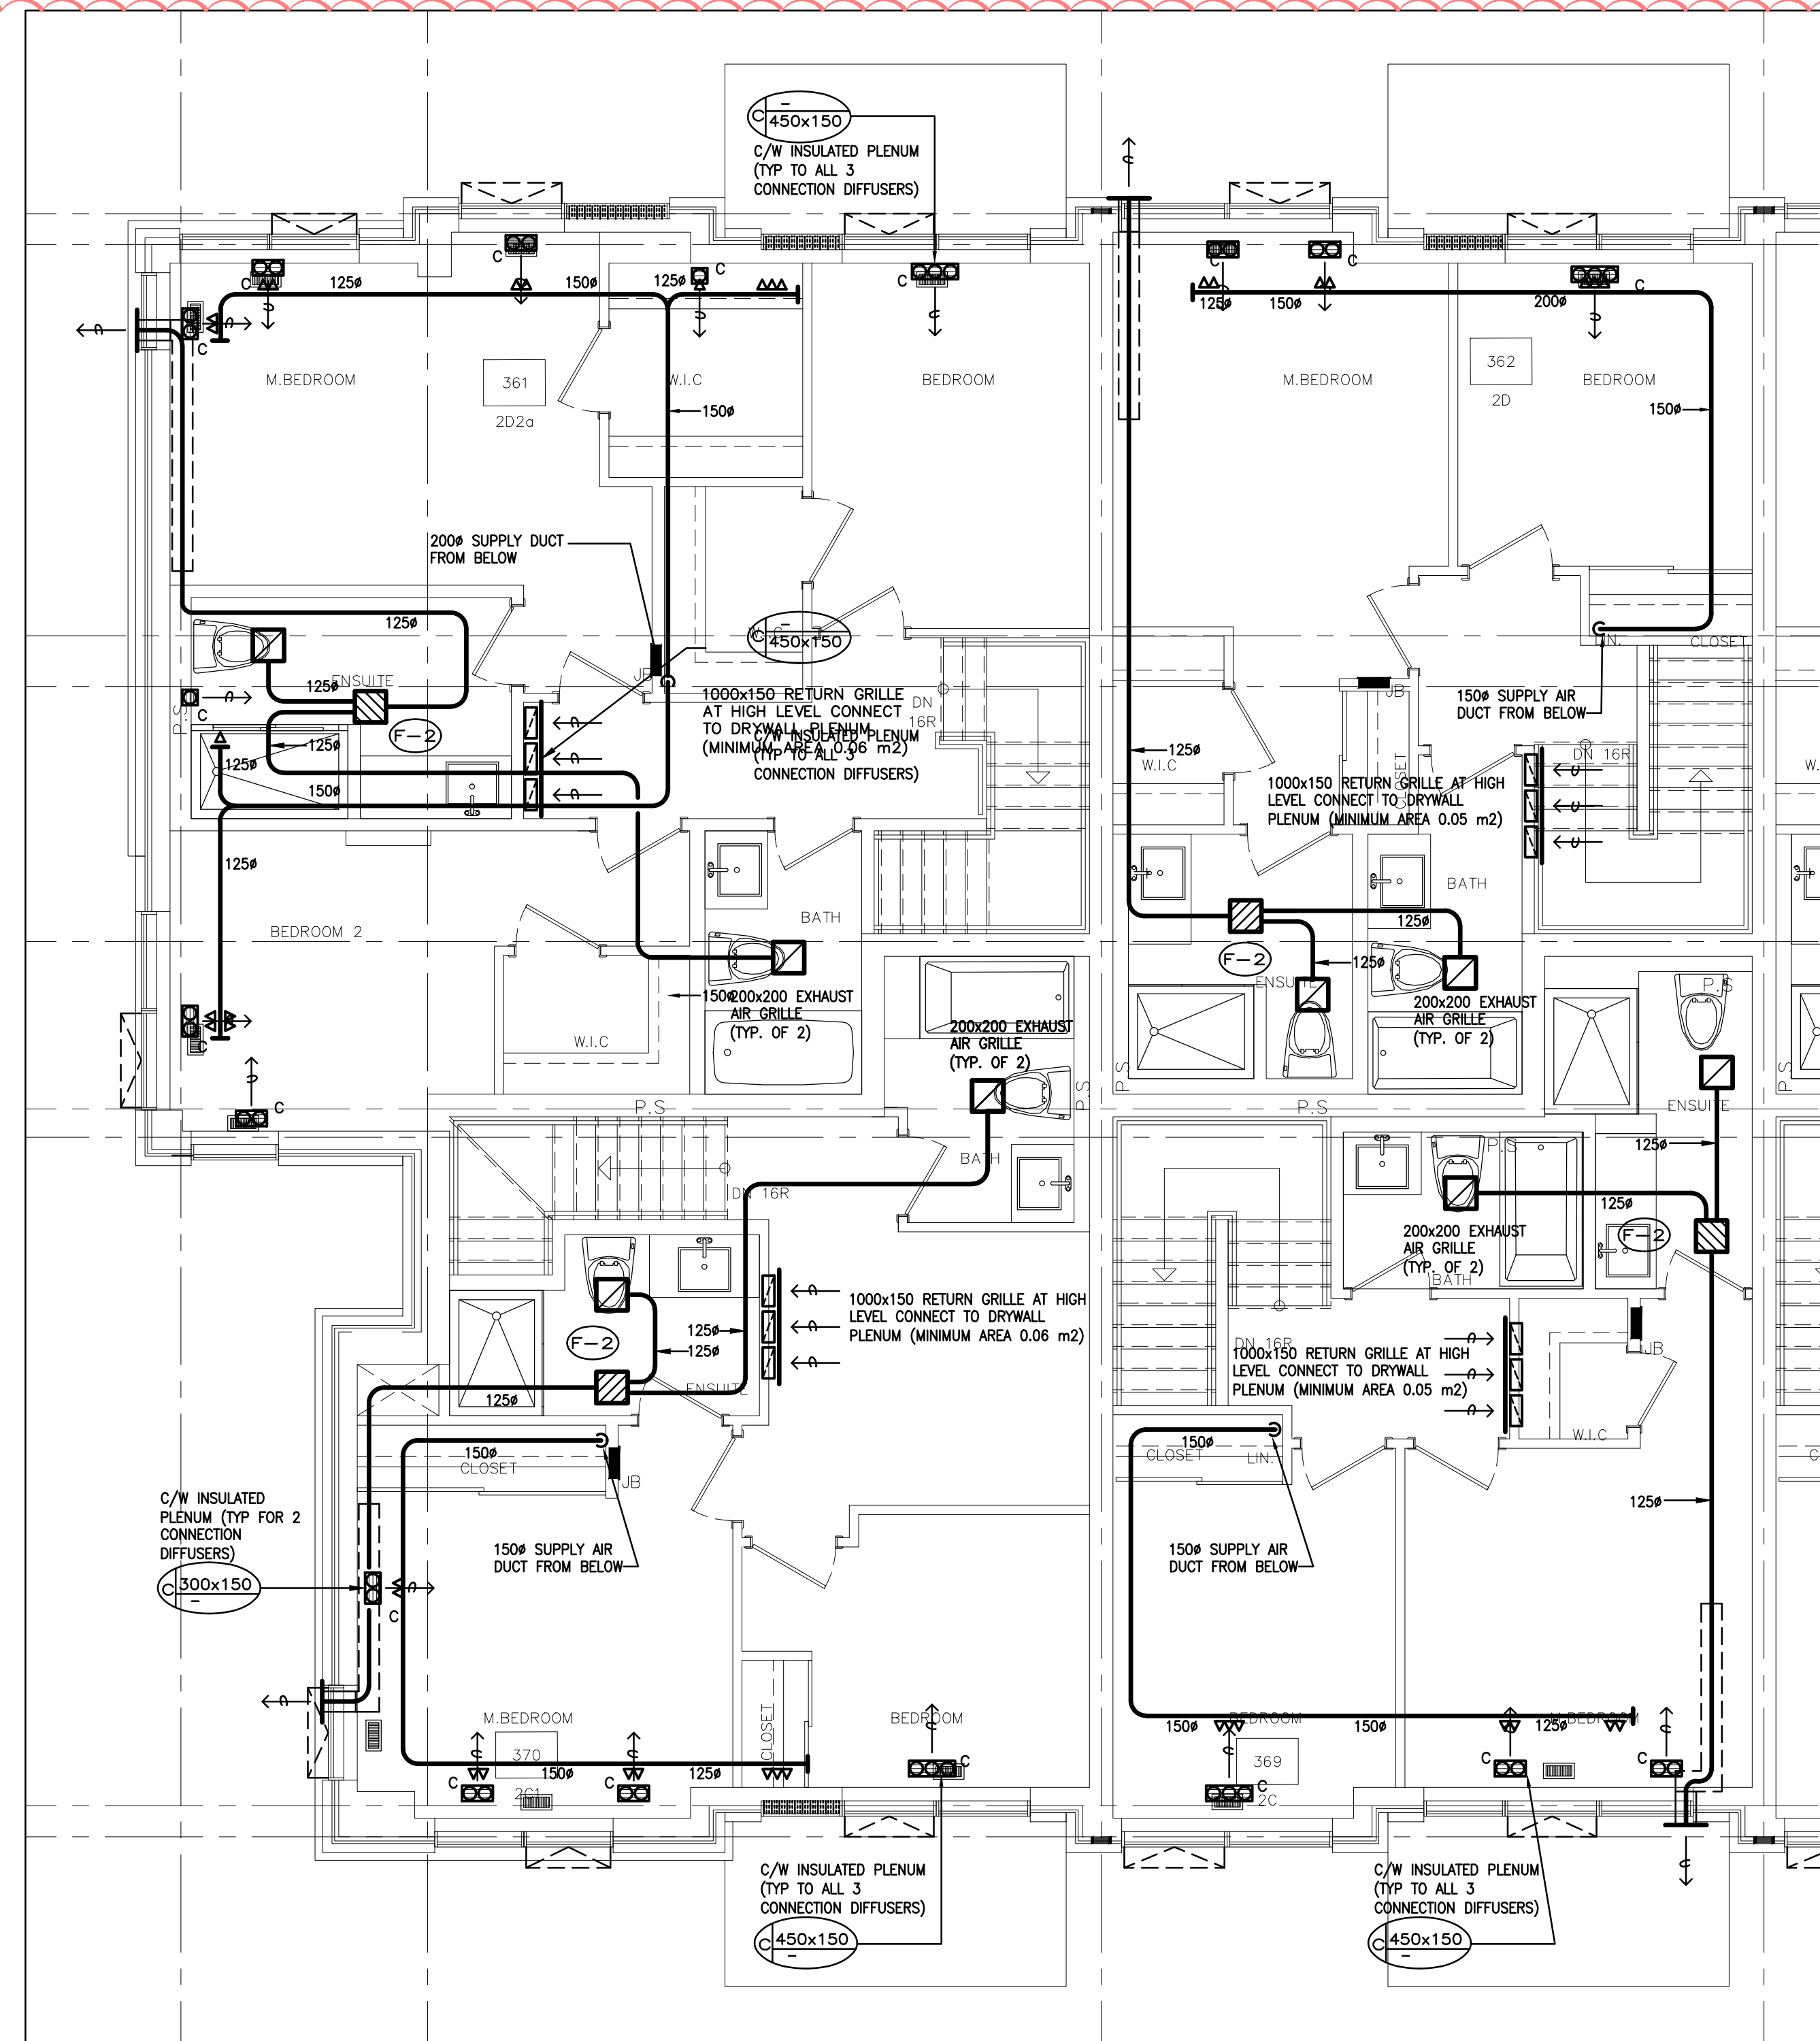


4TH FLOOR TYPICAL SUITE LAYOUT
TYPE 2C1, 2C, 2D2a & 2D

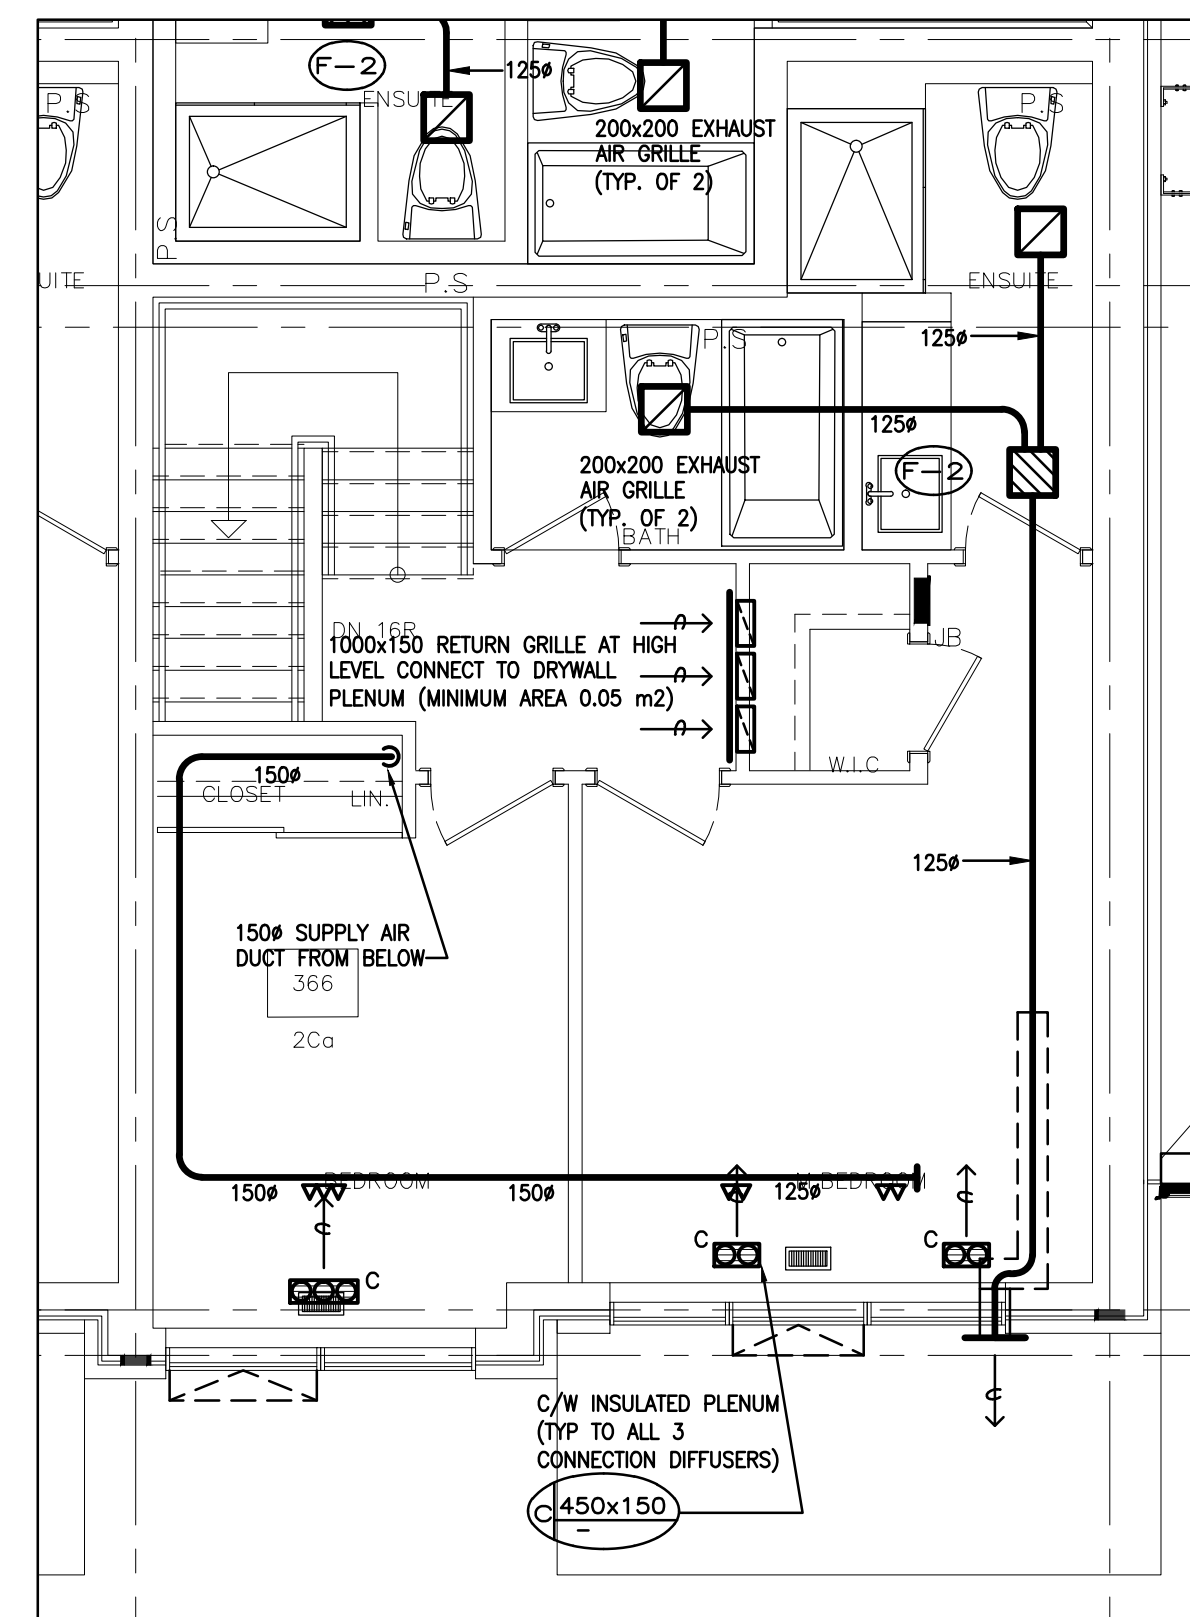


4TH FLOOR TYPICAL SUITE LAYOUT TYPE 2Ca

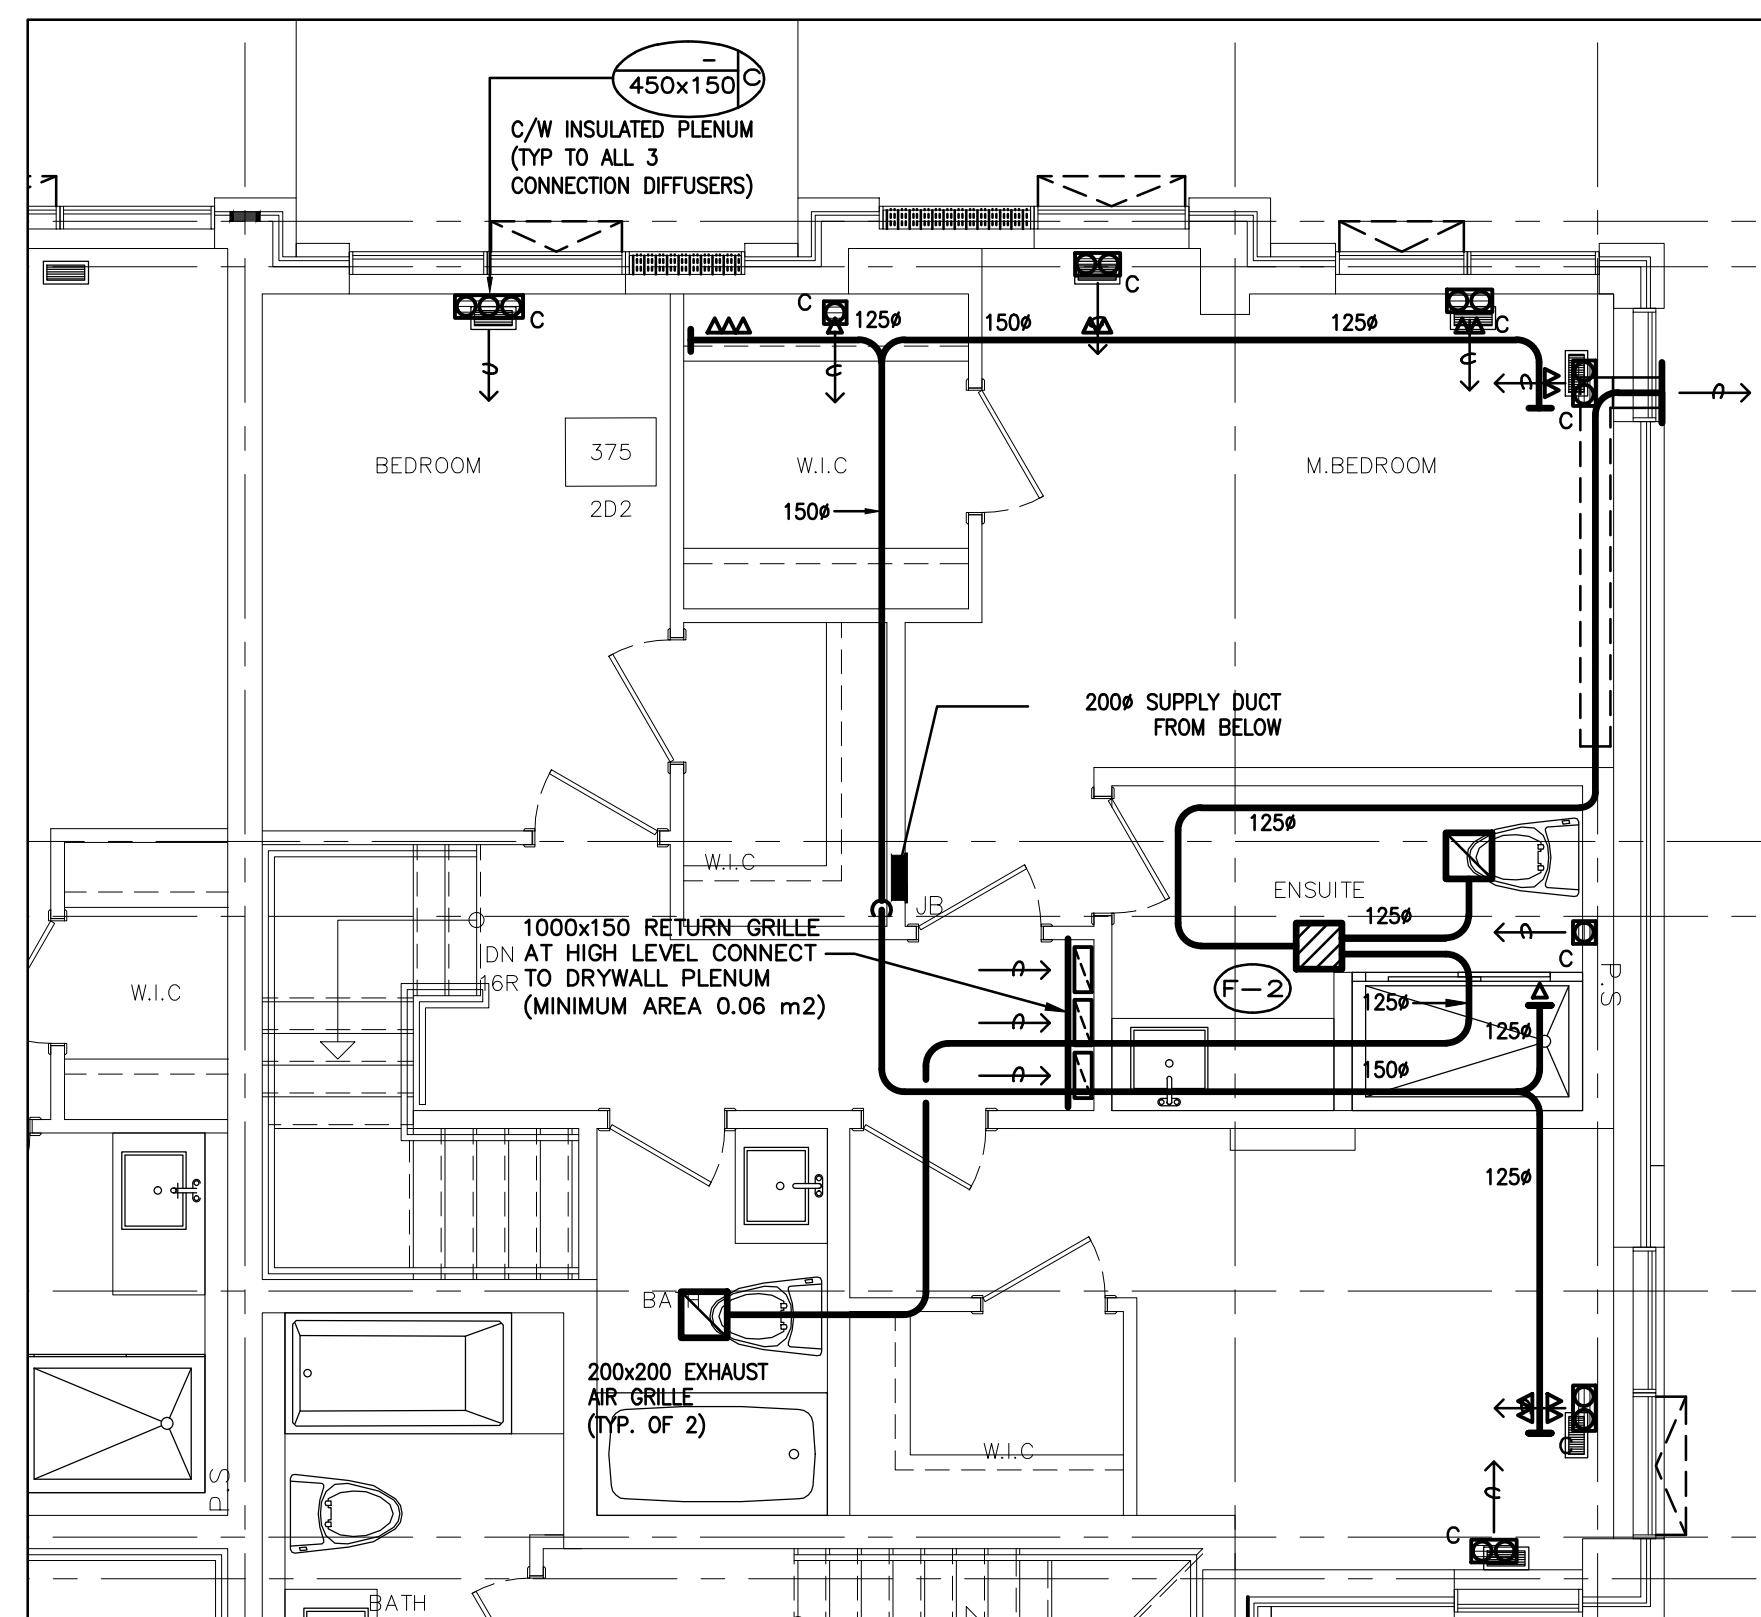


4TH FLOOR TYPICAL SUITE LAYOUT TYPE 2D2

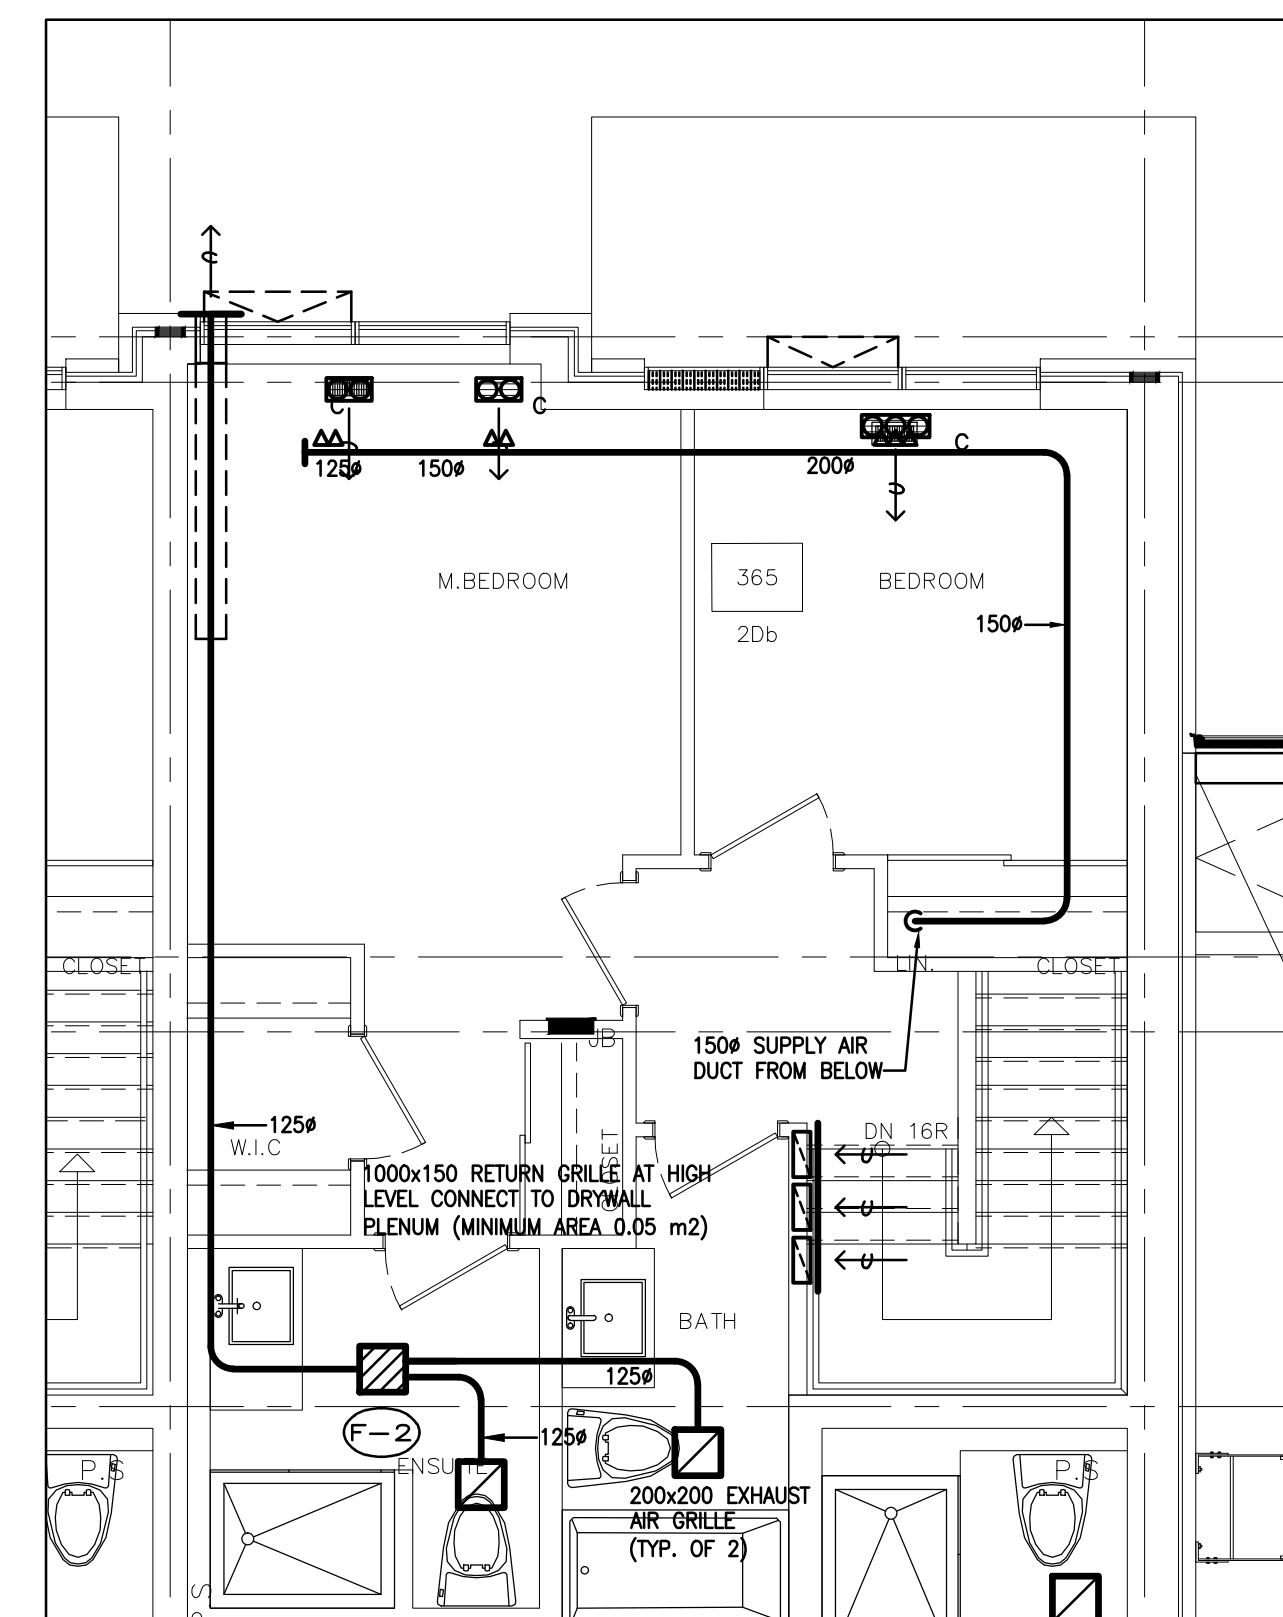


4TH FLOOR TYPICAL SUITE LAYOUT TYPE 2Db

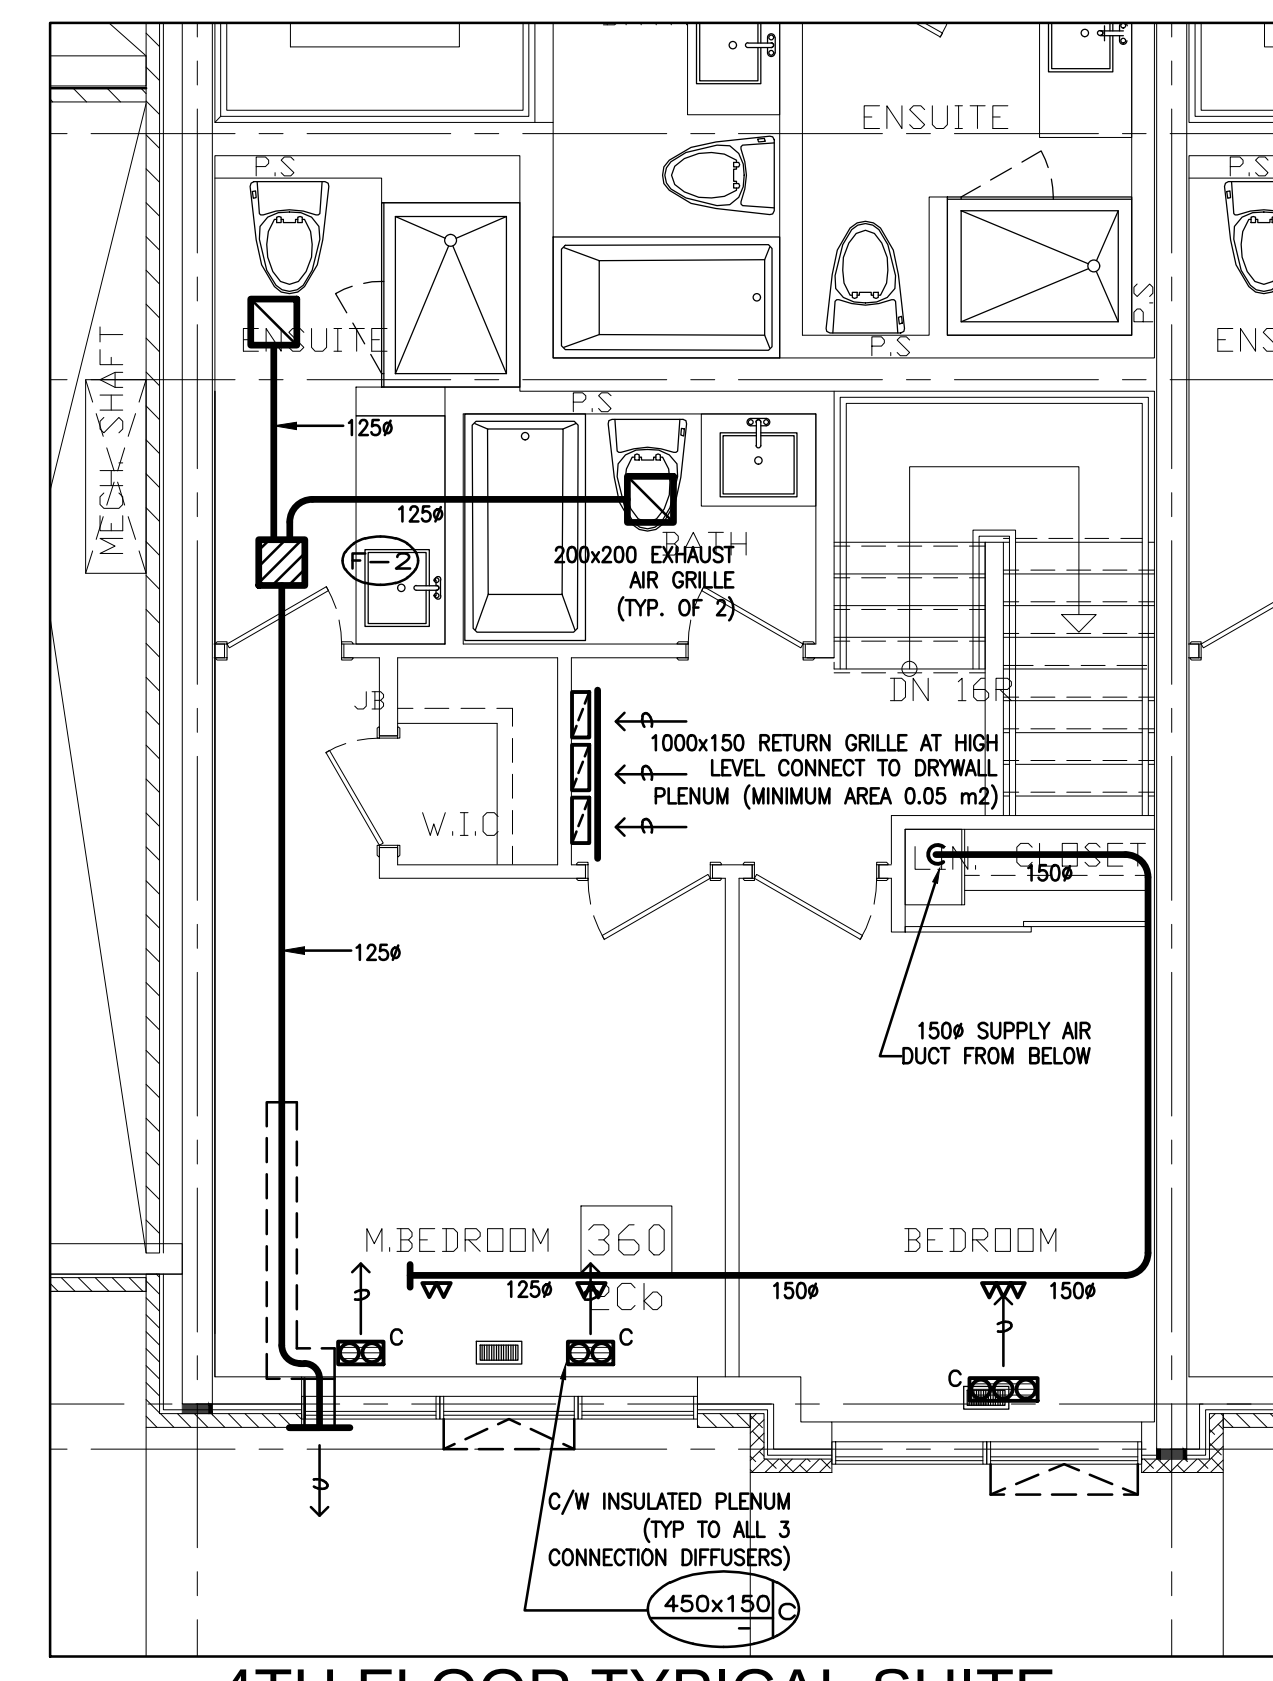


4TH FLOOR TYPICAL SUITE
LAYOUT TYPE 2Cb

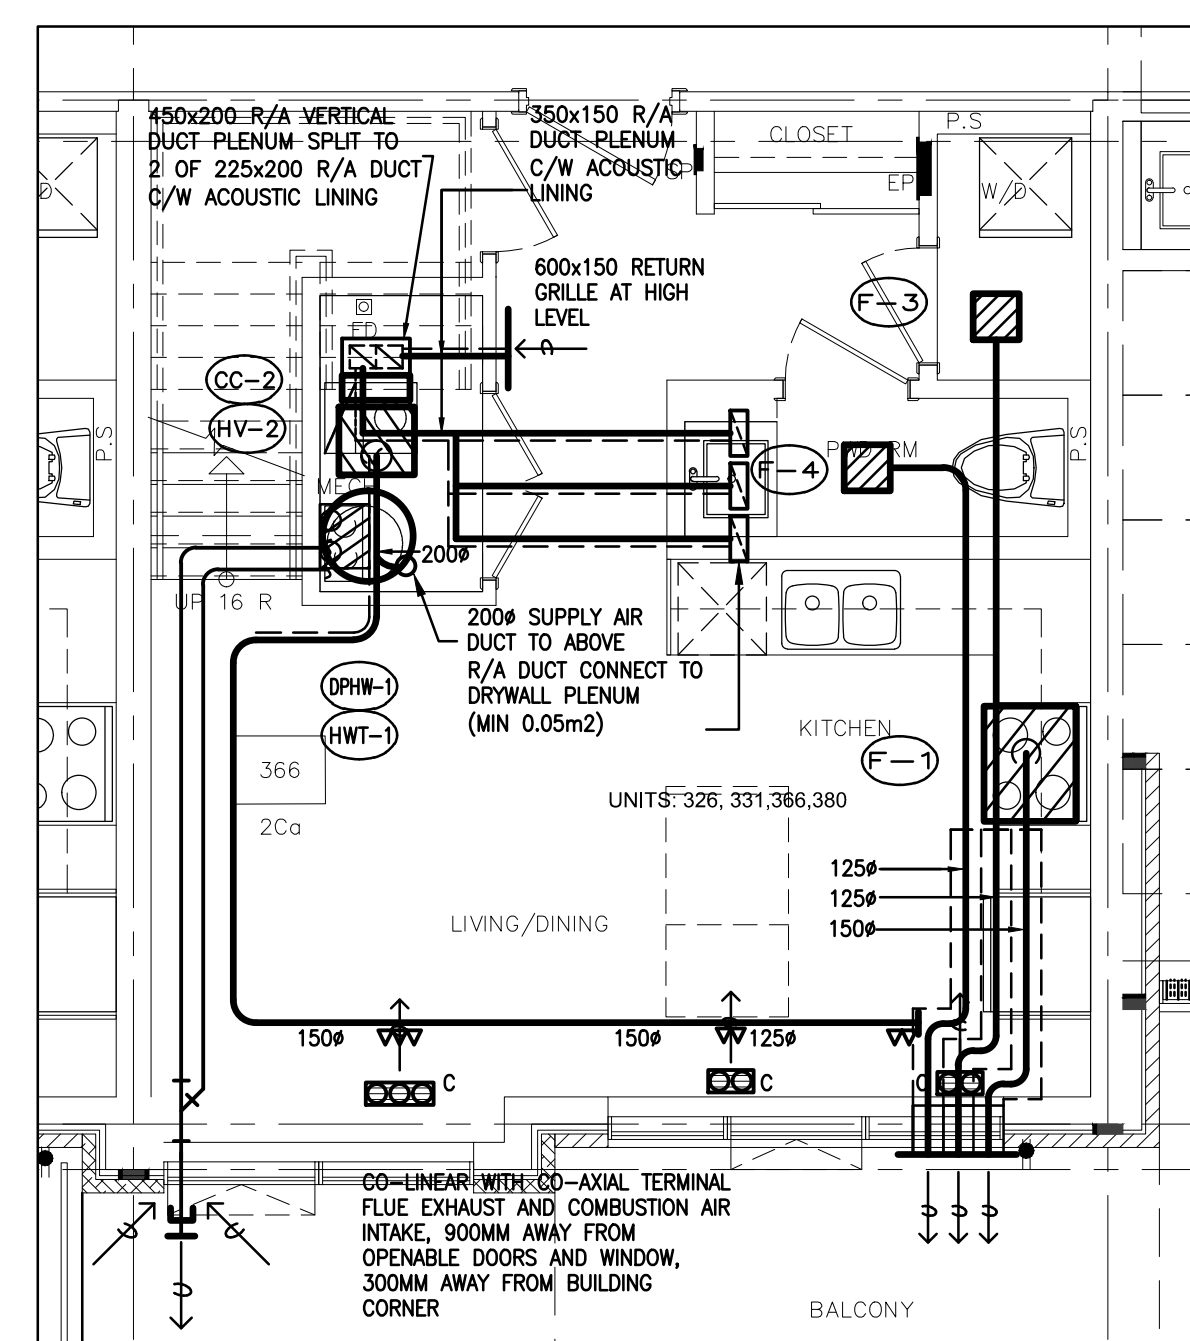


3RD FLOOR TYPICAL SUITE LAYOUT TYPE 2Ca

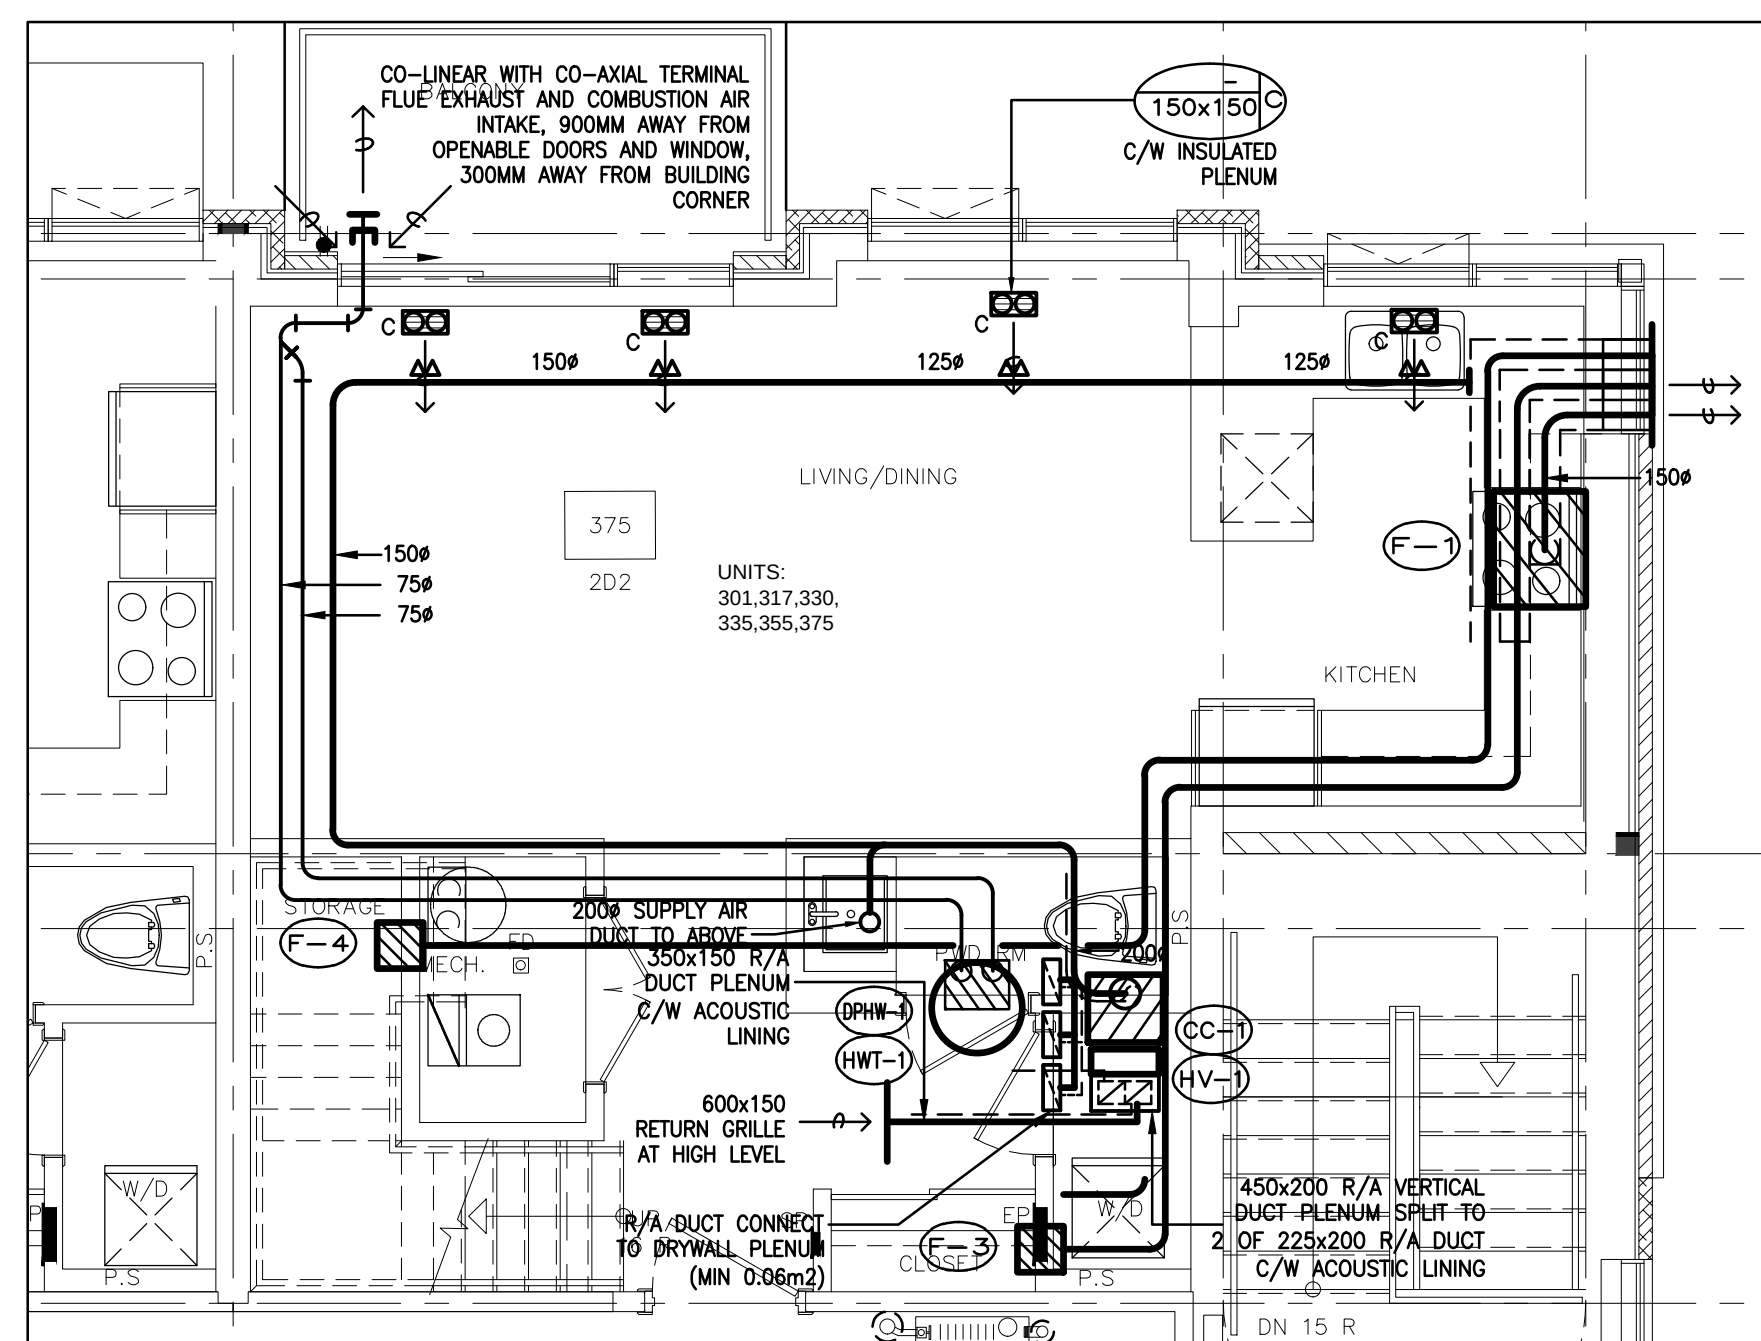

3RD FLOOR TYPICAL SUITE LAYOUT TYPE 2D2

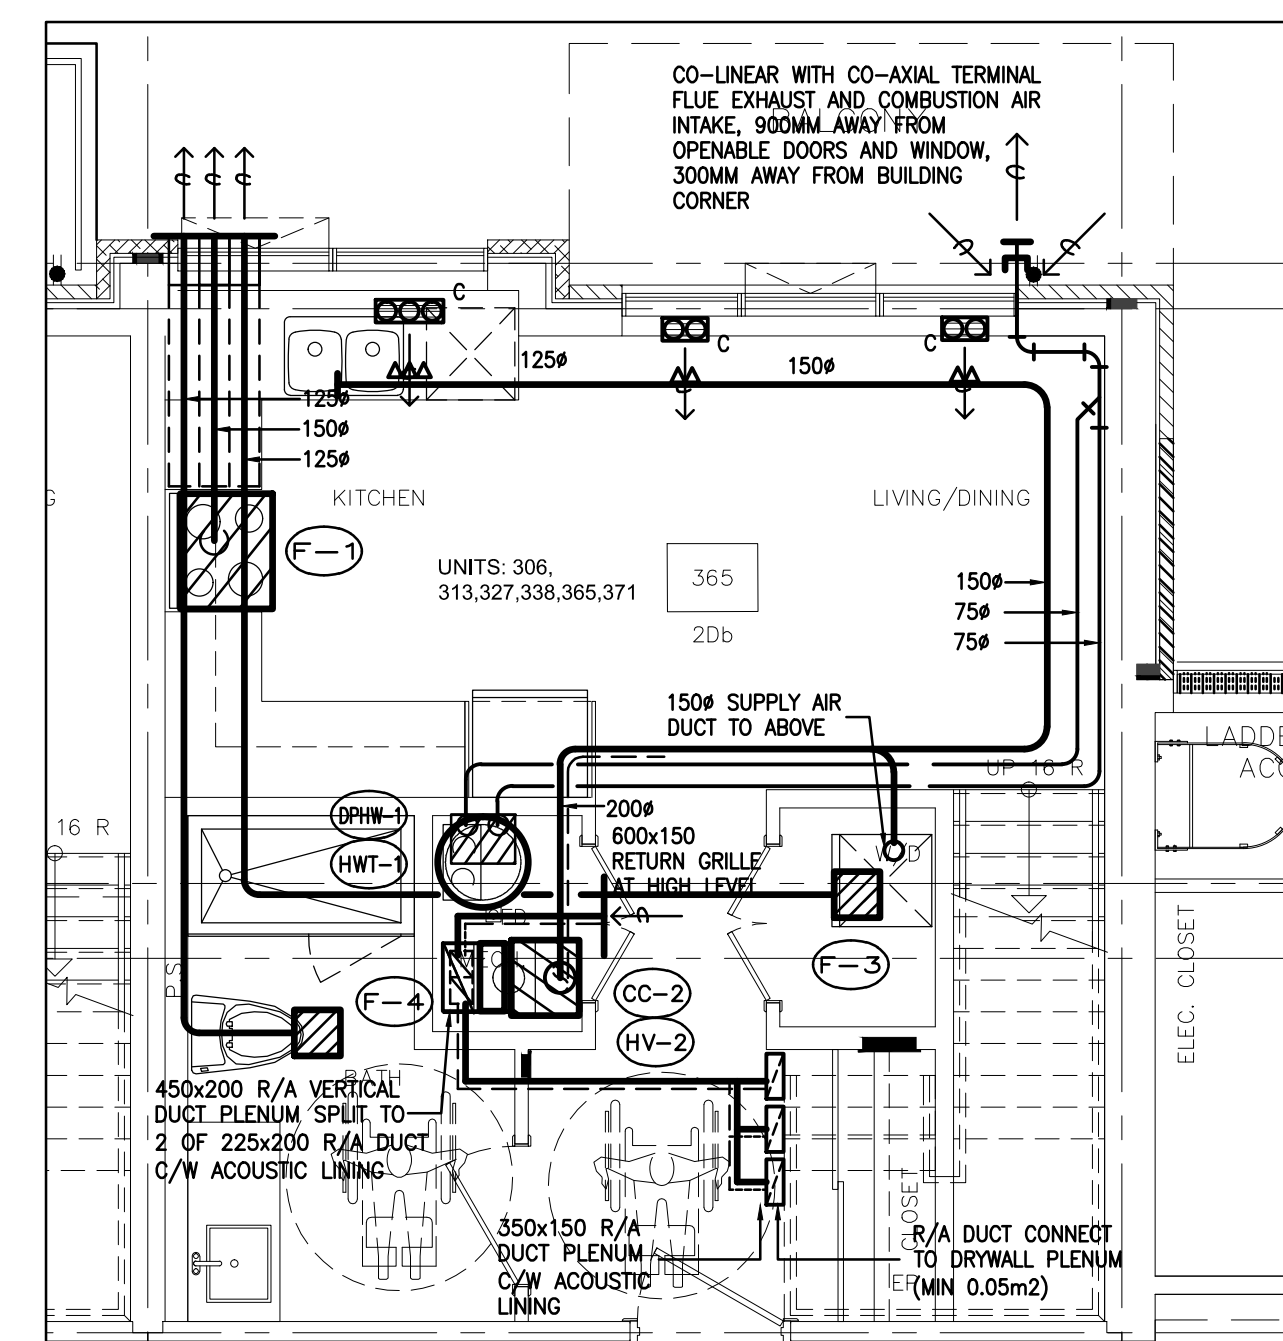

3RD FLOOR TYPICAL SUITE LAYOUT TYPE 2Db

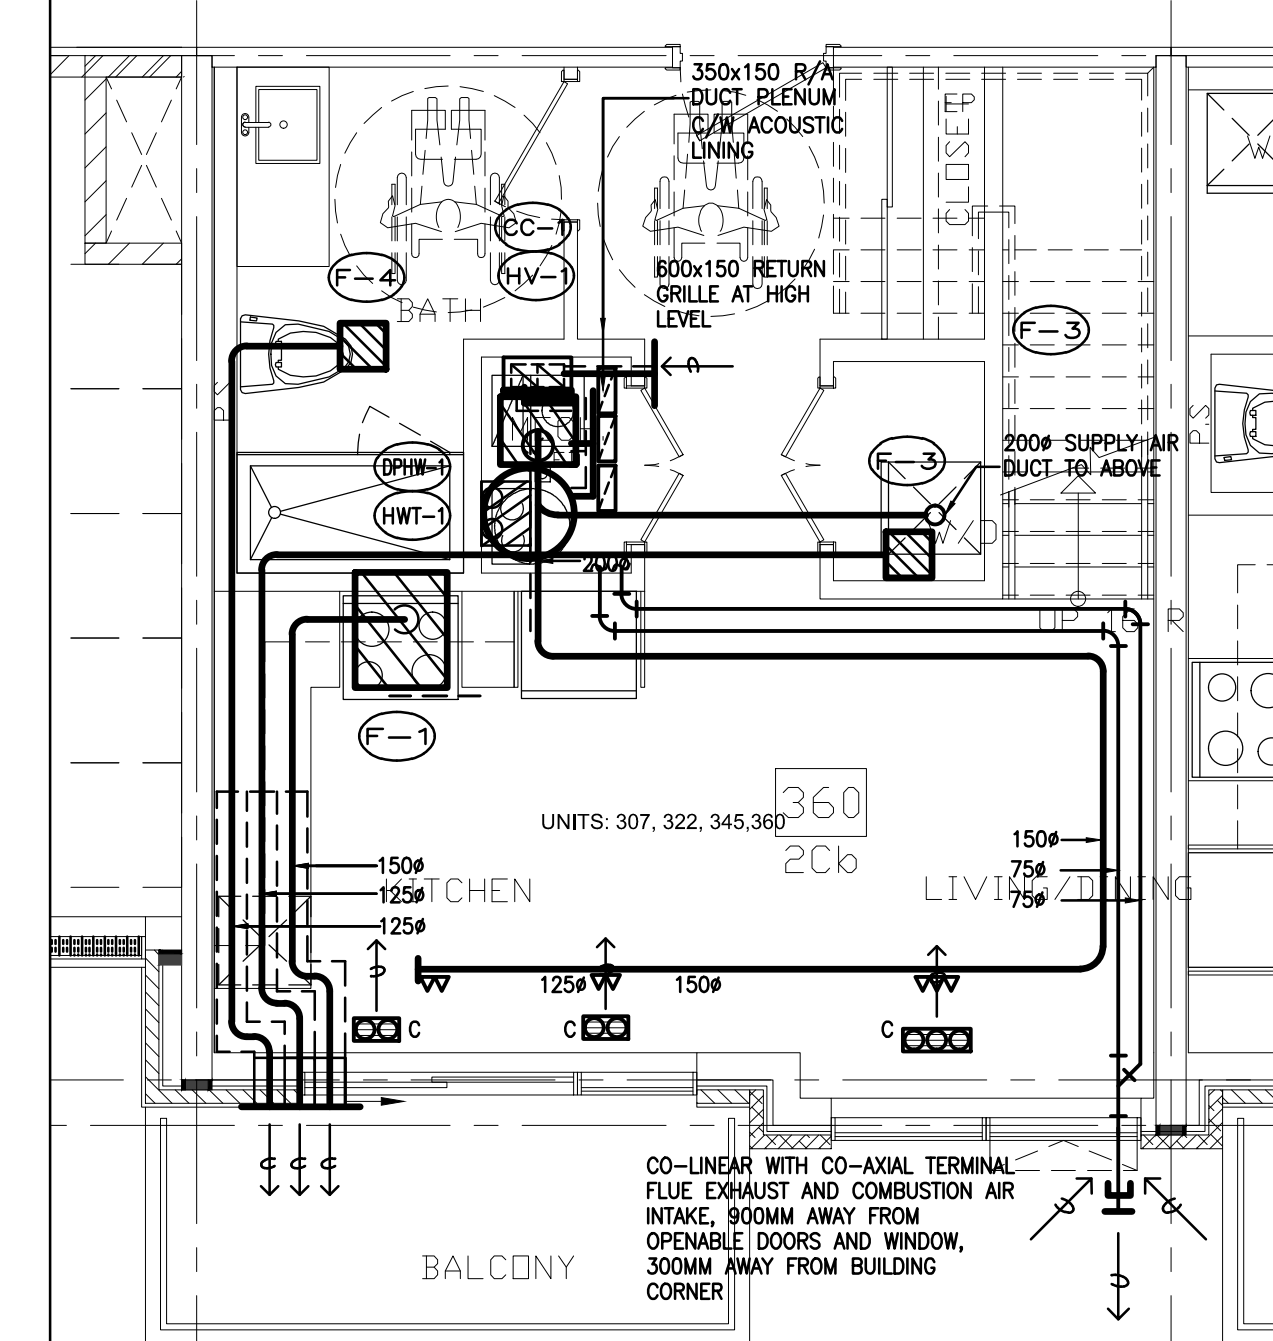

3RD FLOOR TYPICAL SUITE
LAYOUT TYPE 2Cb

NO.	BY	DESCRIPTION	DATE
08	LB	ISSUED AS PER SITE INSTRUCTION M-02	JUN. 04, 2021
07	LB	ISSUED FOR PROGRESSIVE CONSTRUCTION	MAR. 26, 2021
06	LB	ISSUED FOR PERMIT BUILDING A,B,C,D	MAR. 03, 2021
05	LB	ISSUED AS PER ADD M-05	JAN. 20, 2021
04	LB	ISSUED FOR PERMIT	SEP. 28, 2020
03	RC	ADDENDUM #04	JUN. 12, 2020
02	RC	ADDENDUM #02	SEP. 13, 2019
01	RC	ISSUED FOR TENDER	AUG. 02, 2019

REVISIONS

This drawing is an instrument of service, is provided by and is the property of United Engineering Inc. The contractor must verify and accept responsibility for all dimensions and conditions on site and must notify United Engineering Inc. of any discrepancy before proceeding. United Engineering Inc. is not responsible for the accuracy of Architectural, structural, interior design, etc. on this drawing. Refer to the appropriate trade drawings before proceeding with any work. Installation must conform to all applicable codes and requirements of the authorities having jurisdiction. This drawing is not to be scaled, all symbols are graphic representations only.



UNITED ENGINEERING INC.
Mechanical Electrical Consulting Engineers
3645 Keele Street, Suite 105,
Toronto, Ontario, M3J 1M6
Tel: (416) 398 1599, Fax: (416) 398 1933


TITLE
**TYPICAL SUITES LAYOUT
MECHANICAL**

PROJECT


**BRAMPTON STACKED
FORESTSIDE ESTATES**

**ATTMAR + PALLESCI DRIVE
BRAMPTON, ONTARIO**


DRAWN MC	CHECKED LM	SCALE 1:50
DATE MAY, 2019	PROJECT 18-017	DRAWING M-46
		OF -



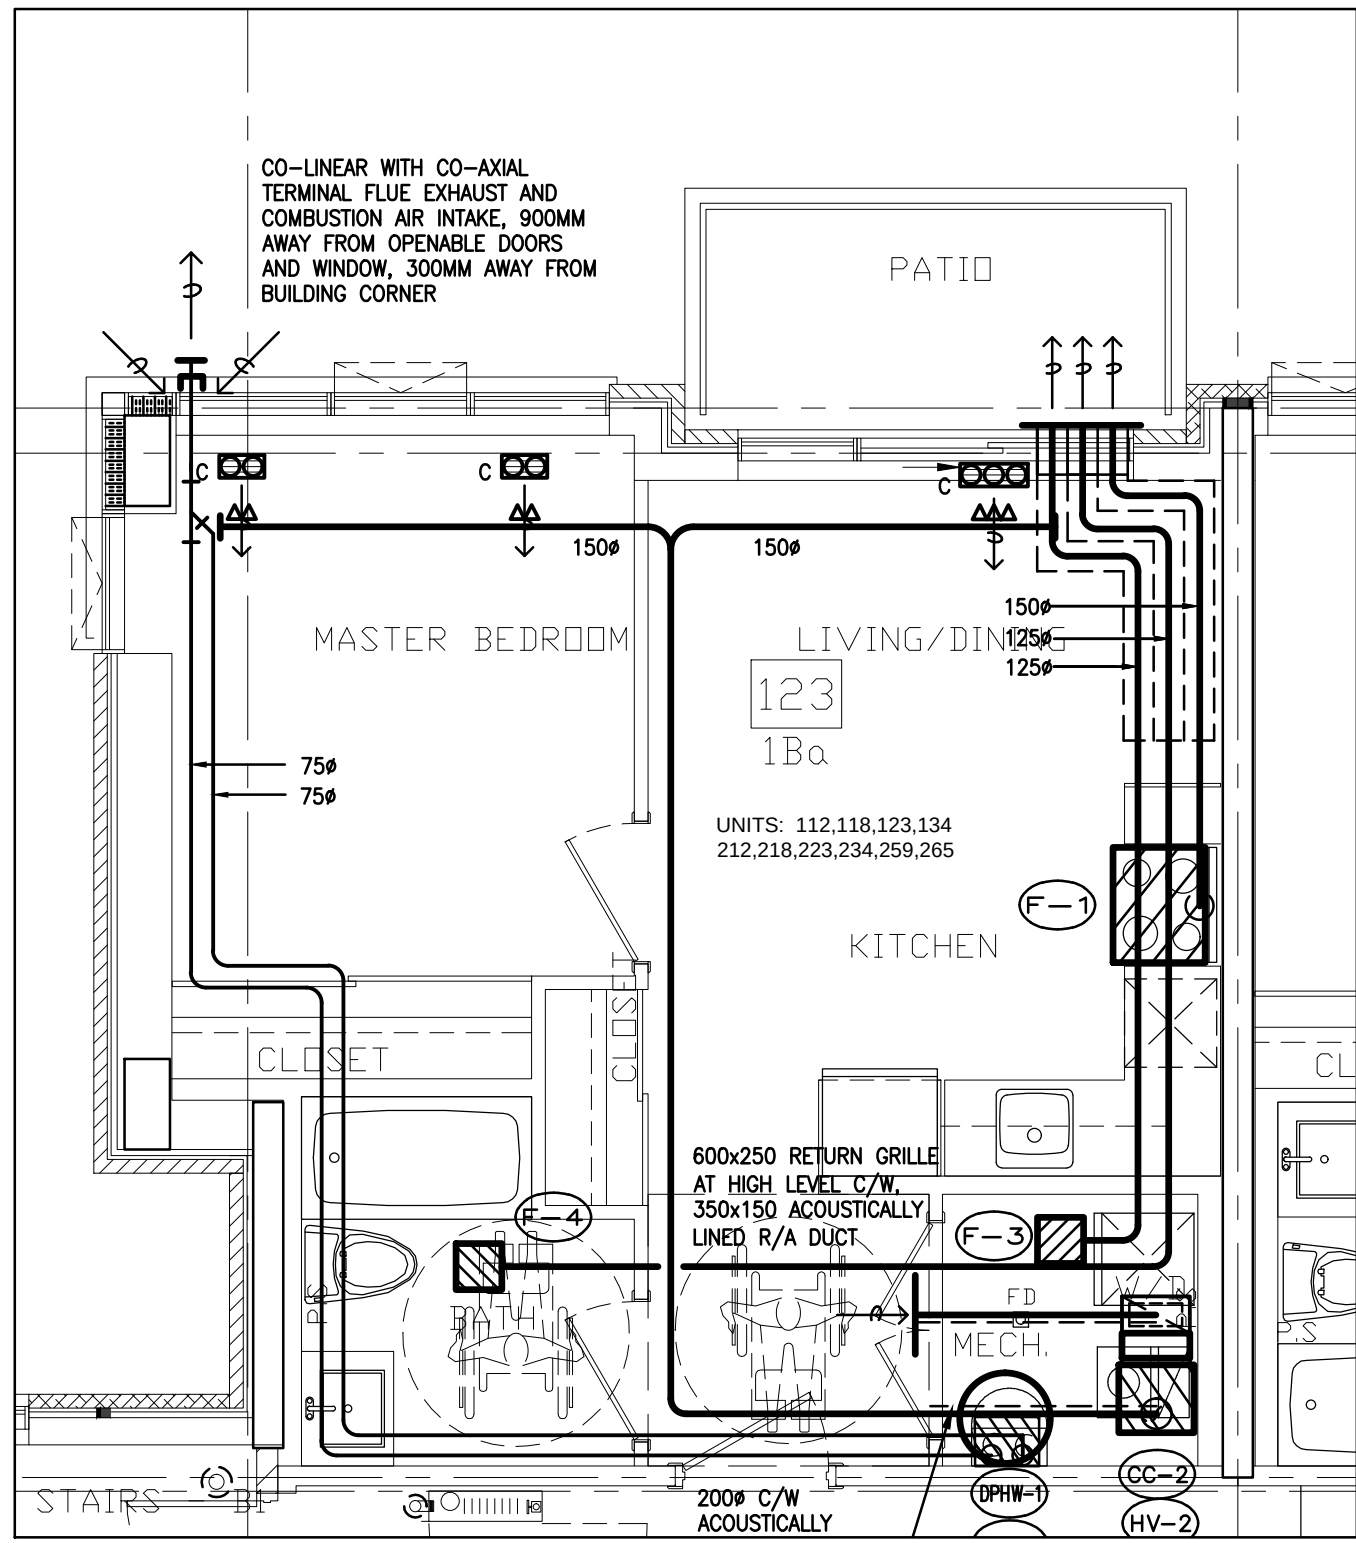


TYPICAL SUITE LAYOUT TYPE 1Ba

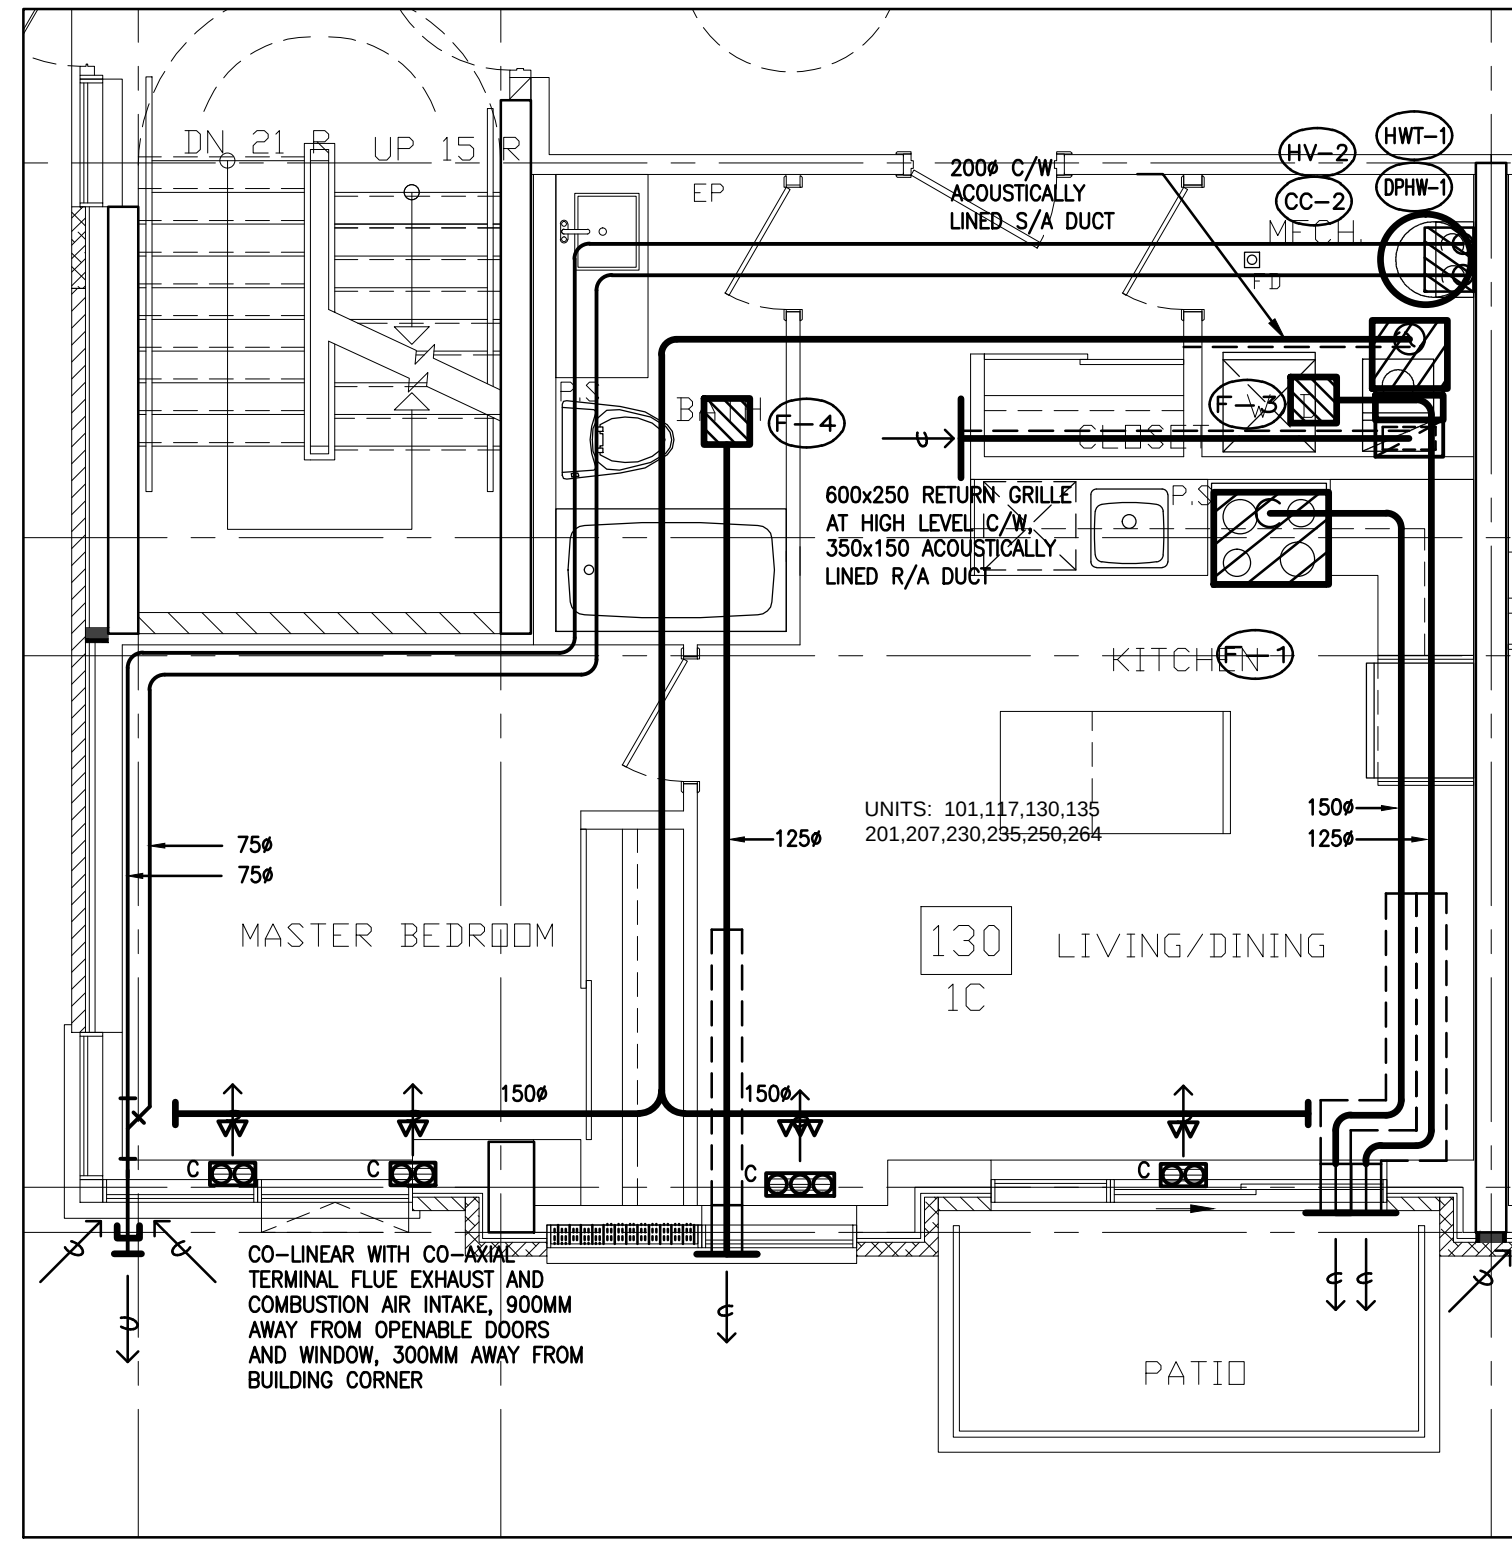

TYPICAL SUITE LAYOUT TYPE 1C

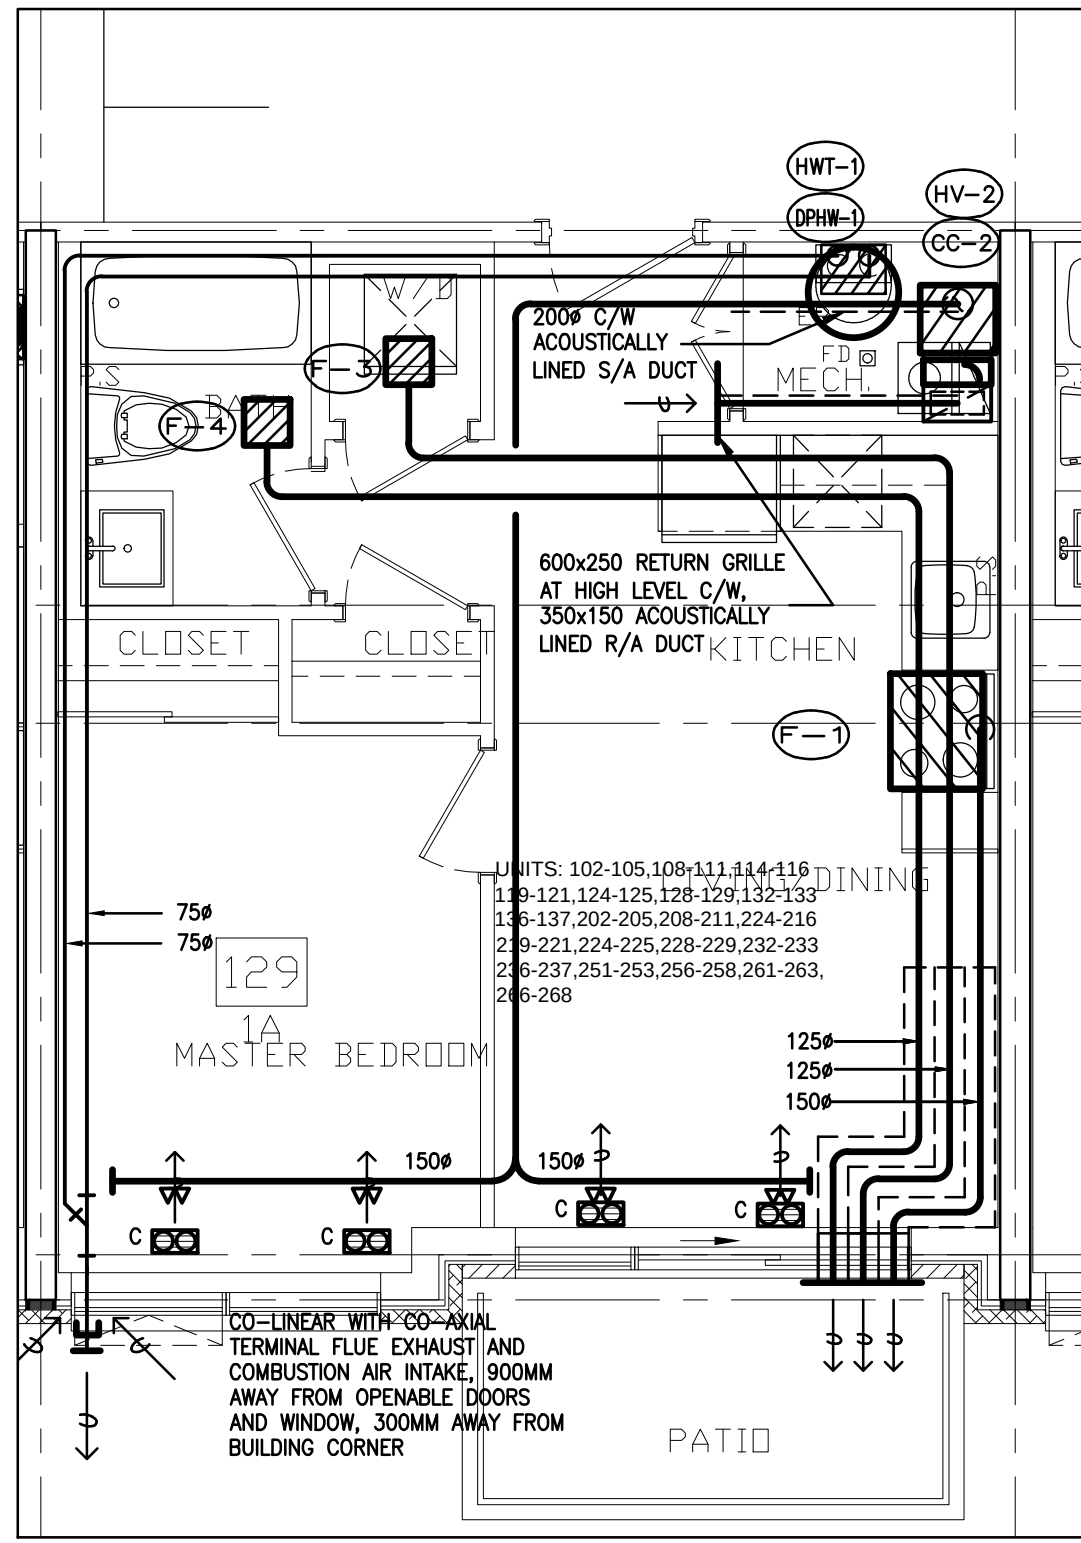

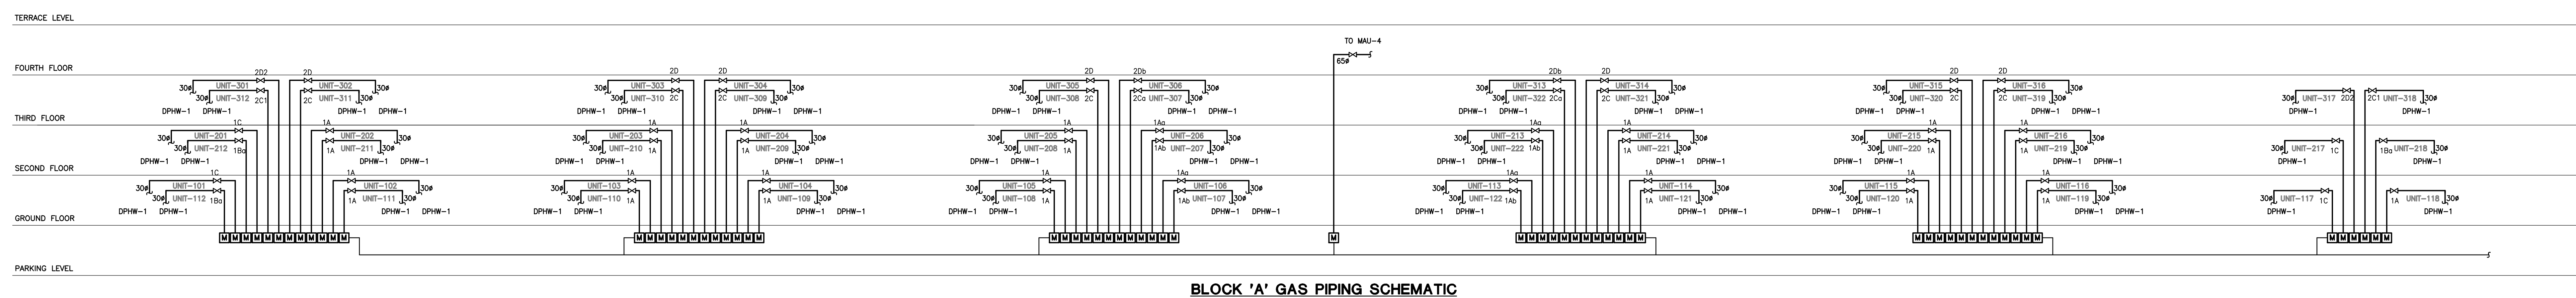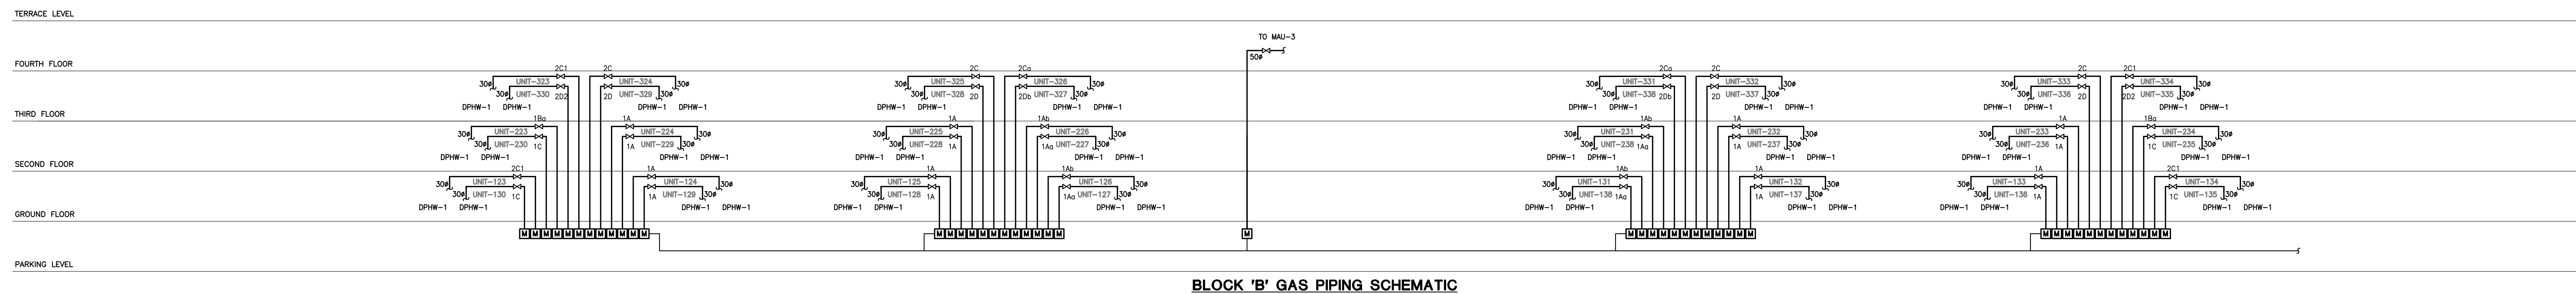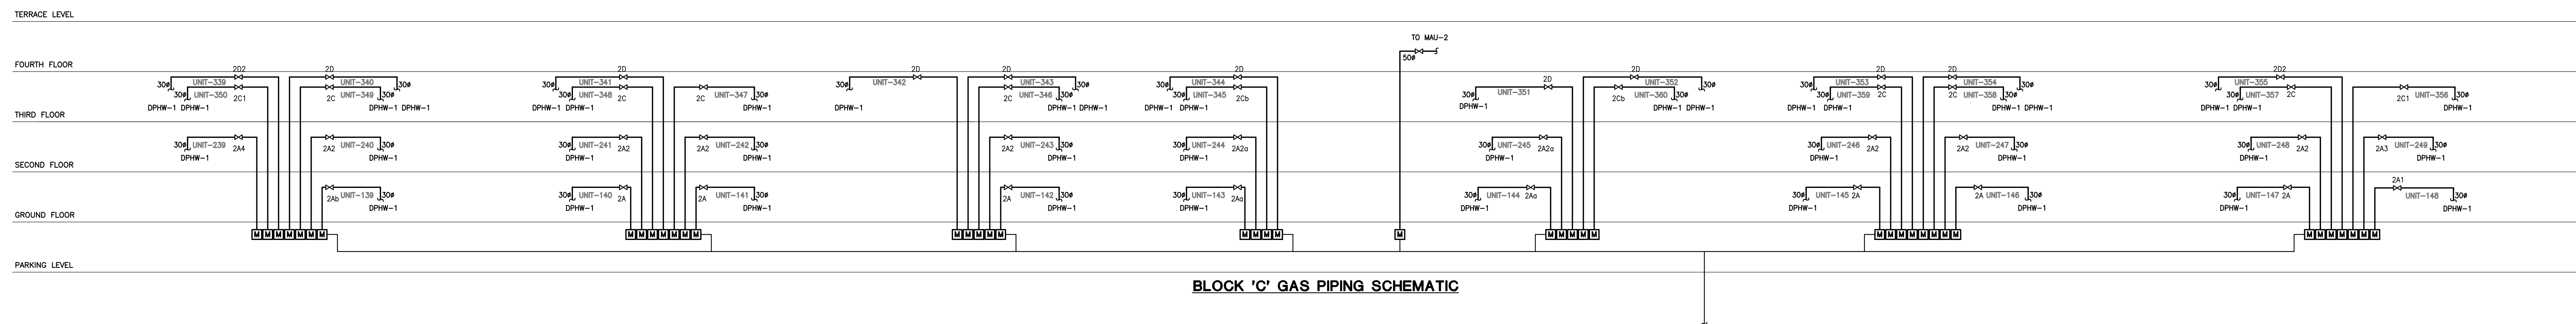


07	LB	ISSUED AS PER SITE INSTRUCTION M-02	JUN. 04, 2021
06	LB	ISSUED FOR PROGRESSIVE CONSTRUCTION	MAR. 26, 2021
05	LB	ISSUED FOR PERMIT BUILDING A,B,C,D	MAR. 03, 2021
04	LB	ISSUED AS PER ADD M-05	JAN. 20, 2021
03	LB	ISSUED FOR PERMIT	SEP. 28, 2020
02	RC	ADDENDUM #04	JUN. 12, 2020
01	RC	ISSUED FOR TENDER	AUG. 02, 2019
NO.	BY	DESCRIPTION	DATE

This drawing is an instrument of service, is provided by and is the property of United Engineering Inc. The contractor must verify and accept responsibility for all dimensions and conditions on site and must notify United Engineering Inc. of any discrepancy before proceeding.

United Engineering Inc. is not responsible for the accuracy of Architectural, structural, interior design, etc. on this drawing.

Refer to the appropriate trade drawings before proceeding with any work. Installation must conform to all applicable codes and requirements of the authorities having jurisdiction.

This drawing is not to be scaled, all symbols are graphic representations only.

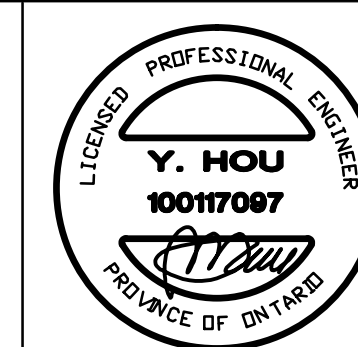

UNITED ENGINEERING INC.
 Mechanical Electrical Consulting Engineers
 3645 Keele Street, Suite 105,
 Toronto, Ontario, M3J 1M6
 Tel: (416) 398 1999, Fax: (416) 398 1933

TITLE
GAS SCHEMATICS

PROJECT

**BRAMPTON STACKED
FORESTSIDE ESTATES**

ATTMAR + PALLESCHI DRIVE
BRAMPTON, ONTARIO

DRAWN MC	CHECKED LM	SCALE N.T.S.
DATE MAY, 2019	PROJECT 18-017	DRAWING M-49
		OF